

ATRIUM HEALTH

AH CABARRUS BH RENOVATION

920 Church Street North, Concord, NC 28025

Project No: JAZZID_14452

MPS Project No: 02600404.00

Agency Review ID:

OWNER

AH CABARRUS HOSPITAL
920 CHURCH STREET NORTH
CONCORD, NC 28025
980.866.8408
Daniel.Martin1@Advocatehealth.org

MR. DANIEL MARTIN

ARCHITECT

McMILLAN PAZDAN SMITH ARCHITECTURE
1422 SOUTH TRYON STREET
SUITE 700
CHARLOTTE, NC 28203
980.201.3035
WWW.MCMILLANPAZDANSMITH.COM

MS. TRACIE SANSAVERA

INTERIOR

McMILLAN PAZDAN SMITH ARCHITECTURE
1422 SOUTH TRYON STREET
SUITE 700
CHARLOTTE, NC 28203
980.201.3035
WWW.MCMILLANPAZDANSMITH.COM

MS. COURTNEY HARDEN

MEP ENGINEERING

MCKIM & CREED
8020 TOWER POINT DRIVE
CHARLOTTE, NC 28227
704.841.2588
WWW.MCKIMCREED.COM

MR. JAKE WISE

DRAWING LIST

GENERAL

SHEET NO	SHEET NAME
G000	COVER SHEET & APPENDIX B
G101	LIFE SAFETY PLAN - LEVEL 01
G104	LIFE SAFETY PLAN - LEVEL 04

ARCHITECTURAL

SHEET NO	SHEET NAME
A001	PROJECT STANDARDS AND PARTITION TYPES
A111	DEMO AND NEW PLANS - LEVEL 01 + 04
A191	EQUIPMENT PLAN - LEVEL 01
A800	DOOR SCHEDULE, GLAZING AND MILLWORK DETAILS

INTERIORS


SHEET NO	SHEET NAME
ID112	INTERIOR FINISH & FURNITURE PLANS - LEVEL 01 & LEVEL 04

MECHANICAL AND PLUMBING


SHEET NO	SHEET NAME
MP001	MECHANICAL SYMBOLS, NOTES, AND ABBREVIATIONS
MP101	MECHANICAL AND PLUMBING - LEVEL 01 - DEMOLITION & NEW WORK PLAN
MP102	MECHANICAL AND PLUMBING - LEVEL 04 - DEMOLITION & NEW WORK PLAN

ELECTRICAL

SHEET NO	SHEET NAME
E001	ELECTRICAL SYMBOLS, LEGENDS AND ABBREVIATIONS
E002	ELECTRICAL SPECIFICATIONS
E100	ELECTRICAL - LEVEL 01 - OVERALL PLANS
E200	ELECTRICAL - LEVEL 01 - LIGHTING - DEMOLITION
E201	ELECTRICAL - LEVEL 01 - POWER AND SPECIAL SYSTEMS - DEMOLITION
E202	ELECTRICAL - LEVEL 04 - LIGHTING - DEMOLITION
E203	ELECTRICAL - LEVEL 04 - POWER AND SPECIAL SYSTEMS - DEMOLITION
E300	ELECTRICAL - LEVEL 01 - LIGHTING - NEW WORK
E301	ELECTRICAL - LEVEL 01 - POWER AND SPECIAL SYSTEMS - NEW WORK
E302	ELECTRICAL - LEVEL 04 - LIGHTING - NEW WORK
E303	ELECTRICAL - LEVEL 04 - POWER AND SPECIAL SYSTEMS - NEW WORK
E601	ELECTRICAL - PARTIAL RISER DIAGRAM AND PANEL SCHEDULES
E701	ELECTRICAL DETAILS

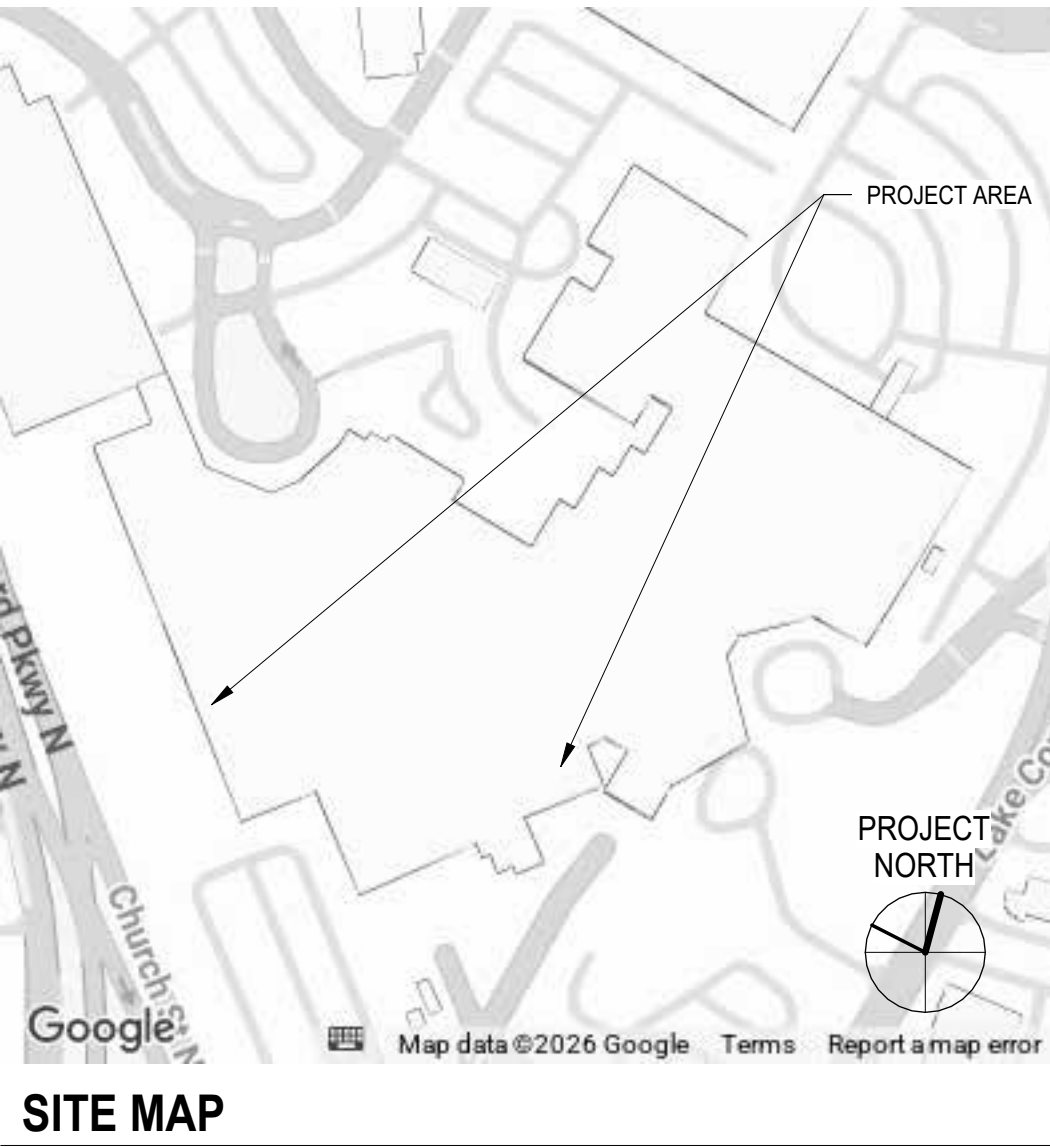

Atrium Health
PROJECT & CONSTRUCTION MANAGEMENT
1400 East Morehead St.
Charlotte, NC 28204

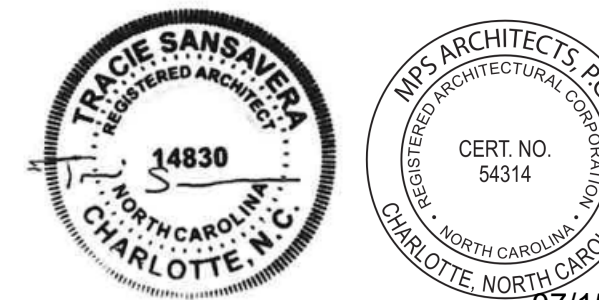

07/15/2026

ATRIUM HEALTH

AH CABARRUS BH RENOVATION

AH Cabarrus Memorial Building
Atrium Health Facility #: 1232
920 Church Street North, Concord, NC 28025

PROJECT INFORMATION:

Name of Project: AH CABARRUS BH RENOVATION
Address: 920 Church Street North, Concord, NC 28025

Owner/Authorized Agent: Daniel Martin
E-mail: daniel.martin1@advocatehealth.org
Phone: (980) 866-8408

Owned By: ☐ City/County ☒ Private ☐ State
Code Enforcement Jurisdiction: ☒ City: Concord ☒ County: Cabarrus ☐ State

CONTACT: Tracie Sansavera

DESIGNER	FIRM	NAME	LICENSE#	TELEPHONE#	E-MAIL
Architectural	McMillan Pazdan Smith	Tracie Sansavera	14830	980.529.7105	tsansavera@mcmillanpazdansmith.com

Civil	Electrical	Fire Alarm	Plumbing	Mechanical	Sprinkler/ Standpipe	Structural	Retaining Walls >5' High	Other
	McKim & Creed Thomas P. Burford 030422 704.841.2588 tburford@mckimcreed.com		McKim & Creed Jacob M. Wise 093105 704.841.2588 jwise@mckimcreed.com	McKim & Creed Jacob M. Wise 093105 704.841.2588 jwise@mckimcreed.com				

2018 NC EXISTING BUILDING CODE:	Prescriptive	Repair	Chapter 14
Alterations:	☐ Level I	☐ Level II	☐ Level III
	☐ Historic Property	☐ Change of Use	

CONSTRUCTED: Varies
RENOVATED: 2026

RISK CATEGORY (Table 1604.5)
Current: ☐ I ☐ II ☐ III ☒ IV
Proposed: ☐ I ☐ II ☐ III ☐ IV

2018 NC EXISTING BUILDING CODE: ☐ Prescriptive ☐ Repair ☐ Chapter 14
Alterations: ☐ Level I ☐ Level II ☐ Level III
☐ Historic Property ☐ Change of Use

CONSTRUCTED: Varies
RENOVATED: 2026

RISK CATEGORY (Table 1604.5)
Current: ☐ I ☐ II ☐ III ☒ IV
Proposed: ☐ I ☐ II ☐ III ☐ IV

2018 NC EXISTING BUILDING CODE: ☐ Prescriptive ☐ Repair ☐ Chapter 14
Alterations: ☐ Level I ☐ Level II ☐ Level III
☐ Historic Property ☐ Change of Use

CONSTRUCTED: Varies
RENOVATED: 2026

RISK CATEGORY (Table 1604.5)
Current: ☐ I ☐ II ☐ III ☒ IV
Proposed: ☐ I ☐ II ☐ III ☐ IV

CONSTRUCTED: Varies
RENOVATED: 2026

RISK CATEGORY (Table 1604.5)
Current: ☐ I ☐ II ☐ III ☒ IV
Proposed: ☐ I ☐ II ☐ III ☐ IV

CONSTRUCTED: Varies
RENOVATED: 2026

RISK CATEGORY (Table 1604.5)
Current: ☐ I ☐ II ☐ III ☒ IV
Proposed: ☐ I ☐ II ☐ III ☐ IV

CONSTRUCTED: Varies
RENOVATED: 2026

RISK CATEGORY (Table 1604.5)
Current: ☐ I ☐ II ☐ III ☒ IV
Proposed: ☐ I ☐ II ☐ III ☐ IV

CONSTRUCTED: Varies
RENOVATED: 2026

RISK CATEGORY (Table 1604.5)
Current: ☐ I ☐ II ☐ III ☒ IV
Proposed: ☐ I ☐ II ☐ III ☐ IV

CONSTRUCTED: Varies
RENOVATED: 2026

RISK CATEGORY (Table 1604.5)
Current: ☐ I ☐ II ☐ III ☒ IV
Proposed: ☐ I ☐ II ☐ III ☐ IV

ALLOWABLE AREA

Primary Occupancy Classification: Select one
Assembly ☐ A-1 ☐ A-2 ☐ A-3 ☐ A-4 ☐ A-5
Business ☐
Educational ☐
Factory ☐ F-1 Moderate ☐ F-2 Low
Hazardous ☐ H-1 Detonate ☐ H-2 Deflagrate ☐ H-3 Combust ☐ H-4 Health ☐ H-5 HPM
Institutional ☐ I-1 Condition: ☐ 1 ☐ 2 ☒ I-2 Condition: ☐ 1 ☒ 2 ☒ I-3 Condition: ☐ 1 ☐ 2 ☐ 3 ☐ 4 ☐ 5
Interior ☐ I-4
Mercantile ☐
Residential ☐ R-1 ☐ R-2 ☐ R-3 ☐ R-4
Storage ☐ S-1 Moderate ☐ S-2 Low ☐ High-Piled
☐ Parking Garage ☐ Open ☐ Enclosed ☐ Repair Garage
Utility and Miscellaneous ☐

Accessory Occupancy Classification: None in scope of work; no change to existing
Incidental Uses (Table 509): None in scope of work; no change to existing
Special Uses (Chapter 4 - List Code Sections): 403, 407 in scope. Other special uses may apply. No changes to existing.

Special Provisions (Chapter 5 - List Code Sections): None
Mixed Occupancy: ☐ No ☒ Yes Separation: Exception: Other occupancies not in scope
☒ Non-Separated Use (508.3)
The required type of construction for the building shall be determined by applying the height and area limitations for each of the applicable occupancies to the entire building. The most restrictive type of construction, so determined, shall apply to the entire building.

☒ Separated Use (508.4) - REF below for area calculations
For each story, the area of the occupancy shall be such that the sum of the ratios of the actual floor area of each use divided by the allowable floor area for each use shall not exceed 1.

Accessory Occupancy Classification: None in scope of work; no change to existing
Incidental Uses (Table 509): None in scope of work; no change to existing
Special Uses (Chapter 4 - List Code Sections): 403, 407 in scope. Other special uses may apply. No changes to existing.

Special Provisions (Chapter 5 - List Code Sections): None
Mixed Occupancy: ☐ No ☒ Yes Separation: Exception: Other occupancies not in scope
☒ Non-Separated Use (508.3)
The required type of construction for the building shall be determined by applying the height and area limitations for each of the applicable occupancies to the entire building. The most restrictive type of construction, so determined, shall apply to the entire building.

☒ Separated Use (508.4) - REF below for area calculations
For each story, the area of the occupancy shall be such that the sum of the ratios of the actual floor area of each use divided by the allowable floor area for each use shall not exceed 1.

Accessory Occupancy Classification: None in scope of work; no change to existing
Incidental Uses (Table 509): None in scope of work; no change to existing
Special Uses (Chapter 4 - List Code Sections): 403, 407 in scope. Other special uses may apply. No changes to existing.

Special Provisions (Chapter 5 - List Code Sections): None
Mixed Occupancy: ☐ No ☒ Yes Separation: Exception: Other occupancies not in scope
☒ Non-Separated Use (508.3)
The required type of construction for the building shall be determined by applying the height and area limitations for each of the applicable occupancies to the entire building. The most restrictive type of construction, so determined, shall apply to the entire building.

☒ Separated Use (508.4) - REF below for area calculations
For each story, the area of the occupancy shall be such that the sum of the ratios of the actual floor area of each use divided by the allowable floor area for each use shall not exceed 1.

Accessory Occupancy Classification: None in scope of work; no change to existing
Incidental Uses (Table 509): None in scope of work; no change to existing
Special Uses (Chapter 4 - List Code Sections): 403, 407 in scope. Other special uses may apply. No changes to existing.

Special Provisions (Chapter 5 - List Code Sections): None
Mixed Occupancy: ☐ No ☒ Yes Separation: Exception: Other occupancies not in scope
☒ Non-Separated Use (508.3)
The required type of construction for the building shall be determined by applying the height and area limitations for each of the applicable occupancies to the entire building. The most restrictive type of construction, so determined, shall apply to the entire building.

☒ Separated Use (508.4) - REF below for area calculations
For each story, the area of the occupancy shall be such that the sum of the ratios of the actual floor area of each use divided by the allowable floor area for each use shall not exceed 1.

Accessory Occupancy Classification: None in scope of work; no change to existing
Incidental Uses (Table 509): None in scope of work; no change to existing
Special Uses (Chapter 4 - List Code Sections): 403, 407 in scope. Other special uses may apply. No changes to existing.

Special Provisions (Chapter 5 - List Code Sections): None
Mixed Occupancy: ☐ No ☒ Yes Separation: Exception: Other occupancies not in scope
☒ Non-Separated Use (508.3)
The required type of construction for the building shall be determined by applying the height and area limitations for each of the applicable occupancies to the entire building. The most restrictive type of construction, so determined, shall apply to the entire building.

☒ Separated Use (508.4) - REF below for area calculations
For each story, the area of the occupancy shall be such that the sum of the ratios of the actual floor area of each use divided by the allowable floor area for each use shall not exceed 1.

Accessory Occupancy Classification: None in scope of work; no change to existing
Incidental Uses (Table 509): None in scope of work; no change to existing
Special Uses (Chapter 4 - List Code Sections): 403, 407 in scope. Other special uses may apply. No changes to existing.

Special Provisions (Chapter 5 - List Code Sections): None
Mixed Occupancy: ☐ No ☒ Yes Separation: Exception: Other occupancies not in scope
☒ Non-Separated Use (508.3)
The required type of construction for the building shall be determined by applying the height and area limitations for each of the applicable occupancies to the entire building. The most restrictive type of construction, so determined, shall apply to the entire building.

☒ Separated Use (508.4) - REF below for area calculations
For each story, the area of the occupancy shall be such that the sum of the ratios of the actual floor area of each use divided by the allowable floor area for each use shall not exceed 1.

Accessory Occupancy Classification: None in scope of work; no change to existing
Incidental Uses (Table 509): None in scope of work; no change to existing
Special Uses (Chapter 4 - List Code Sections): 403, 407 in scope. Other special uses may apply. No changes to existing.

Special Provisions (Chapter 5 - List Code Sections): None
Mixed Occupancy: ☐ No ☒ Yes Separation: Exception: Other occupancies not in scope
☒ Non-Separated Use (508.3)
The required type of construction for the building shall be determined by applying the height and area limitations for each of the applicable occupancies to the entire building. The most restrictive type of construction, so determined, shall apply to the entire building.

☒ Separated Use (508.4) - REF below for area calculations
For each story, the area of the occupancy shall be such that the sum of the ratios of the actual floor area of each use divided by the allowable floor area for each use shall not exceed 1.

Accessory Occupancy Classification: None in scope of work; no change to existing
Incidental Uses (Table 509): None in scope of work; no change to existing
Special Uses (Chapter 4 - List Code Sections): 403, 407 in scope. Other special uses may apply. No changes to existing.

Special Provisions (Chapter 5 - List Code Sections): None
Mixed Occupancy: ☐ No ☒ Yes Separation: Exception: Other occupancies not in scope
☒ Non-Separated Use (508.3)
The required type of construction for the building shall be determined by applying the height and area limitations for each of the applicable occupancies to the entire building. The most restrictive type of construction, so determined, shall apply to the entire building.

☒ Separated Use (508.4) - REF below for area calculations
For each story, the area of the occupancy shall be such that the sum of the ratios of the actual floor area of each use divided by the allowable floor area for each use shall not exceed 1.

FIRE PROTECTION REQUIREMENTS

BUILDING ELEMENT	FIRE SEPARATION DISTANCE (FEET)	RATING REQUIRED (HRL)	PROVIDED (HRL - REDUCTION)	DETAIL # AND SHEET #	DESIGN # FOR RATED ASSEMBLY	SHEET # FOR RATED PENETRATION	SHEET # FOR RATED JOINTS
Structural frame, Including columns, girders, trusses		3 HR	ETR				
Bearing walls		3 HR	ETR				
Exterior							
North	X ≥ 30						
East	X ≥ 30						
West	X ≥ 30						
South	X ≥ 30						
Interior							
Nonbearing Walls and Partitions							
Exterior		0 HR	ETR				
North	X ≥ 30						
East	X ≥ 30						
West	X ≥ 30						
South	X ≥ 30						
Interior walls and partitions		0 HR	0 HR	A001			
Floor construction Including supporting beams and joists		2 HR	ETR				
Floor Ceiling Assembly							
Columns Supporting Floors							
Roof construction Including supporting beams and joists		1.5 HR	ETR				
Roof Ceiling Assembly							
Columns Supporting Roof							
Shafts Enclosures - Exit		2 HR	ETR				
Shafts Enclosures - Other		2 HR	ETR				
Corridor Separation		SMOKE	ETR				
Occupancy/Fire Barrier Separation		2 HR	ETR				
Party/Fire Wall Separation		3 HR	ETR				
Smoke Barrier Separation		1 HR	ETR				
Smoke Partition		N/A	N/A				
Tenant/Dwelling Unit Sleeping Unit Separation		N/A	N/A				
Incidental Use Separation		1 HR	ETR				

*Indicate section permitting reduction:

Life Safety Plan Sheet # -

Life Safety Plan Sheet # -

LIFE SAFETY PLAN REQUIREMENTS

Life Safety Plan Sheet # -

Life Safety Plan Sheet # -

RATING LEGEND

	BUILDING SEPARATION
NCB (000-000-000)	3 HR & 4 HR FIRE WALL SEPARATION (NCBC SECTION 706)
NCB 250-000-000	2 HR FIRE BARRIER (NCBC SECTION 707)
NCB 250-171-351	2 HR FIRE/SMOKE BARRIER (NCBC SECTION 407.5/708)
NCB 111-003-102	1 HR FIRE BARRIER (NCBC SECTION 707)
NCB 100-000-000.55	1 HR FIRE/SMOKE BARRIER (NCBC SECTION 407.5/709)
NCB 165-164-082	1 HR FIRE PARTITION (NCBC SECTION 708)
NCB 100-025-324	SMOKE PARTITION (NCBC SECTION 407/710)
NCB 000-025-000	SUITE BOUNDARY (NCBC SECTION 407.4.2.2/710)

AREAS

	CHUTES/ACCESS/DISCHARGE
	HAZARDOUS AREA (NFPA 101 18.3.2.1)
	SLEEPING SUITE (NCBC 407.4.4.5)
	NON-SLEEPING SUITE (NCBC 407.4.4.6)
	NON-PATIENT SUITE (NCBC 407.4.4.6)
	2 HR FLOOR/CEILING ABOVE
	1 HR FLOOR/CEILING ABOVE
	NOT IN SCOPE

EGRESS COMPONENTS

 EXIT (NCBC 1022)
 HORIZONTAL EXIT (NCBC 1026)
 EXIT DISCHARGE (NCBC 1028)

AREA OCCUPANCY TAG(S)

ASSEMBLY ← OCCUPANCY TYPE

45	2200
	96

 ← AREA SQ. FT.
 ← OCCUPANT LOAD FACTOR (NCBC TABLE 1004.1.2)
 ← CALCULATED OCCUPANCY LOAD

DOOR EGRESS TAG

Diagram illustrating the components and specifications of a fire alarm pull station:

- EXIT OCCUPANT LOAD
- EXIT CLEAR WIDTH
- EGRESS CAPACITY
- FIRE RATING
- PH PANIC HARDWARE (NCBC 1010.1.10)
- DE-X DELAYED EGRESS; DELAY X SECONDS (NCBC 1010.1.9.7)
- HL ELECTROMAGNETIC EGRESS LOCK (NCBC 1010.1.9.9)
- HQ HQL D-OPFN DEVICE

EGRESS PATH(S)

EXIT ACCESS : 86'-10"
200' ALLOWED

EXIT ACCESS (NCBC 1017)

COMMON PATH : 15'-10"

COMMON PATH (NCBC TABLE 1006.2.1)

FIRE EXTINGUISHERS

Diagram illustrating the types of fire extinguishers and their mounting options:

- FIRE EXTINGUISHER
- SURFACE MOUNTED
- SEMI-RECESSED
- RECESSED

EXIT SIGNS

Diagram illustrating the mounting options for the device:

- CEILING MOUNTED
- WALL MOUNTED
- DIRECTION ARROWS (WHEN SHOWN)

NOTE:

1. THIS SHEET RELIES ON COLOR TO CONVEY INFORMATION. REPRODUCTION WITHOUT COLOR WILL RESULT IN LOSS OF INFORMATION. THE CONTRACTOR IS RESPONSIBLE FOR OBTAINING AND USING DOCUMENTS IN A FORMAT THAT FULLY REPRESENTS THE INFORMATION PROVIDED BY THE ORIGINAL, OR PROPERLY MODIFIED, CONTRACT DOCUMENTS.

 
2. THIS SHEET HAS BEEN CREATED FROM THE OWNER'S BARRIER MANAGEMENT PLANS AND HAS BEEN MODIFIED ONLY FOR THE SCOPE OF THIS PROJECT. REVIEW ALL DIFFERENCES FOR AREAS NOT IN CONTRACT TO THE ARCHITECT AND OWNER.

3. STENCIL OR MECHANICALLY FASTEN LABELS TO THE WALL ABOVE CEILINGS WITH THE FOLLOWING DESCRIPTIONS AS APPLICABLE IN 3 MINUTE LETTERS.

- A 1 HOUR FIRE RESISTANT SMOKE PARTITION - PROTECT OPENINGS
- B 1 HOUR FIRE BARRIER - PROTECT ALL OPENINGS
- C 1 HOUR FIRE SMOKE BARRIER - PROTECT ALL OPENINGS
- D 1 HOUR FIRE BARRIER - PROTECT ALL OPENINGS
- E 1 HOUR FIRE SMOKE BARRIER - PROTECT ALL OPENINGS
- F 1 HOUR FIRE WALL - PROTECT ALL OPENINGS
- G 1 HOUR FIRE WALL - PROTECT ALL OPENINGS
- H 1 HOUR FIRE WALL - PROTECT ALL OPENINGS

G104

PROJECT & CONSTRUCTION MANAGEMENT
1400 East Morehead St.
Charlotte, NC 28204



- A. DO NOT SCALE DRAWINGS. CLARIFY ANY DIMENSIONAL DISCREPANCIES WITH THE ARCHITECT PRIOR TO CONTINUING WORK.
- B. CLARIFY ANY COORDINATION DISCREPANCIES BETWEEN DRAWINGS WITH ARCHITECT PRIOR TO CONTINUING WORK.
- C. FIELD VERIFY ALL DIMENSIONS AND NOTIFY ARCHITECT OF ANY DISCREPANCIES PRIOR TO CONTINUING WORK.
- D. DURING CONSTRUCTION, MAINTAIN AND ADEQUATE FIRE TREATED WOOD BLOCKING.
- E. FIELD VERIFY INTEGRITY OF ALL EXISTING RATED ASSEMBLIES TO REMAIN COMPLIANT WITH THE LIFE SAFETY PLANS.
- F. PROTECT ALL EXISTING EQUIPMENT, EXPANSION JOINT COVERS, AND FIXTURES WITHIN THE PROJECT AREA.

1 PTM WALL AND FLOOR FINISHES; REF INTERIORS

A. DO NOT SCALE DRAWINGS. CLARIFY ANY DIMENSIONAL DISCREPANCIES WITH ARCHITECT PRIOR TO CONTINUING WORK.

B. CLARIFY ANY COORDINATION DISCREPANCIES BETWEEN DRAWINGS WITH ARCHITECT PRIOR TO CONTINUING WORK.

C. FIELD VERIFY ALL DIMENSIONS AND NOTIFY ARCHITECT OF ANY DISCREPANCIES PRIOR TO CONTINUING WORK.

D. PROTECT ALL EXISTING EQUIPMENT, EXPANSION JOINT COVERS, AND FIXTURES WITH THE PROJECT AREA.

E. ALL ACoustING CEILING AREAS ARE ACT-1 UNO.

F. ALL CEILING ARE $8'0'' \times 4'0''$ UNO.

G. DO NOT INSTALL CEILING TILES LESS THAN $6'6''$ WIDE.

H. INSTALL CEILING TILES PER ASTM C340 CONFIRM INFORMATION FOR ANY LOCATIONS NOT GIVEN.

I. PROVIDE MOISTURE RESISTANT GP ON B1 IN ALL TOILET ROOMS WITH SHOWERS AND SHOWER STALLS. PROVIDE GROUTS PERM TO STRUCTURE ABOVE CEILING PLANE.

J. K. ADVISE ALL SUBSERS MUST BE AT LEAST $3/4''$ AWAY FROM RETURN DIFFUSERS AND EQUIPMENT SHOWN ON RCP IS FOR INTENT ONLY. REF. CUT SHEETS AND REVISIONS DRAWINGS FOR MORE INFORMATION.

L. CENTER ALL FIXTURES AND EQUIPMENT ON CEILING TILES UNO.

N. REF INTERIOR FINISH LEGEND FOR ALL CEILING FINISH INFORMATION.

1 EXISTING CEILING REMAINS UNCHANGED

ATRIUM HEALTH


ISSUE DATE:		7/15/2026
PHASE:		Construction Documents
SHEET ISSUE:		
NO.	DATE	DESCRIPTION

PRINCIPAL IN CHARGE: MS
PROJECT ARCHITECT: TAS
DRAWN BY: JRM

SHEET NAME:
DEMO AND NEW
PLANS - LEVEL 01 + 04

SHEET NO. PROJECT NUMBER:
JAZZID_14452
A/E PROJECT #:
02600404.00

A111

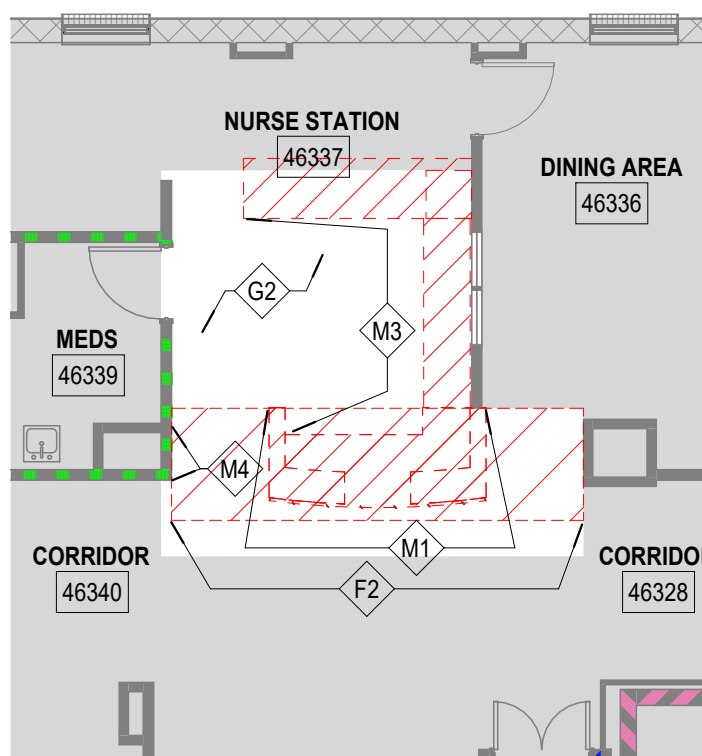


LEVEL 04 - AREA B - SR BH - DEMOLITION PLAN




LEVEL 01 - AREA C - BH 2 - NEW WORK PLAN




LEVEL 01 - AREA C - BH 2 - DEMOLITION PLAN

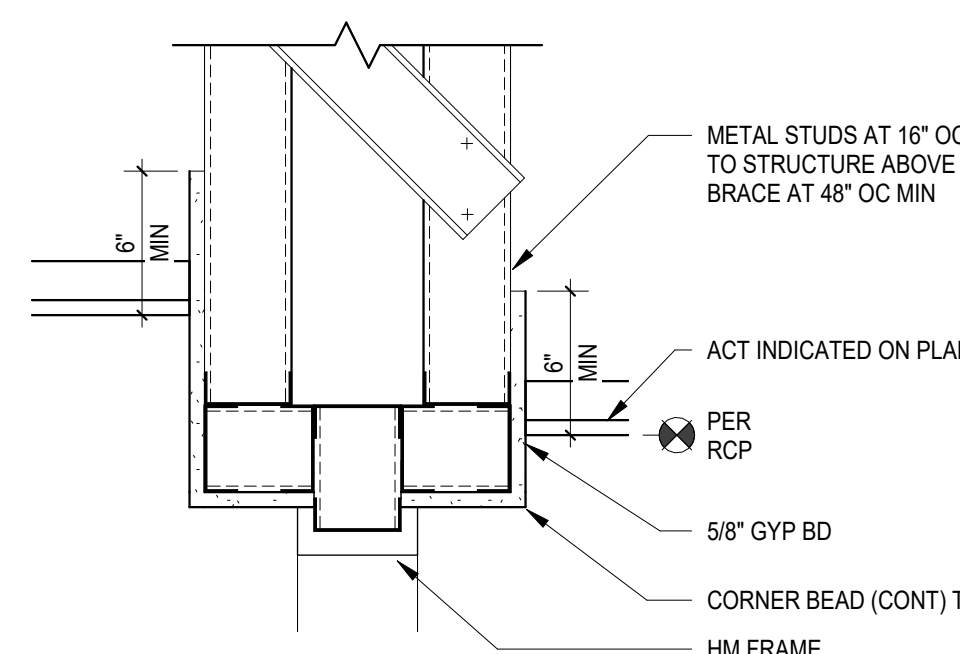
 $1\frac{1}{2}'' = 1'-0''$

KEY PLAN

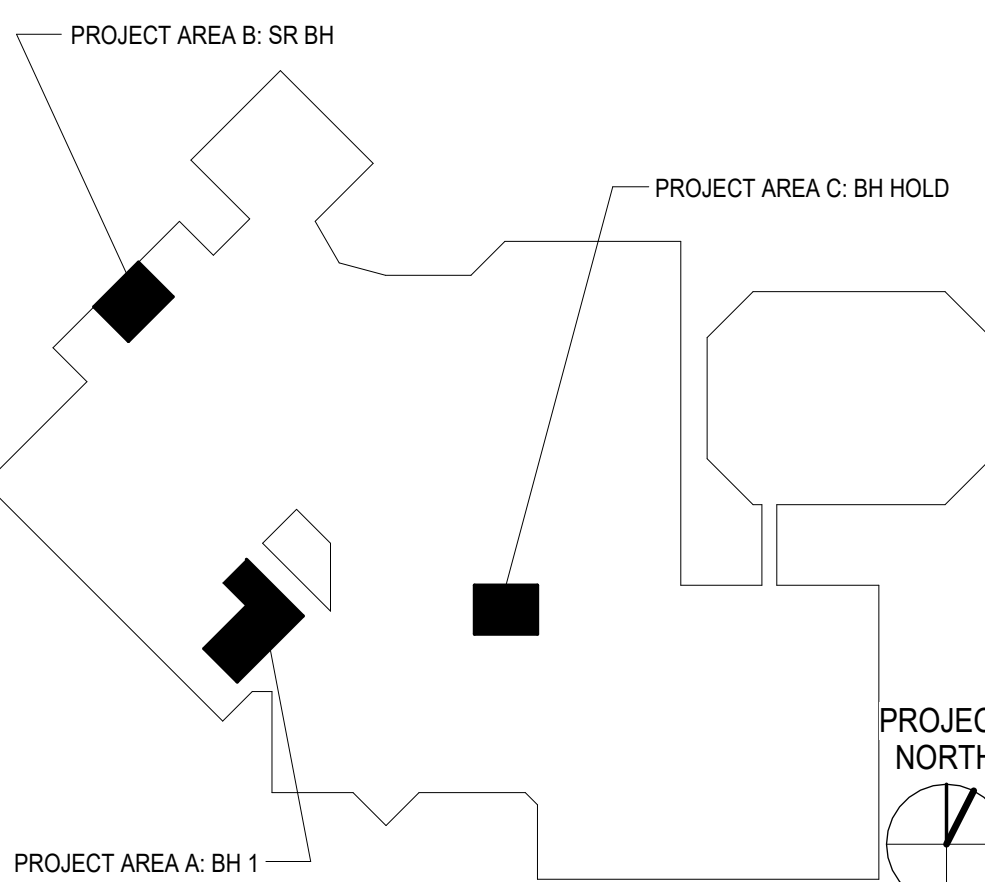
[illegible]

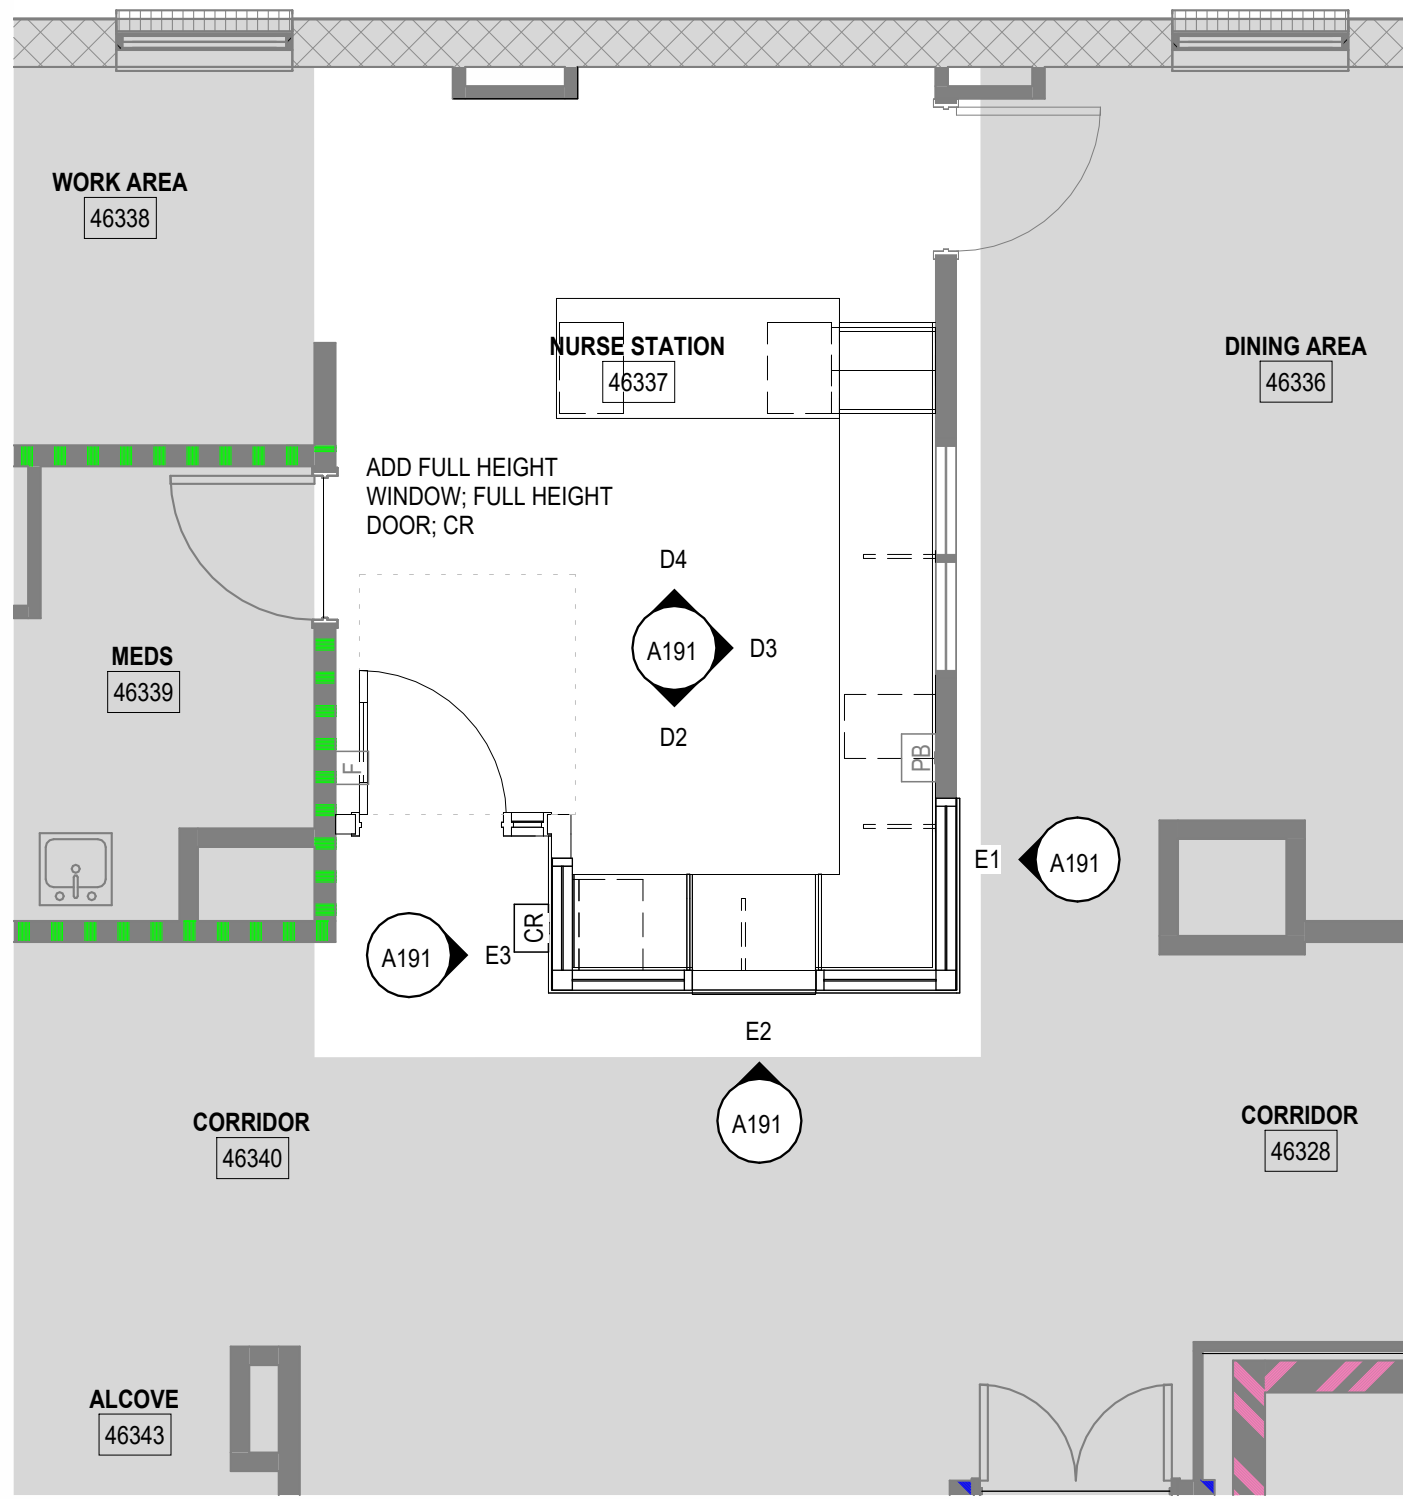


D5 LEVEL 04 - AREA B - SR BH - ENLARGED PLAN

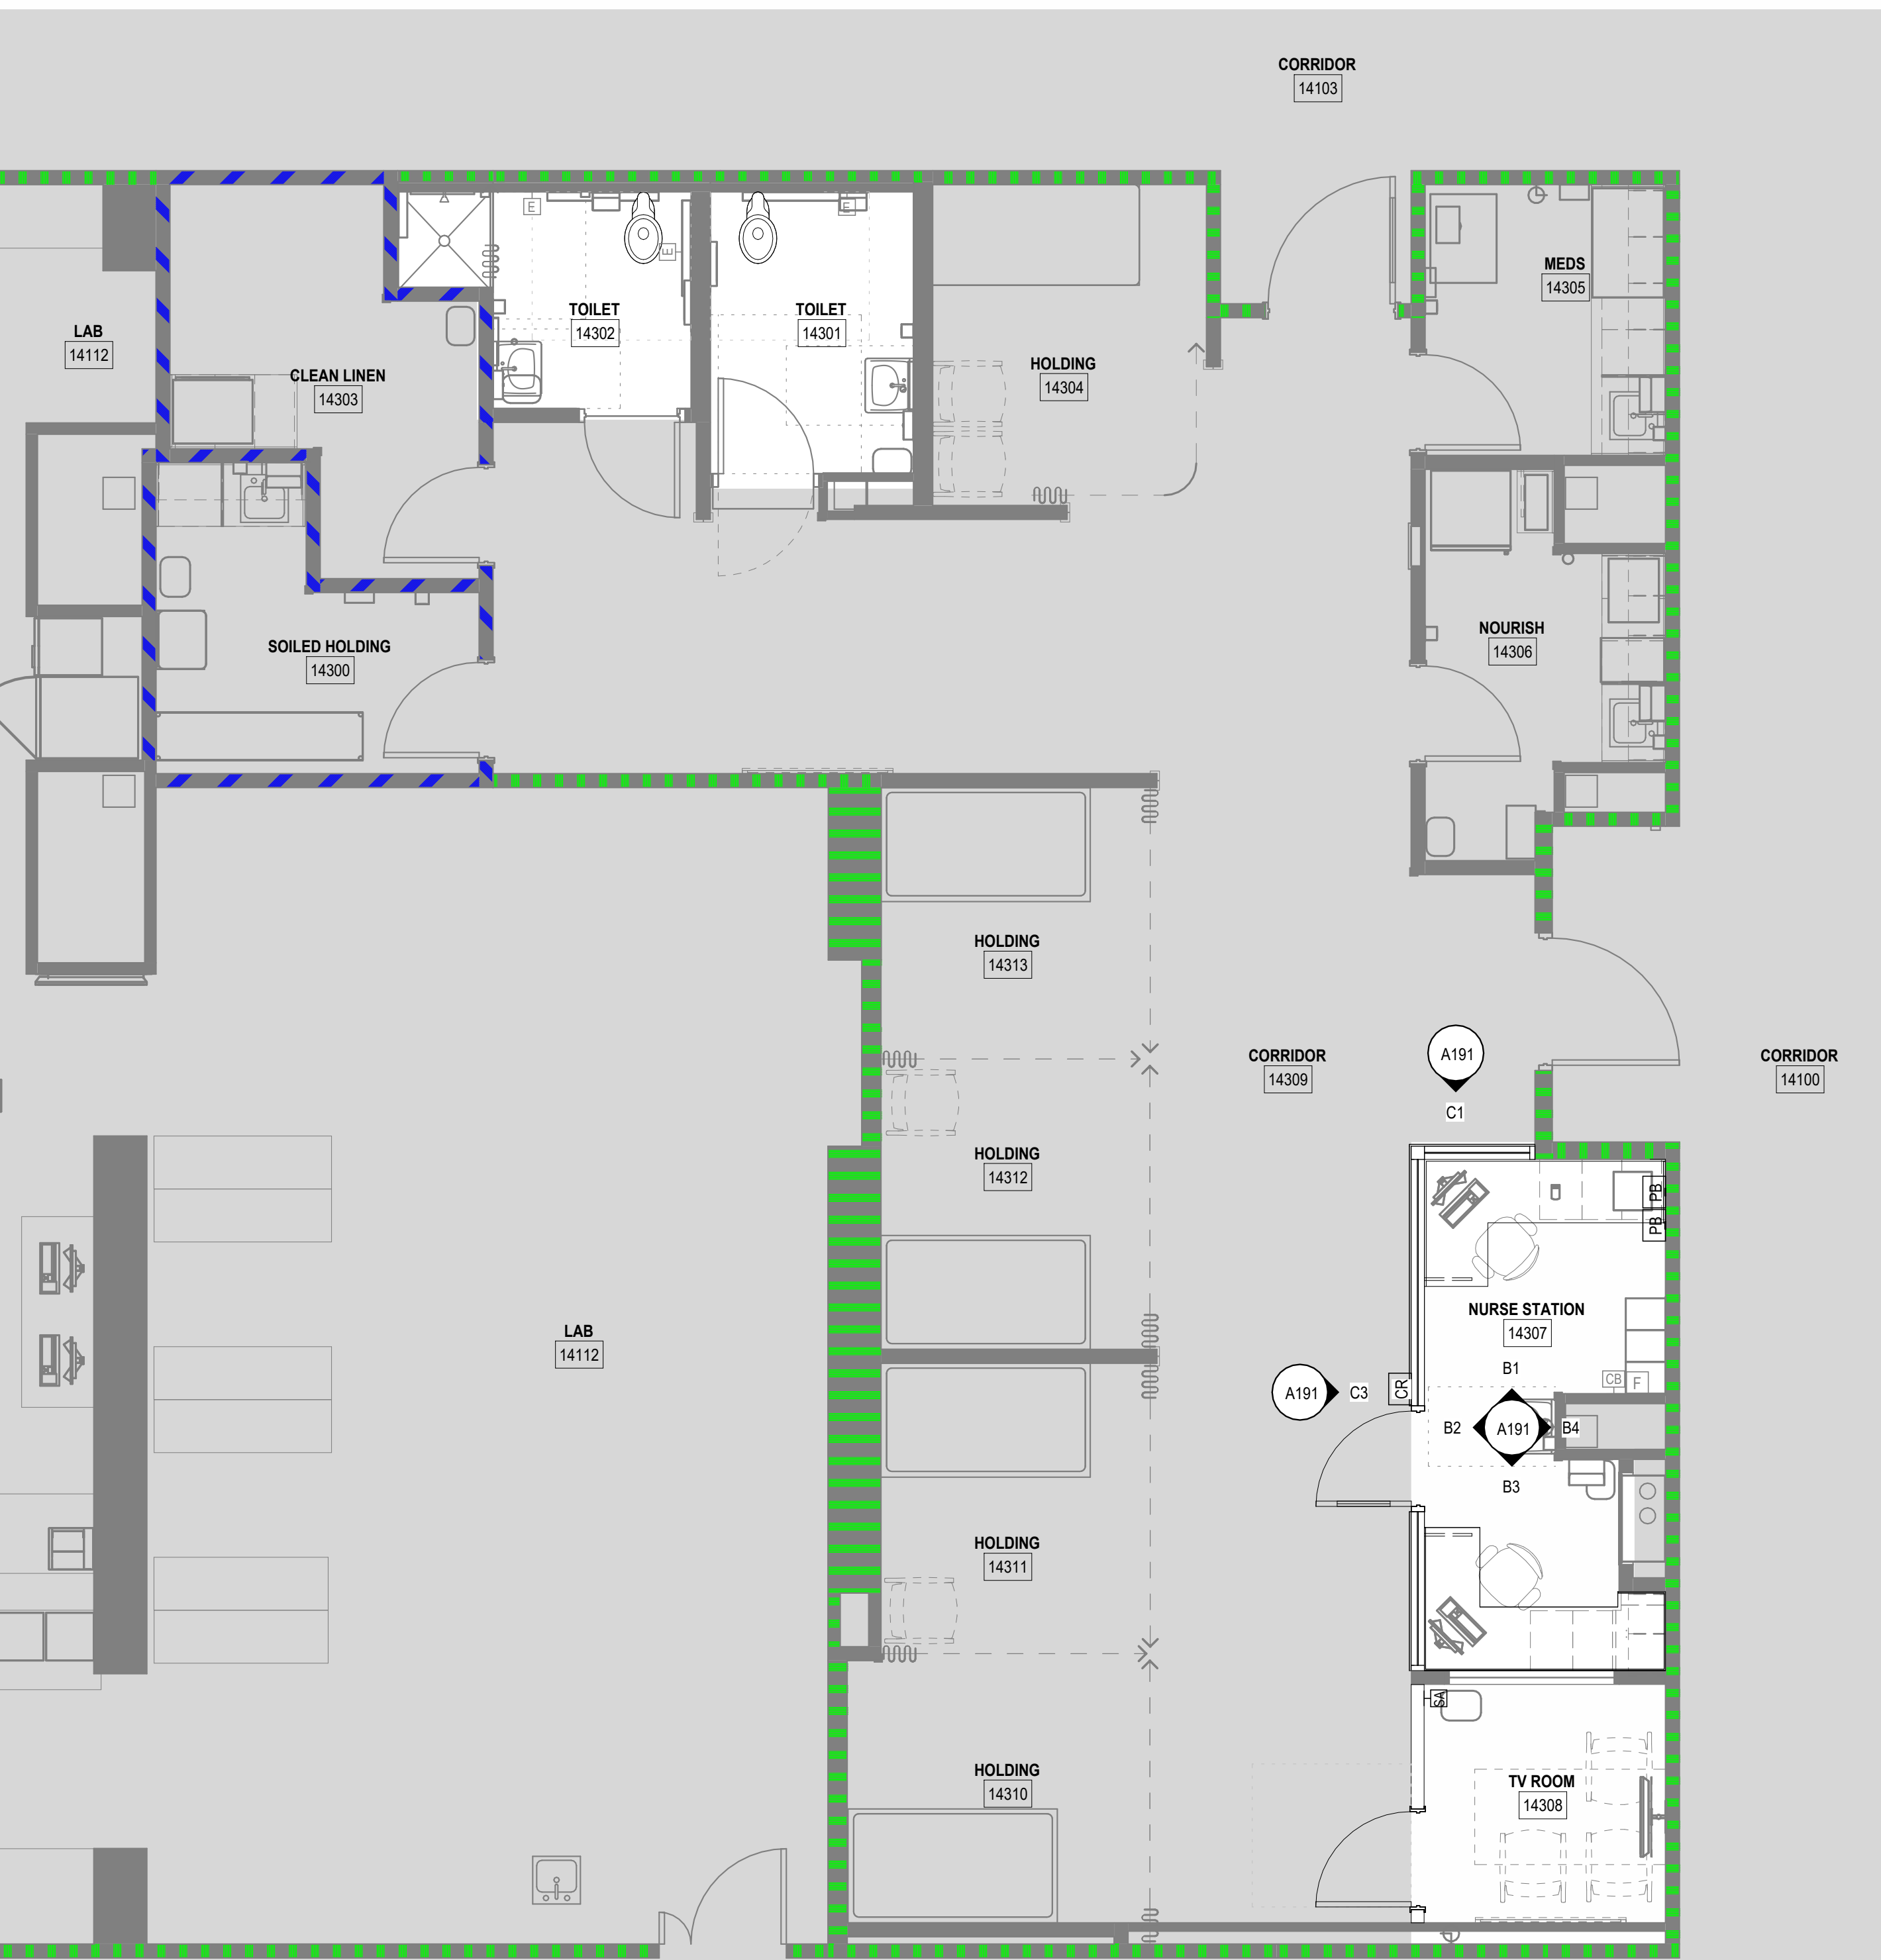


A1 LEVEL 01 - AREA A - BH 1 - EQUIPMENT PLAN

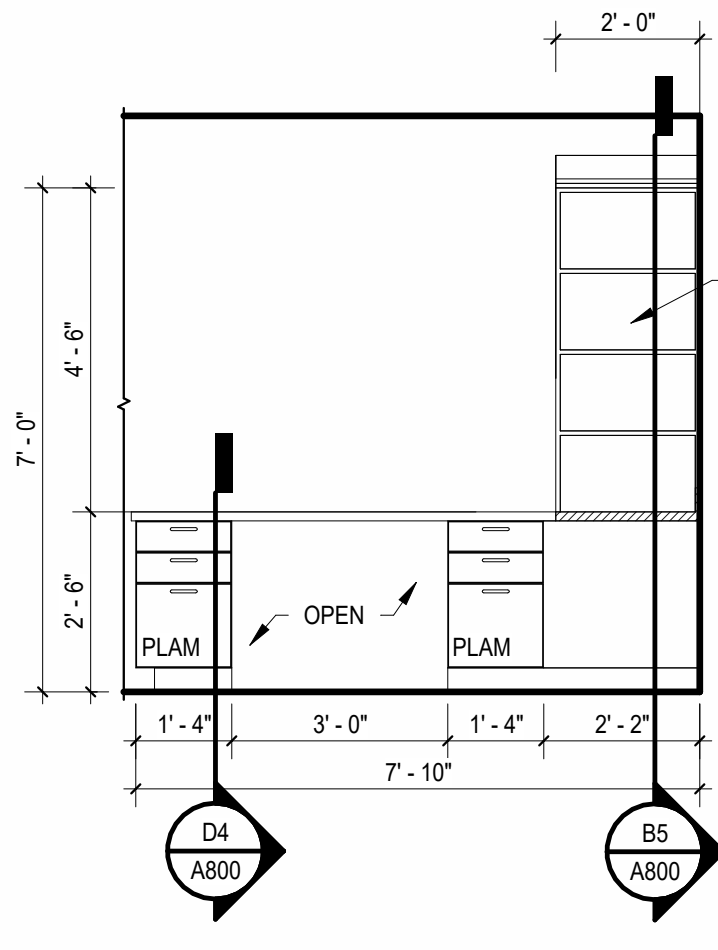


D4 46337 - SR BH NS - NORTH

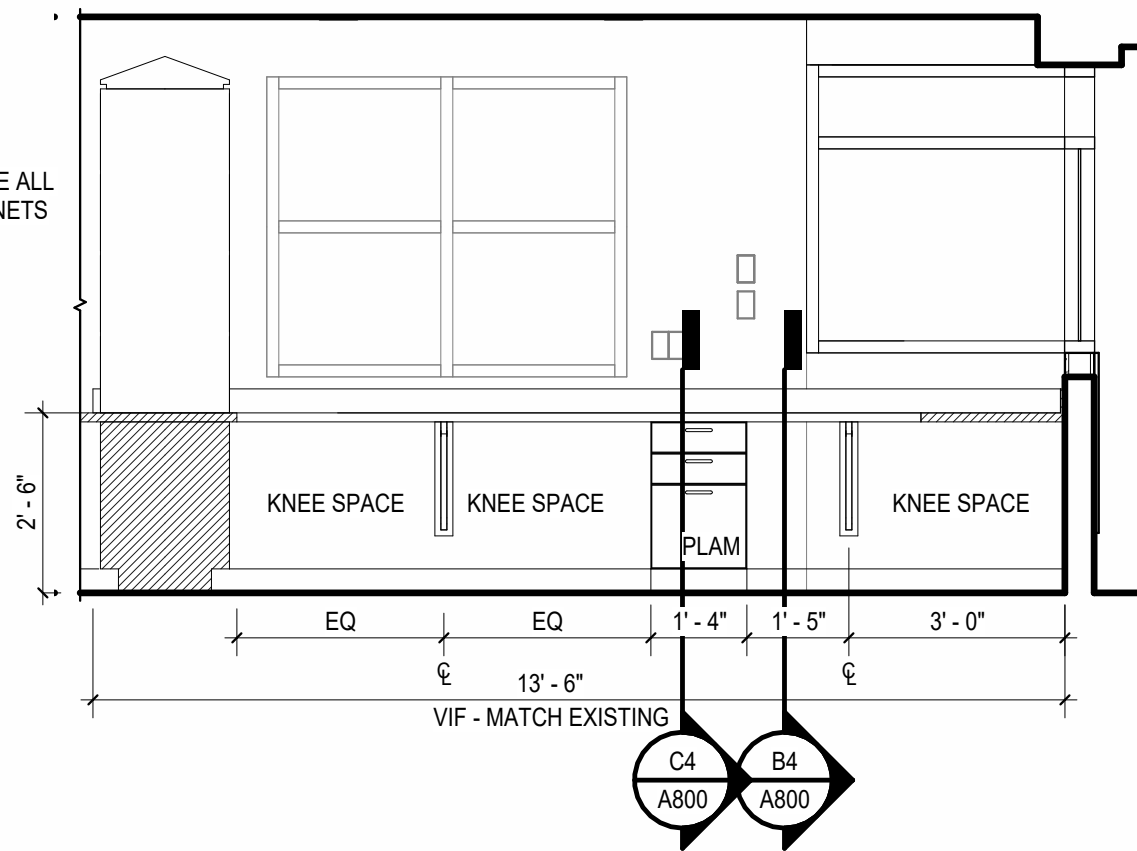


D3 46337 - SR BH NS - EAST

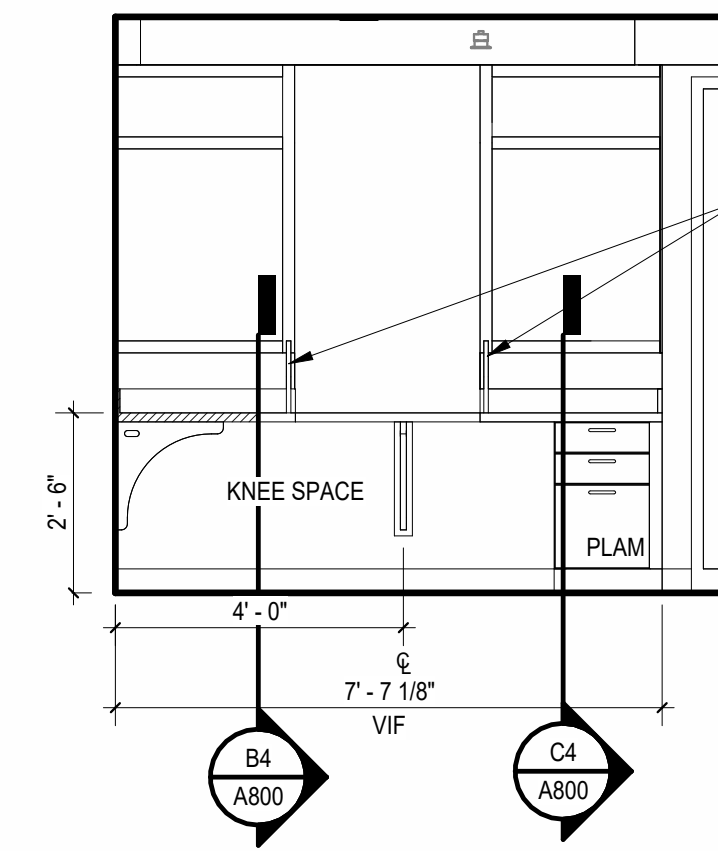


D2 46337 - SR BH NS - SOUTH

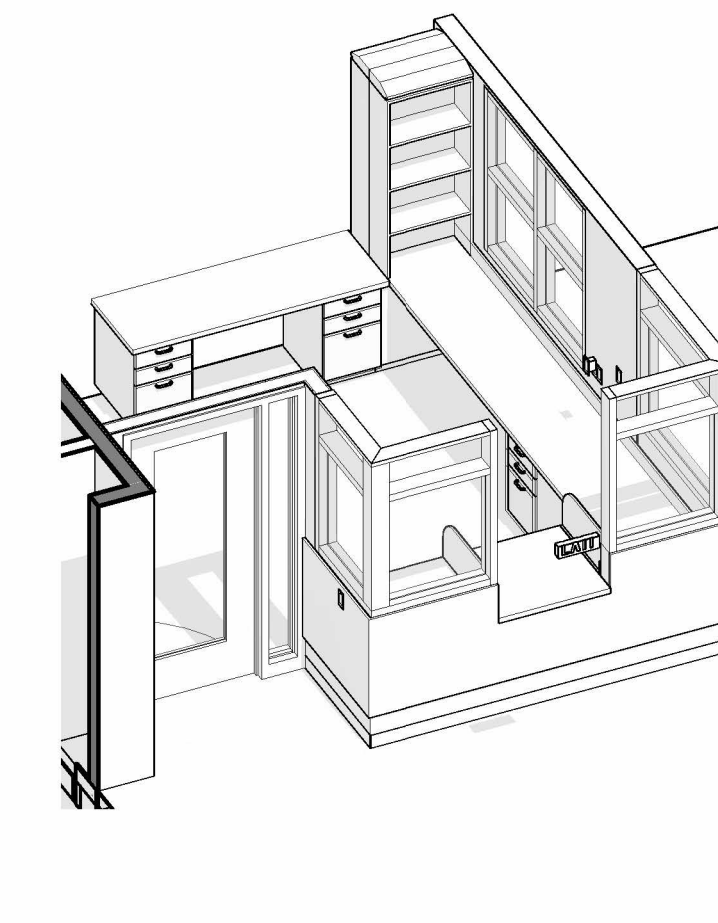


D1 AXON - SR BH NURSE STATION

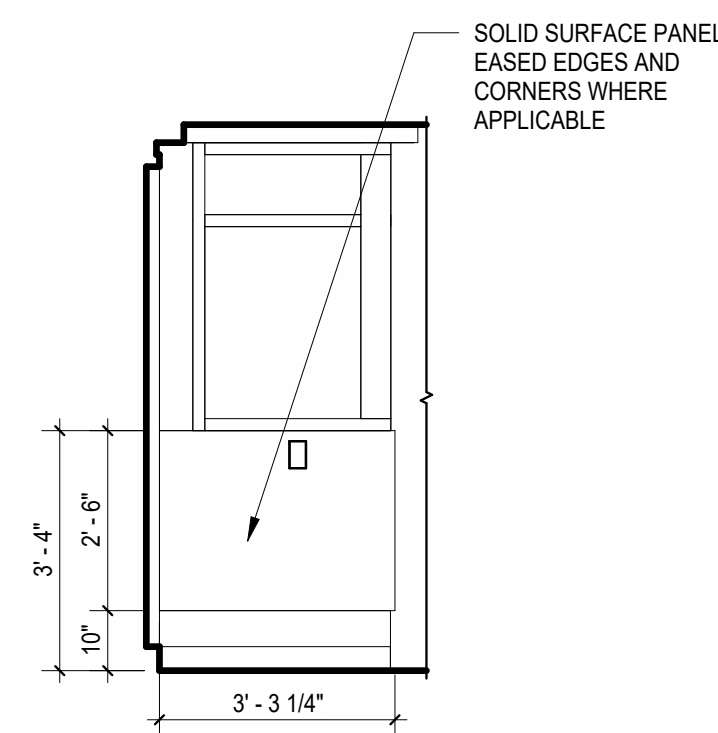


E3 46337 - SR BH NS EXTERIOR - EAST

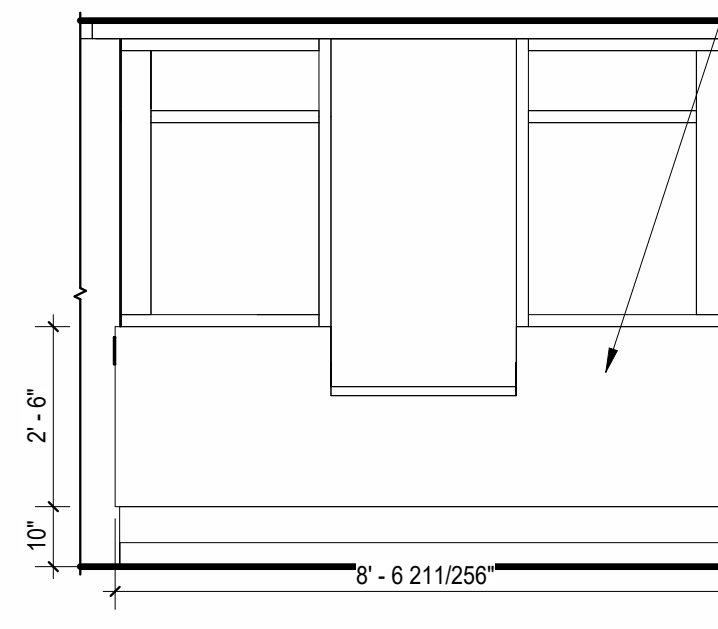


E2 46337 - SR BH NS EXTERIOR - NORTH

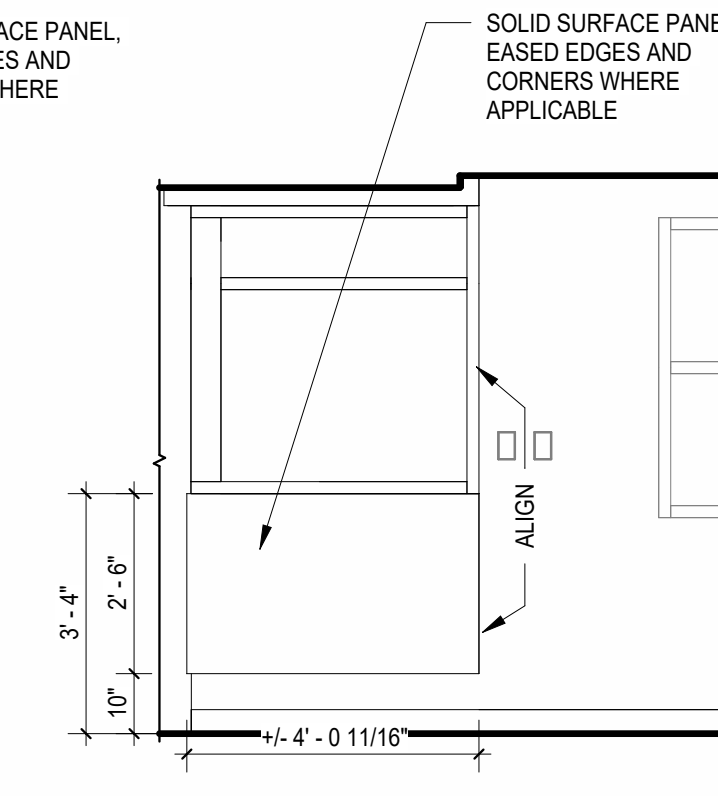


E1 46337 - SR BH EXTERIOR - WEST

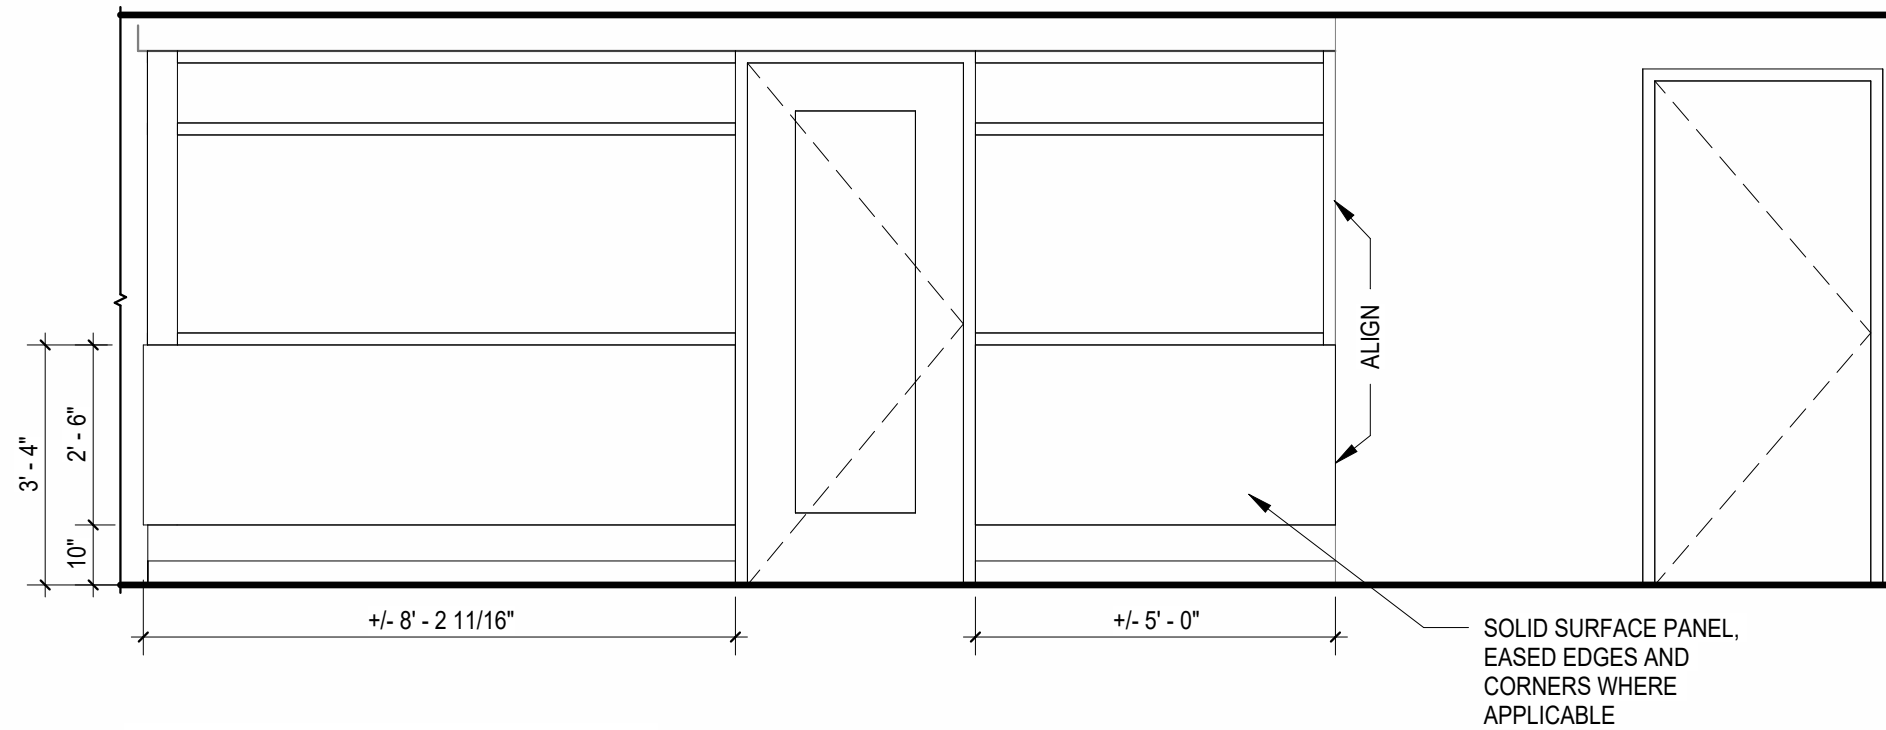


C3 14307 - BH1 NS EX - EAST

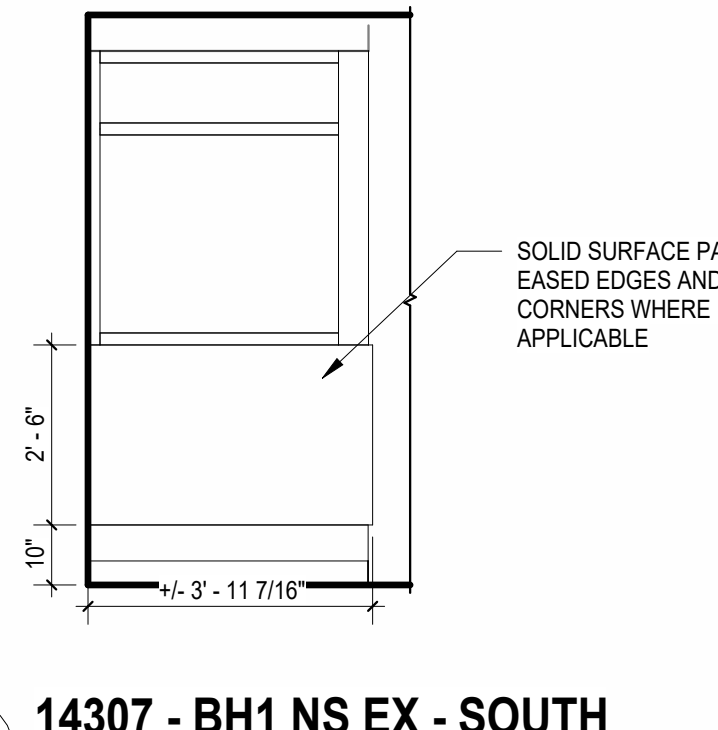


C1 14307 - BH1 NS EX - SOUTH

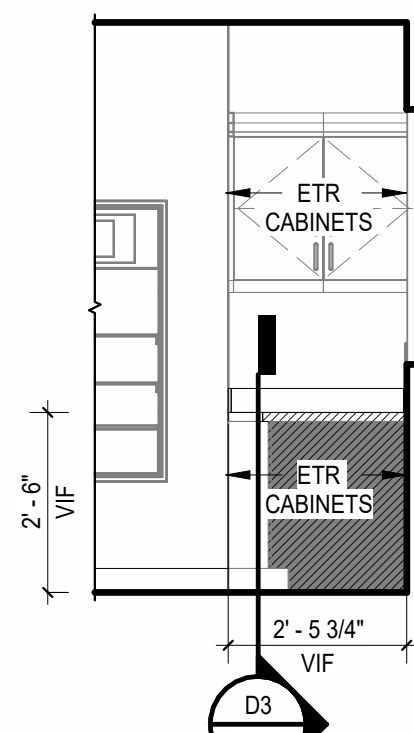


B4 14307 - BH 1 NS - EAST

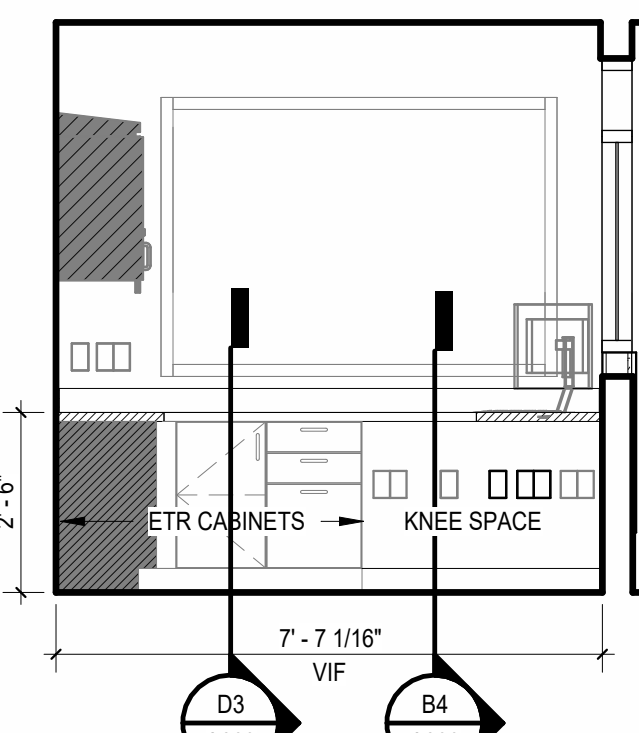


B3 14307 - BH 1 NS - SOUTH

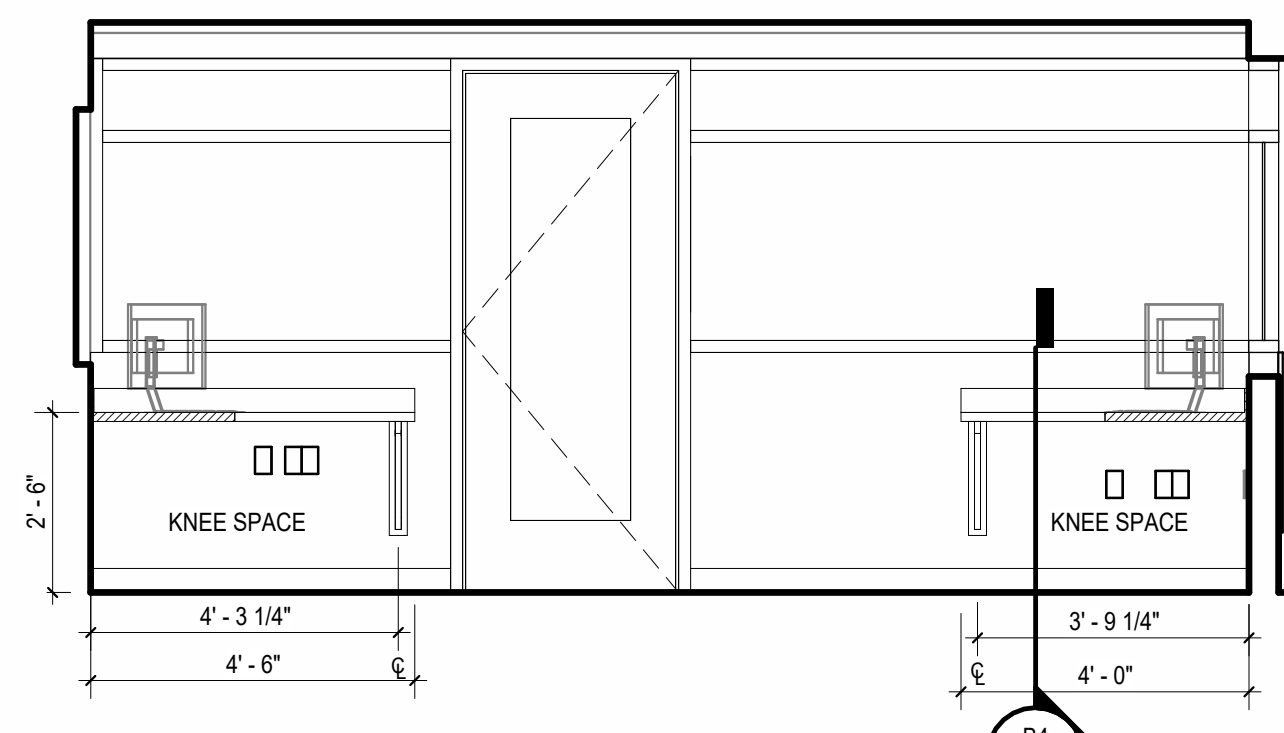

B2 14307 - BH 1 NS - WEST

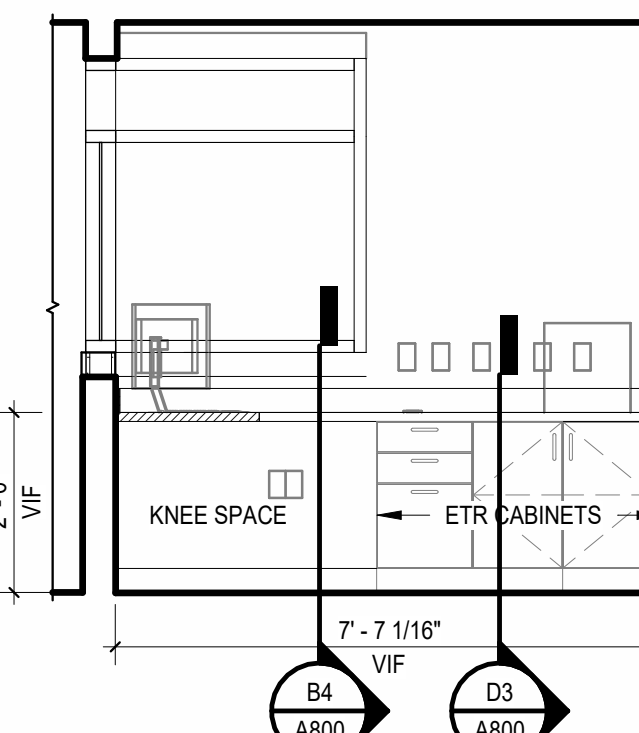


B1 14307 - BH 1 NS - NORTH

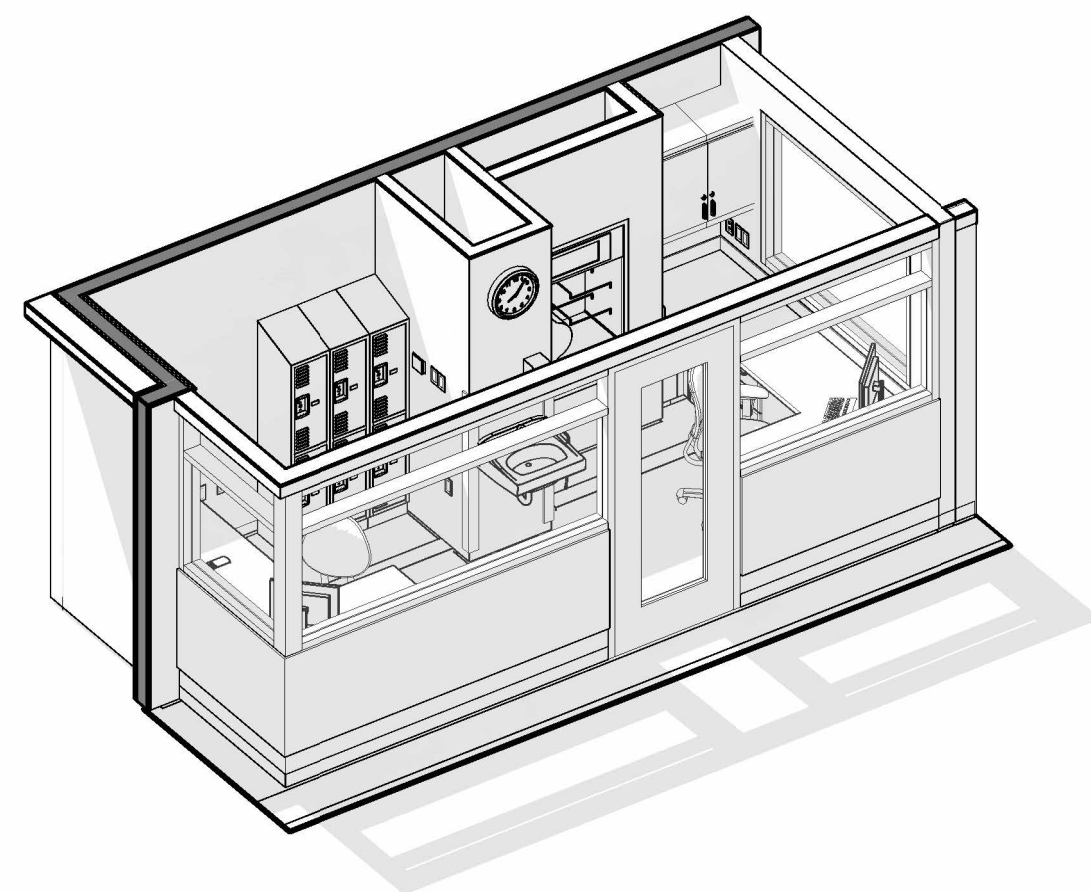


A4 AXON - BH 1 NURSE STATION


KEY PLAN

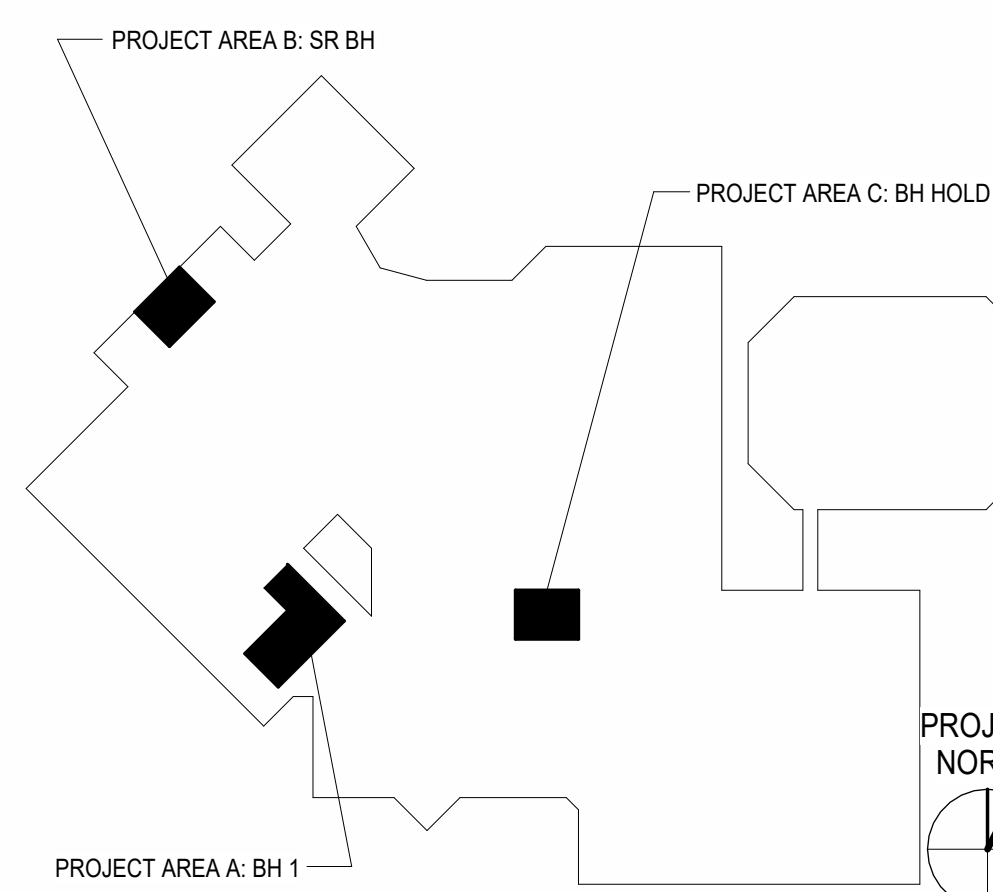

TYPICAL DOOR PLACEMENT

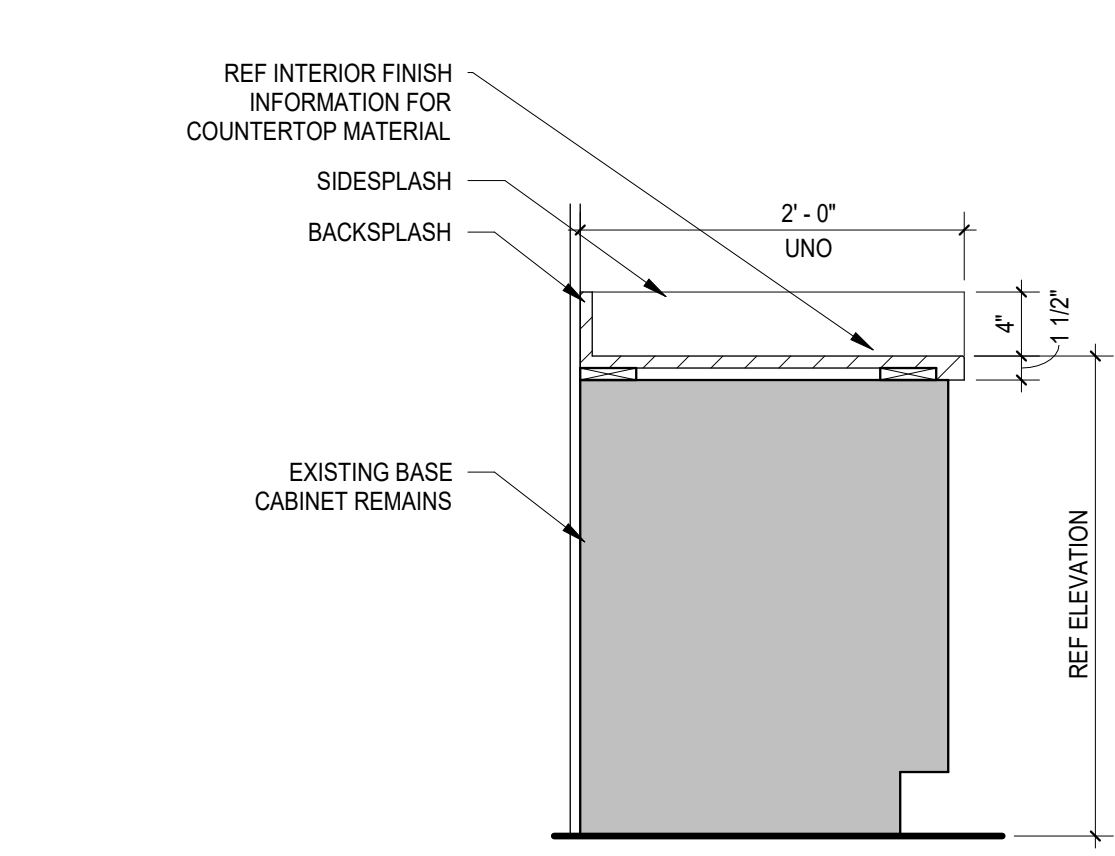


COUNTERTOP OVER EXISTING BASE CABINET

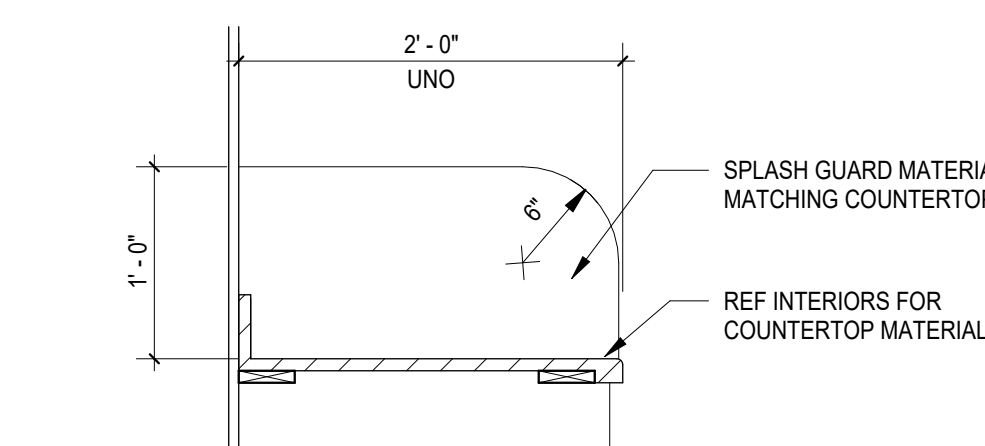

C3 TYPICAL SPLASH GUARD DETAIL




COUNTERTOP WITH PLAM SUPPORT

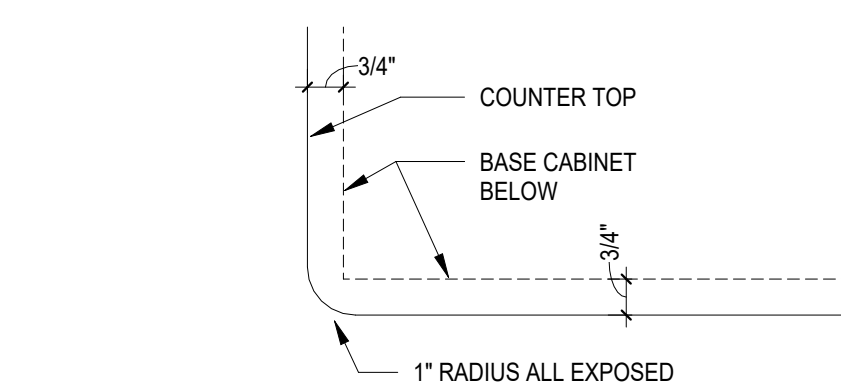


USE THIS DETAIL AT ALL EXPOSED COUNTERTOP CORNERS UNLESS NOTED OTHERWISE REGARDLESS OF SURFACE MATERIAL. PLAN DRAWINGS DO NOT ALWAYS SHOW A RADIUS AT THE CORNER BECUASE OF SCALE. THIS DETAIL NOT APPLICABLE WHERE COUNTERTOP CORNER BUTTS UP AGAINST A WALL.

TYPICAL COUNTER TOP CORNER PLAN DETAIL

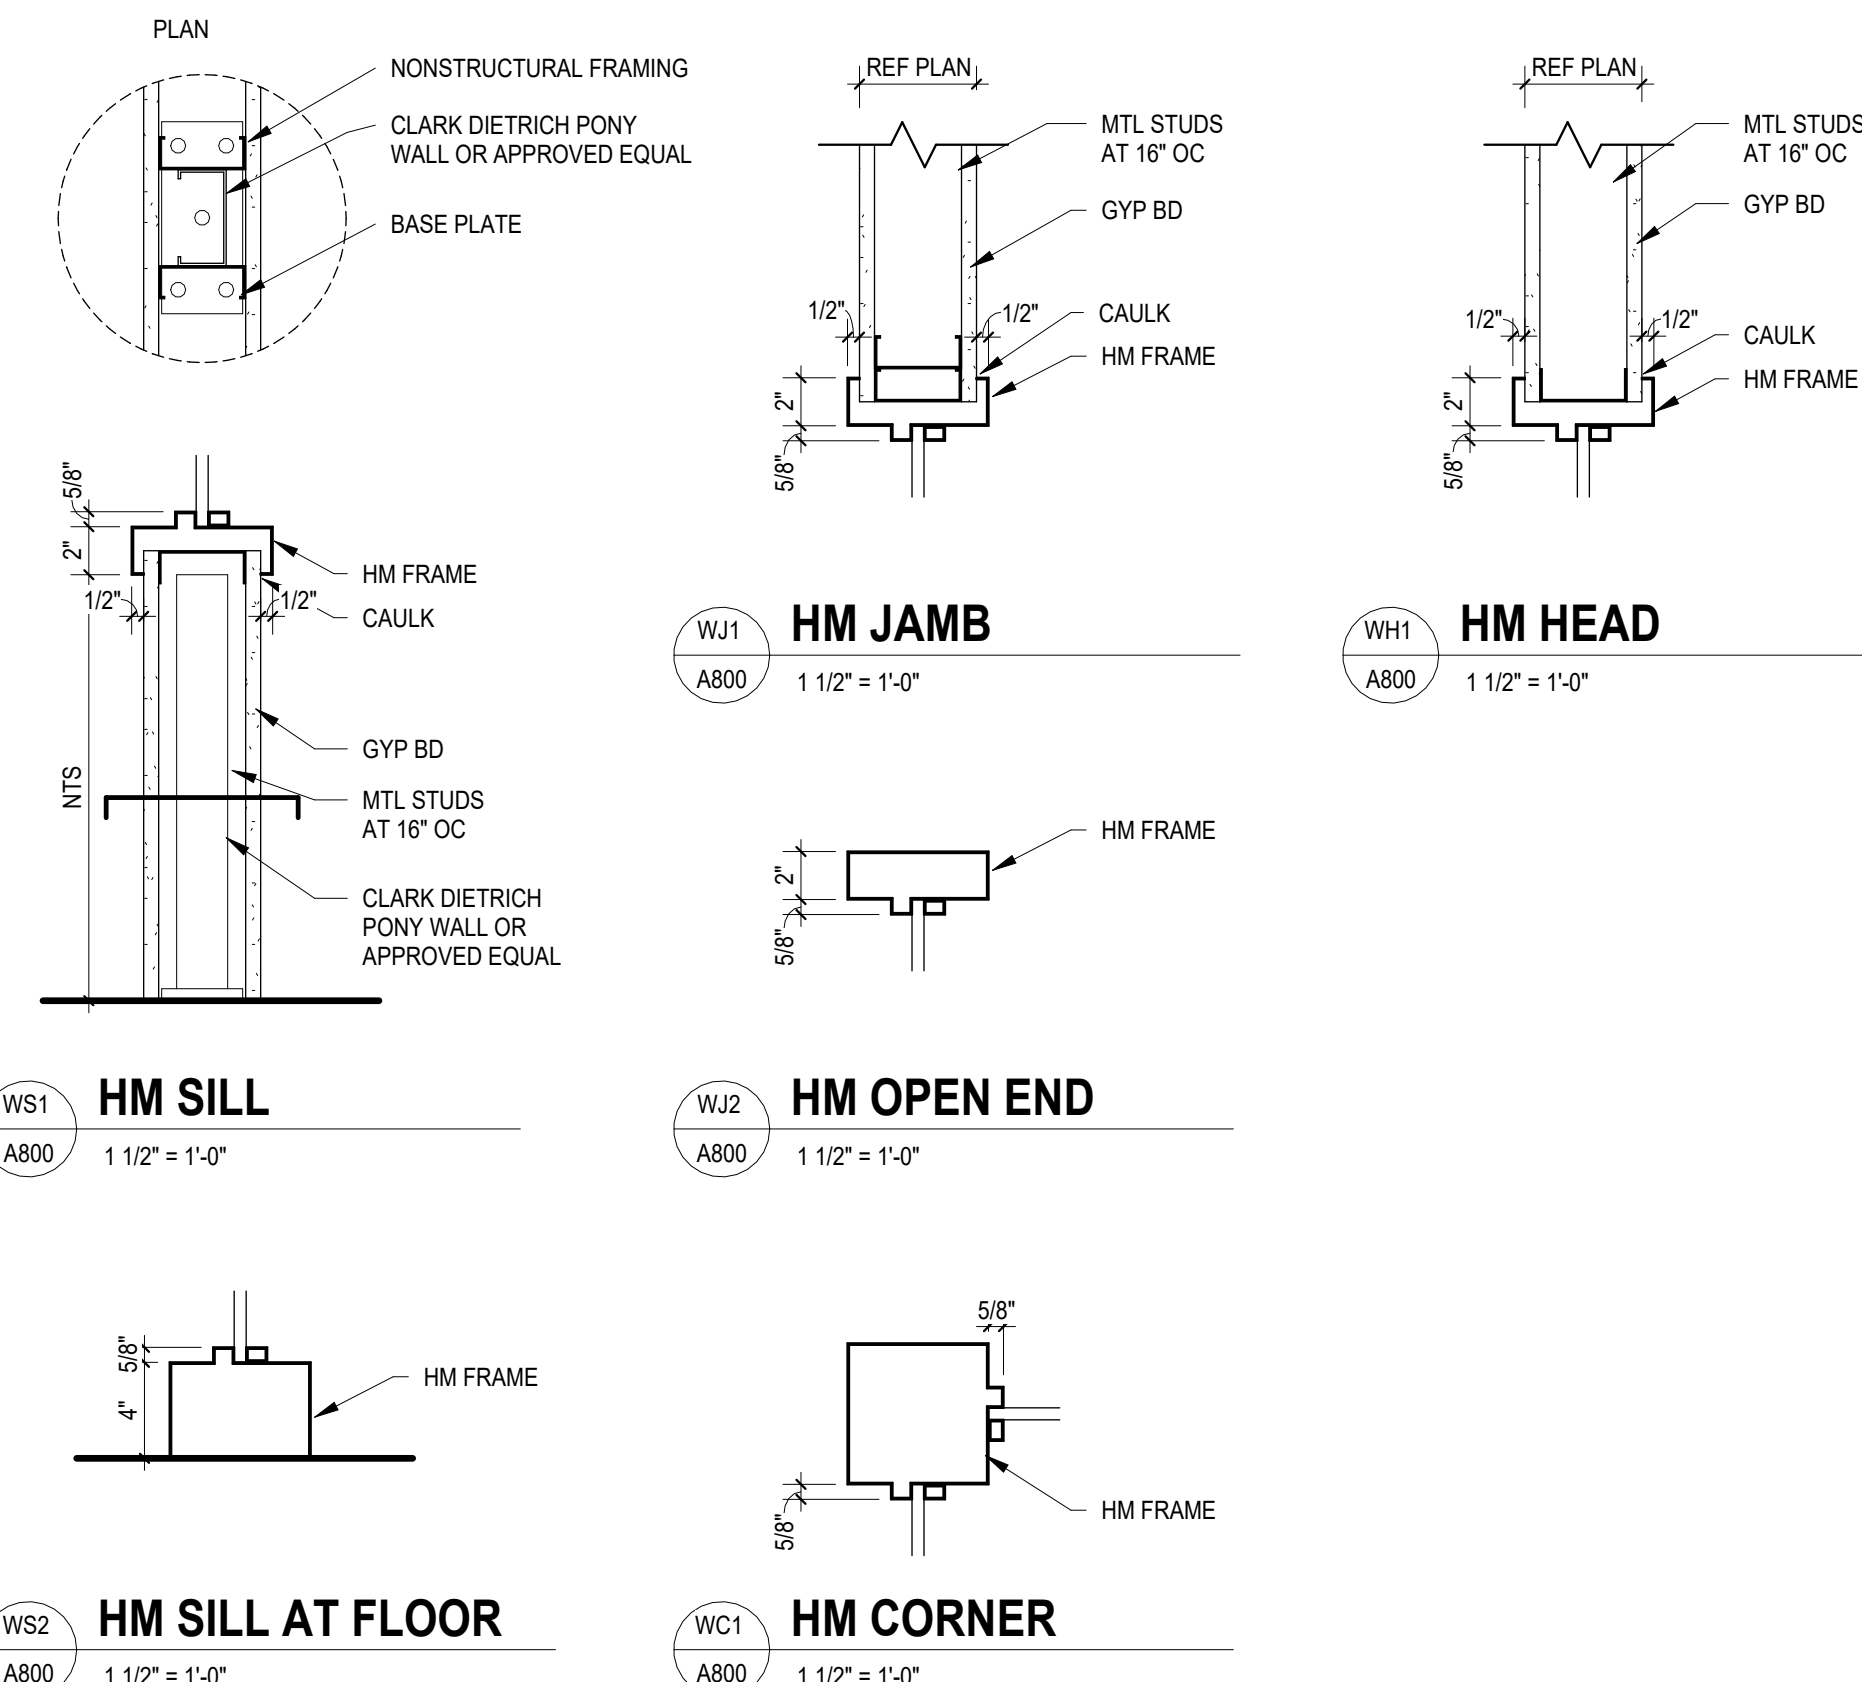


HM HEAD


WC1 HM CORNER

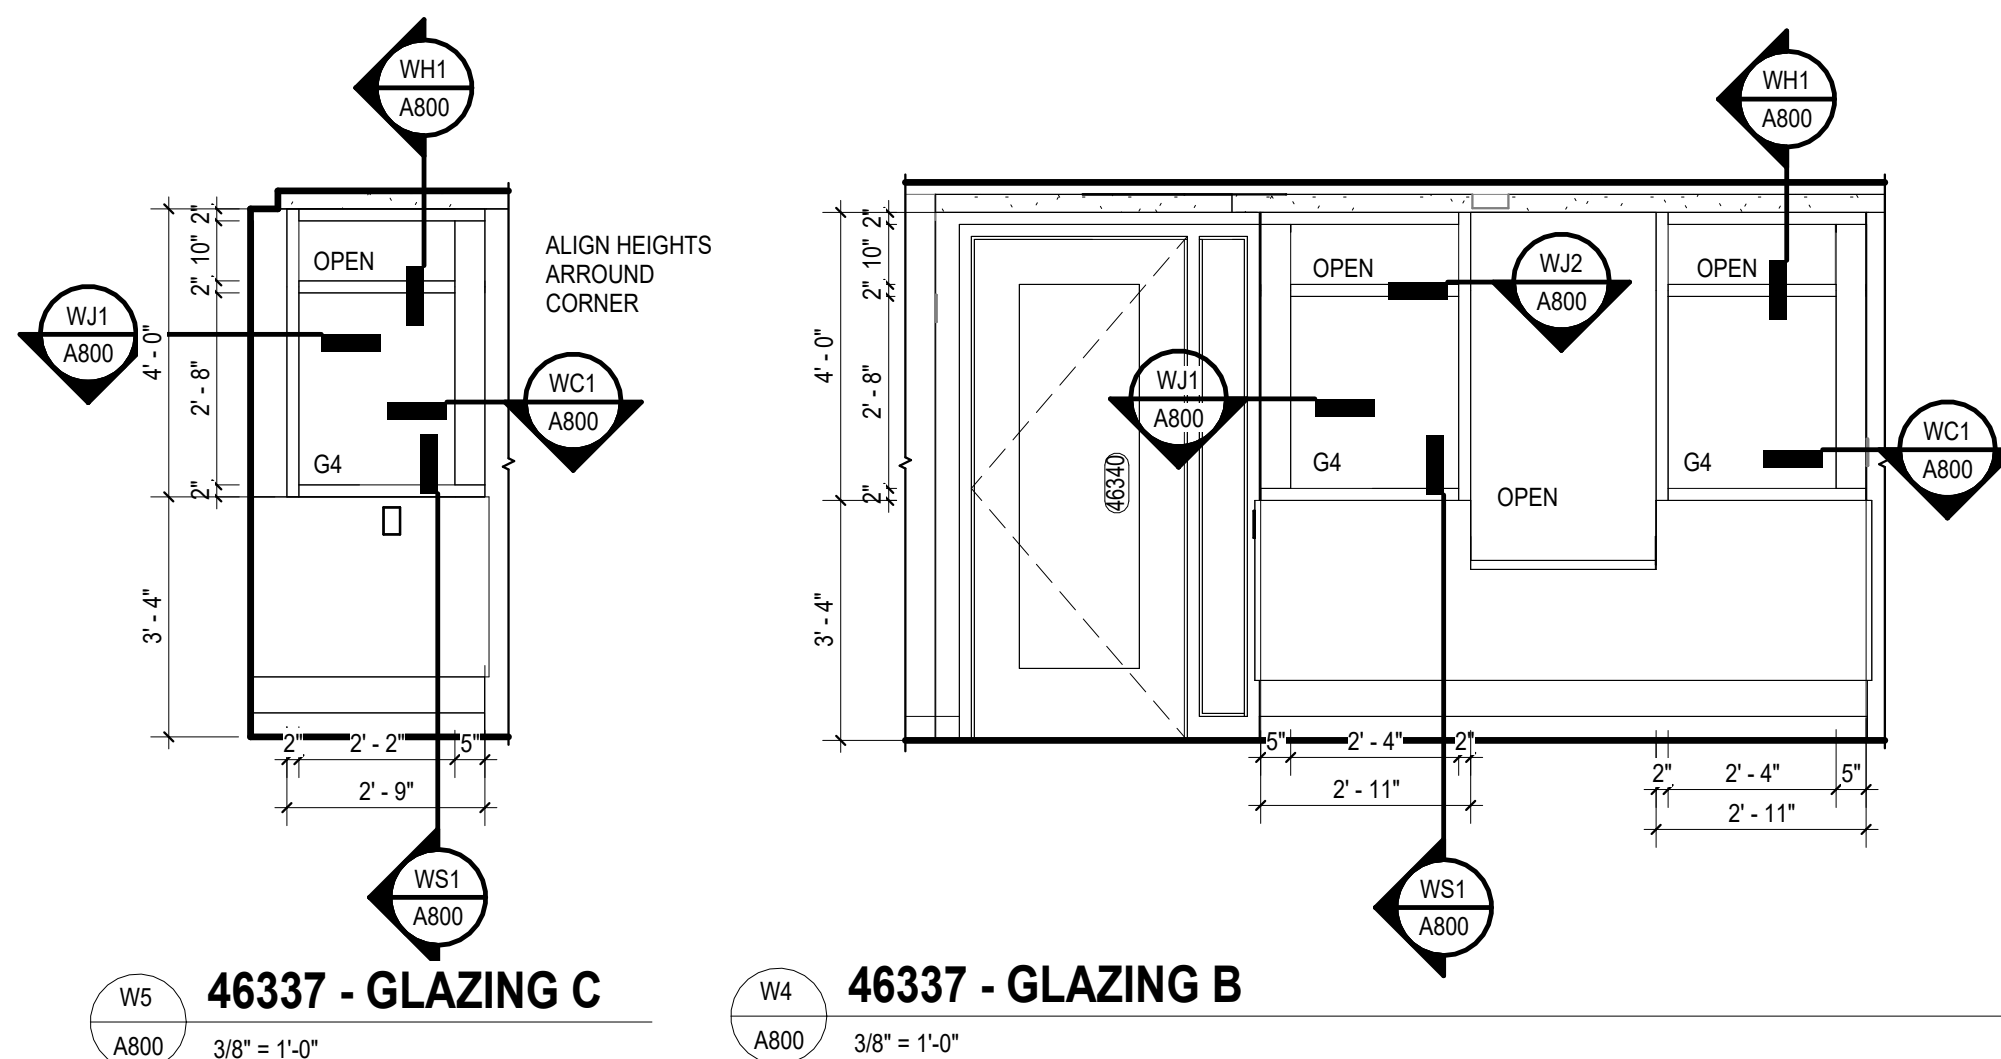

W4 46337 - GLAZING B
A800 3/8" = 1'-0"

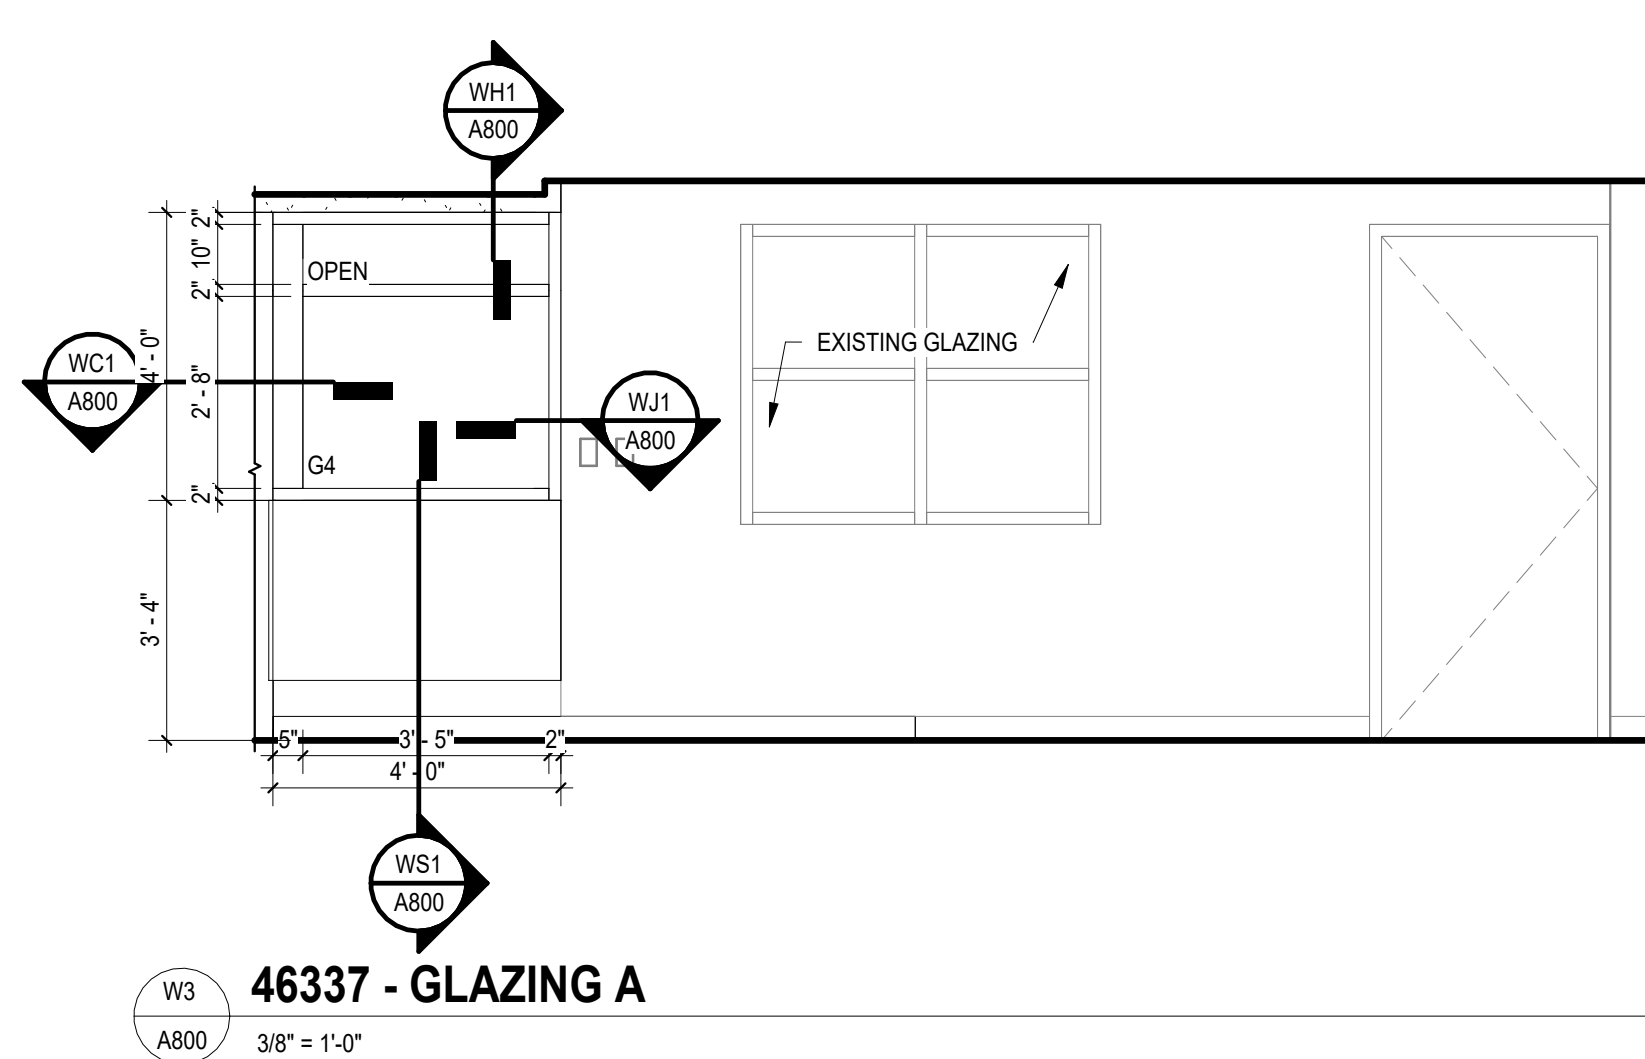

W3 46337 - GLAZING A
A800 3/8" = 1'-0"

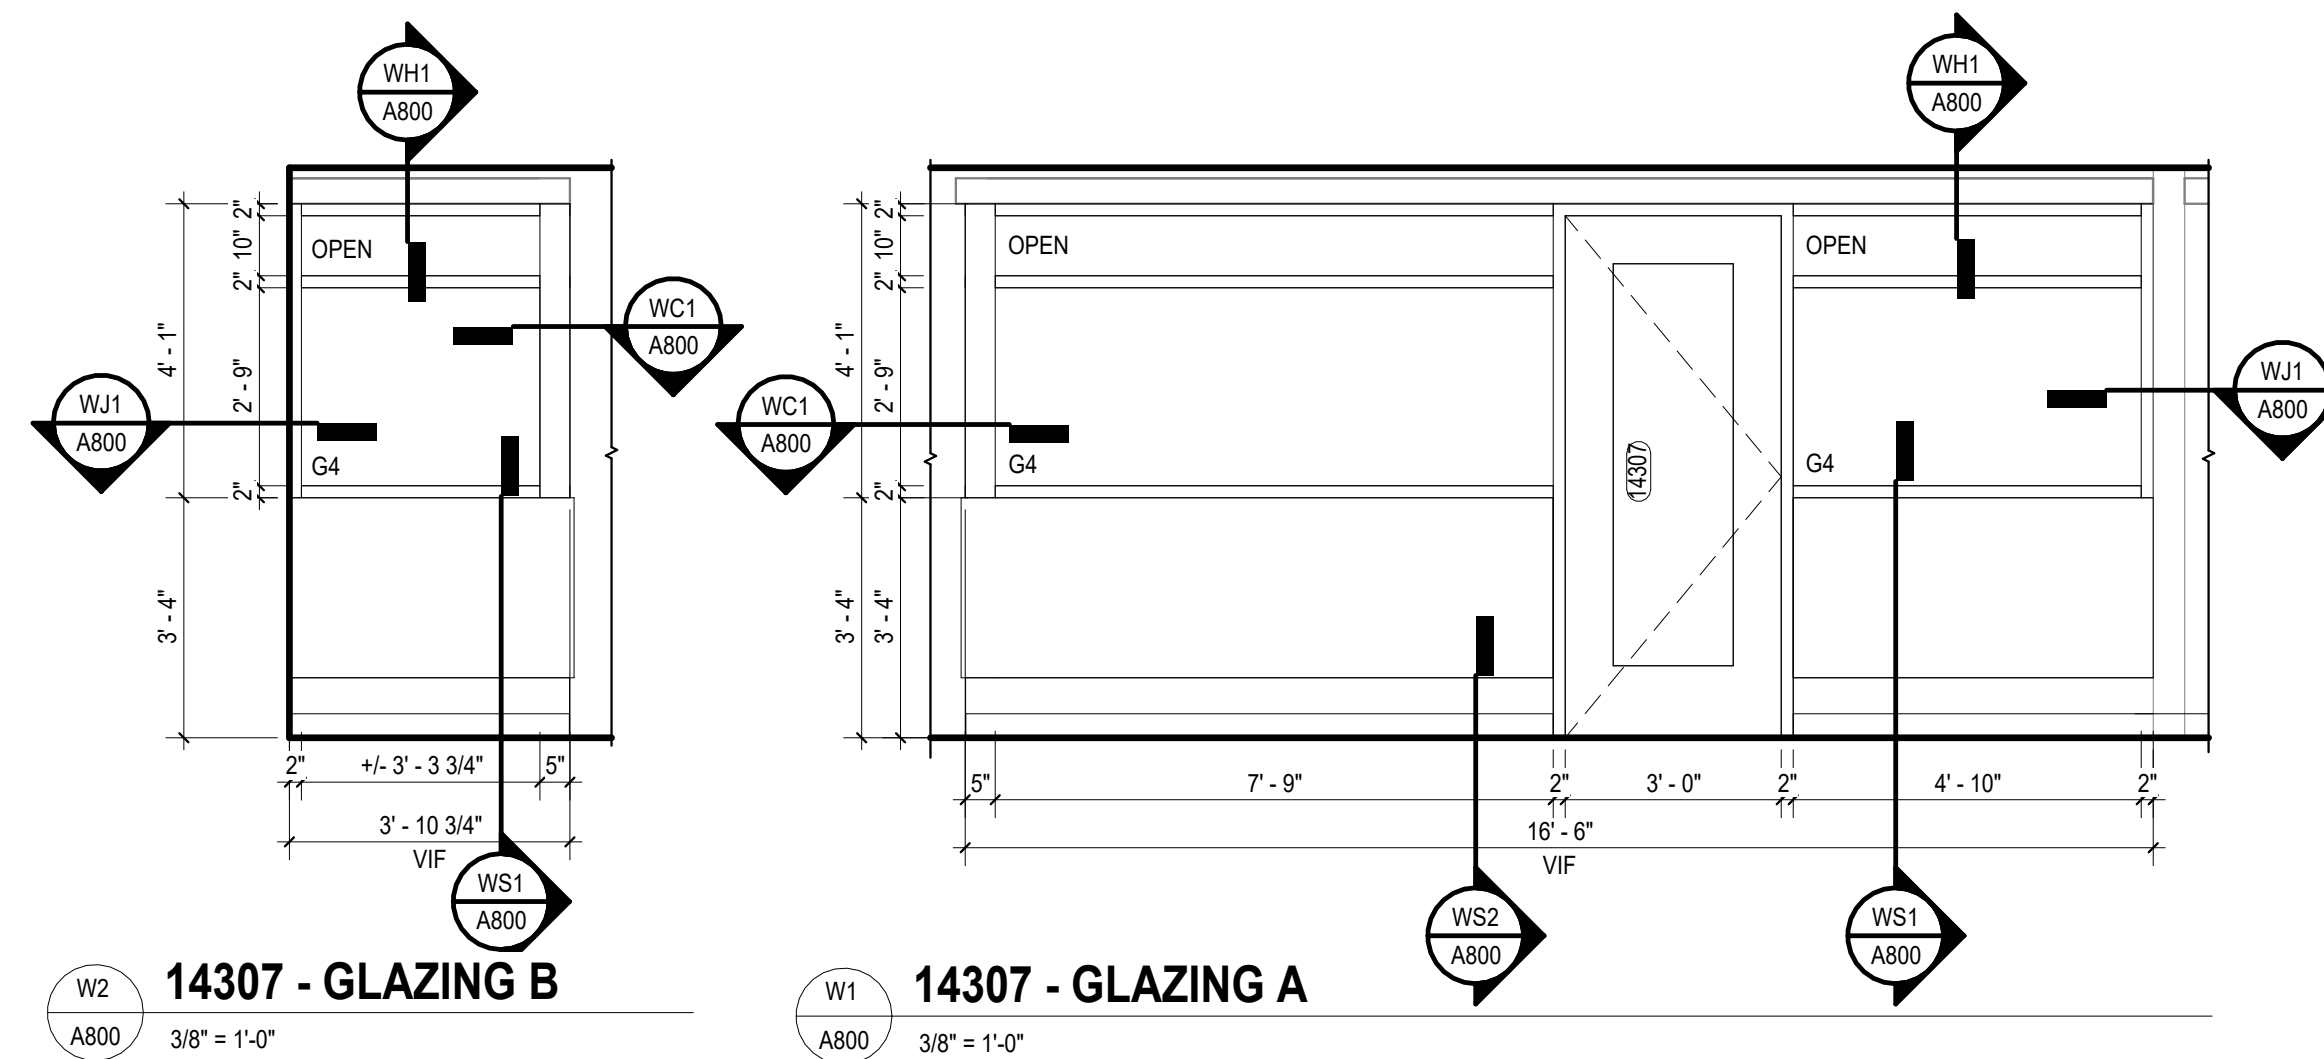

W1 14307 - GLAZING A
AB00 3/8" = 1'-0"



AH Cabarrus Memorial Building
Atrium Health Facility #: 1232
920 Church Street North, Concord, NC 28025


ISSUE DATE:	7/15/2026
PHASE:	Construction Documents
SHEET ISSUE:	
NO.	DATE DESCRIPTION

PRINCIPAL IN CHARGE:	MS
PROJECT ARCHITECT:	TAS
DRAWN BY:	JRM
SHEET NAME:	
DOOR SCHEDULE, GLAZING AND MILLWORK DETAILS	
SHEET NO.	PROJECT NUMBER:
	JAZZID_14452
A800	A/E PROJECT #:
	02600404.00


A800

INTERIOR FINISH INFORMATION	
LUXURY VINYL TILE	
LVT-03	MANUFACTURER: MANNINGTON
	PATTERN / STYLE: FEN
	COLOR: BLUE THISTLE
	SIZE: 18"X18" 2.5MM 30 MIL
	INSTALL METHOD: MONOLITHIC
	COMMENTS: UNBEVELED EDGE
PAINT	
P-31	MANUFACTURER: SHERWIN WILLIAMS
	FINISH: EGGSHELL FINISH
	COLOR: CEILING BRIGHT WHITE SW7007
	COMMENTS: CEILING PAINT ONLY FLAT FINISH
PLASTIC LAMINATE	
LPLAM-01	MANUFACTURER: NEVAMAR
	PATTERN: BLENWOOD WF0001T
	COMMENTS: VERTICAL SURFACES GRAIN TO RUN VERTICALLY
PLAM-03	MANUFACTURER: PIONITE
	PATTERN: ZEN WW075
	COMMENTS: VERTICAL SURFACES GRAIN TO RUN VERTICALLY
SOLID SURFACE	
SS-01	MANUFACTURER: LG HAUSEYS
	PATTERN: HIMACS
	COLOR: TERRAZZO MODERNA Q003
	COMMENTS: COUNTERTOPS SPLASH GUARDS
HIGH IMPACT MATERIAL	
HIM-01	MANUFACTURER: INPRO
	PATTERN / STYLE: 406
	COLOR: COLOR MATCH TO EXISTING PAINT COLOR. GC TO SEND IN SUBMITTALS FOR FINAL APPROVAL
	SIZE: .060 THICK 3' X 8' SHEET
	COMMENTS: DO NOT INSTALL ON EXTERIOR WALLS CUTS MAY BE REQUIRED FOR INSTALLATION


ALL DRAWINGS, SPECIFICATIONS AND NOTES HEREBY FURNISHED BY MC MILLAN PAZDAN SMITH ARCHITECTURE ARE AND SHALL REMAIN THE PROPERTY OF MC MILLAN PAZDAN SMITH ARCHITECTURE. THESE MATERIALS ARE TO BE USED ONLY IN CONNECTION WITH THE PROJECT SUBMITTED TO THE CLIENT. NO PART OF THESE MATERIALS ARE TO BE REPRODUCED OR TRANSMITTED IN ANY FORM OR BY ANY MEANS, ELECTRONIC OR MECHANICAL, INCLUDING PHOTOCOPYING, RECORDING, OR BY ANY INFORMATION STORAGE AND RETRIEVAL SYSTEM, WITHOUT THE WRITTEN PERMISSION OF MC MILLAN PAZDAN SMITH ARCHITECTURE. ANY UNAUTHORIZED USE OF THESE MATERIALS SHALL BE AT THE USER'S SOLE RISK AND WITHOUT LIABILITY TO MC MILLAN PAZDAN SMITH ARCHITECTURE. ALL RIGHTS RESERVED.

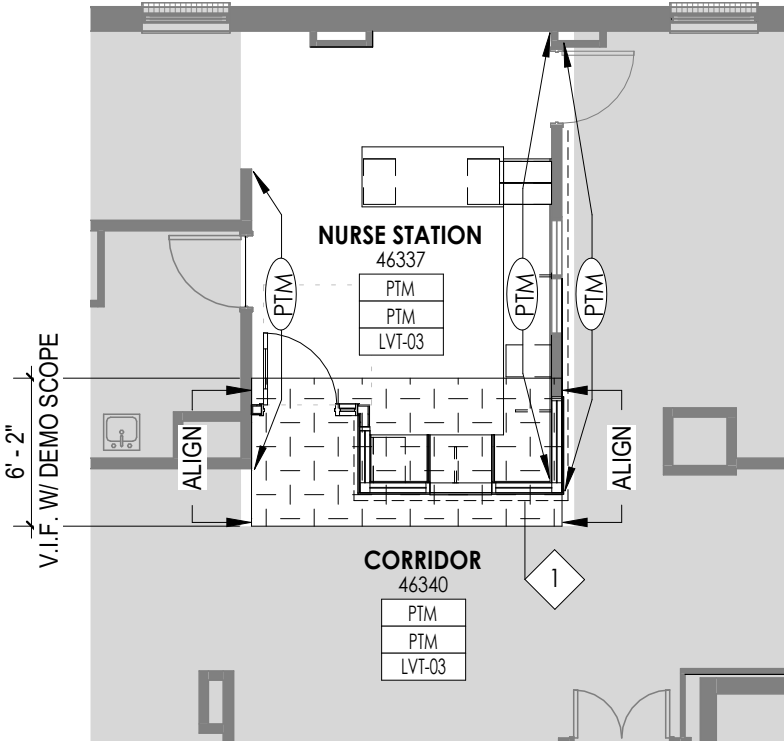

B5 INT - LEVEL 04 - INTERIOR FINISH PLAN - SR BH
ID112 1/8" = 1'-0"

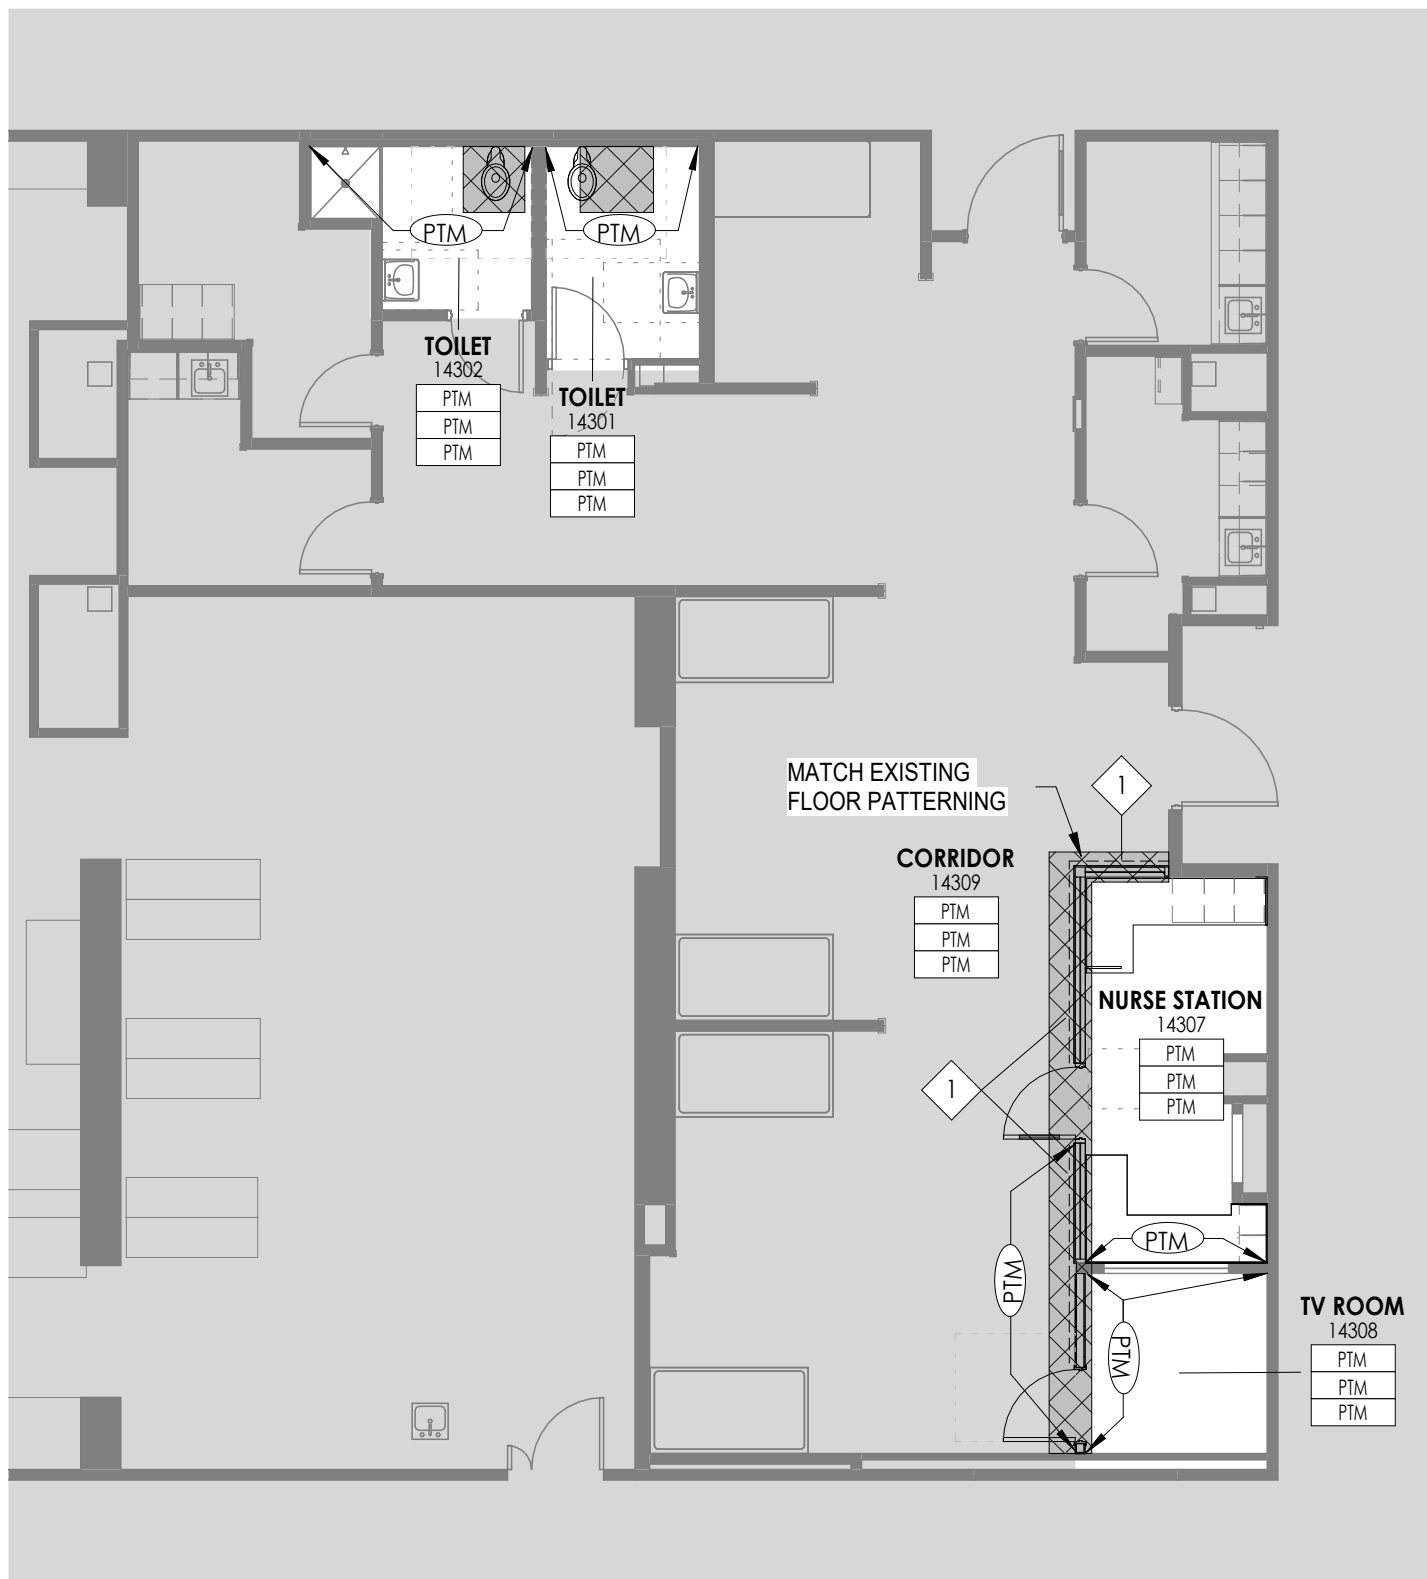


A5 INT - LEVEL 01 - INTERIOR FINISH PLAN - BH 1
ID112 1/8" = 1'-0"

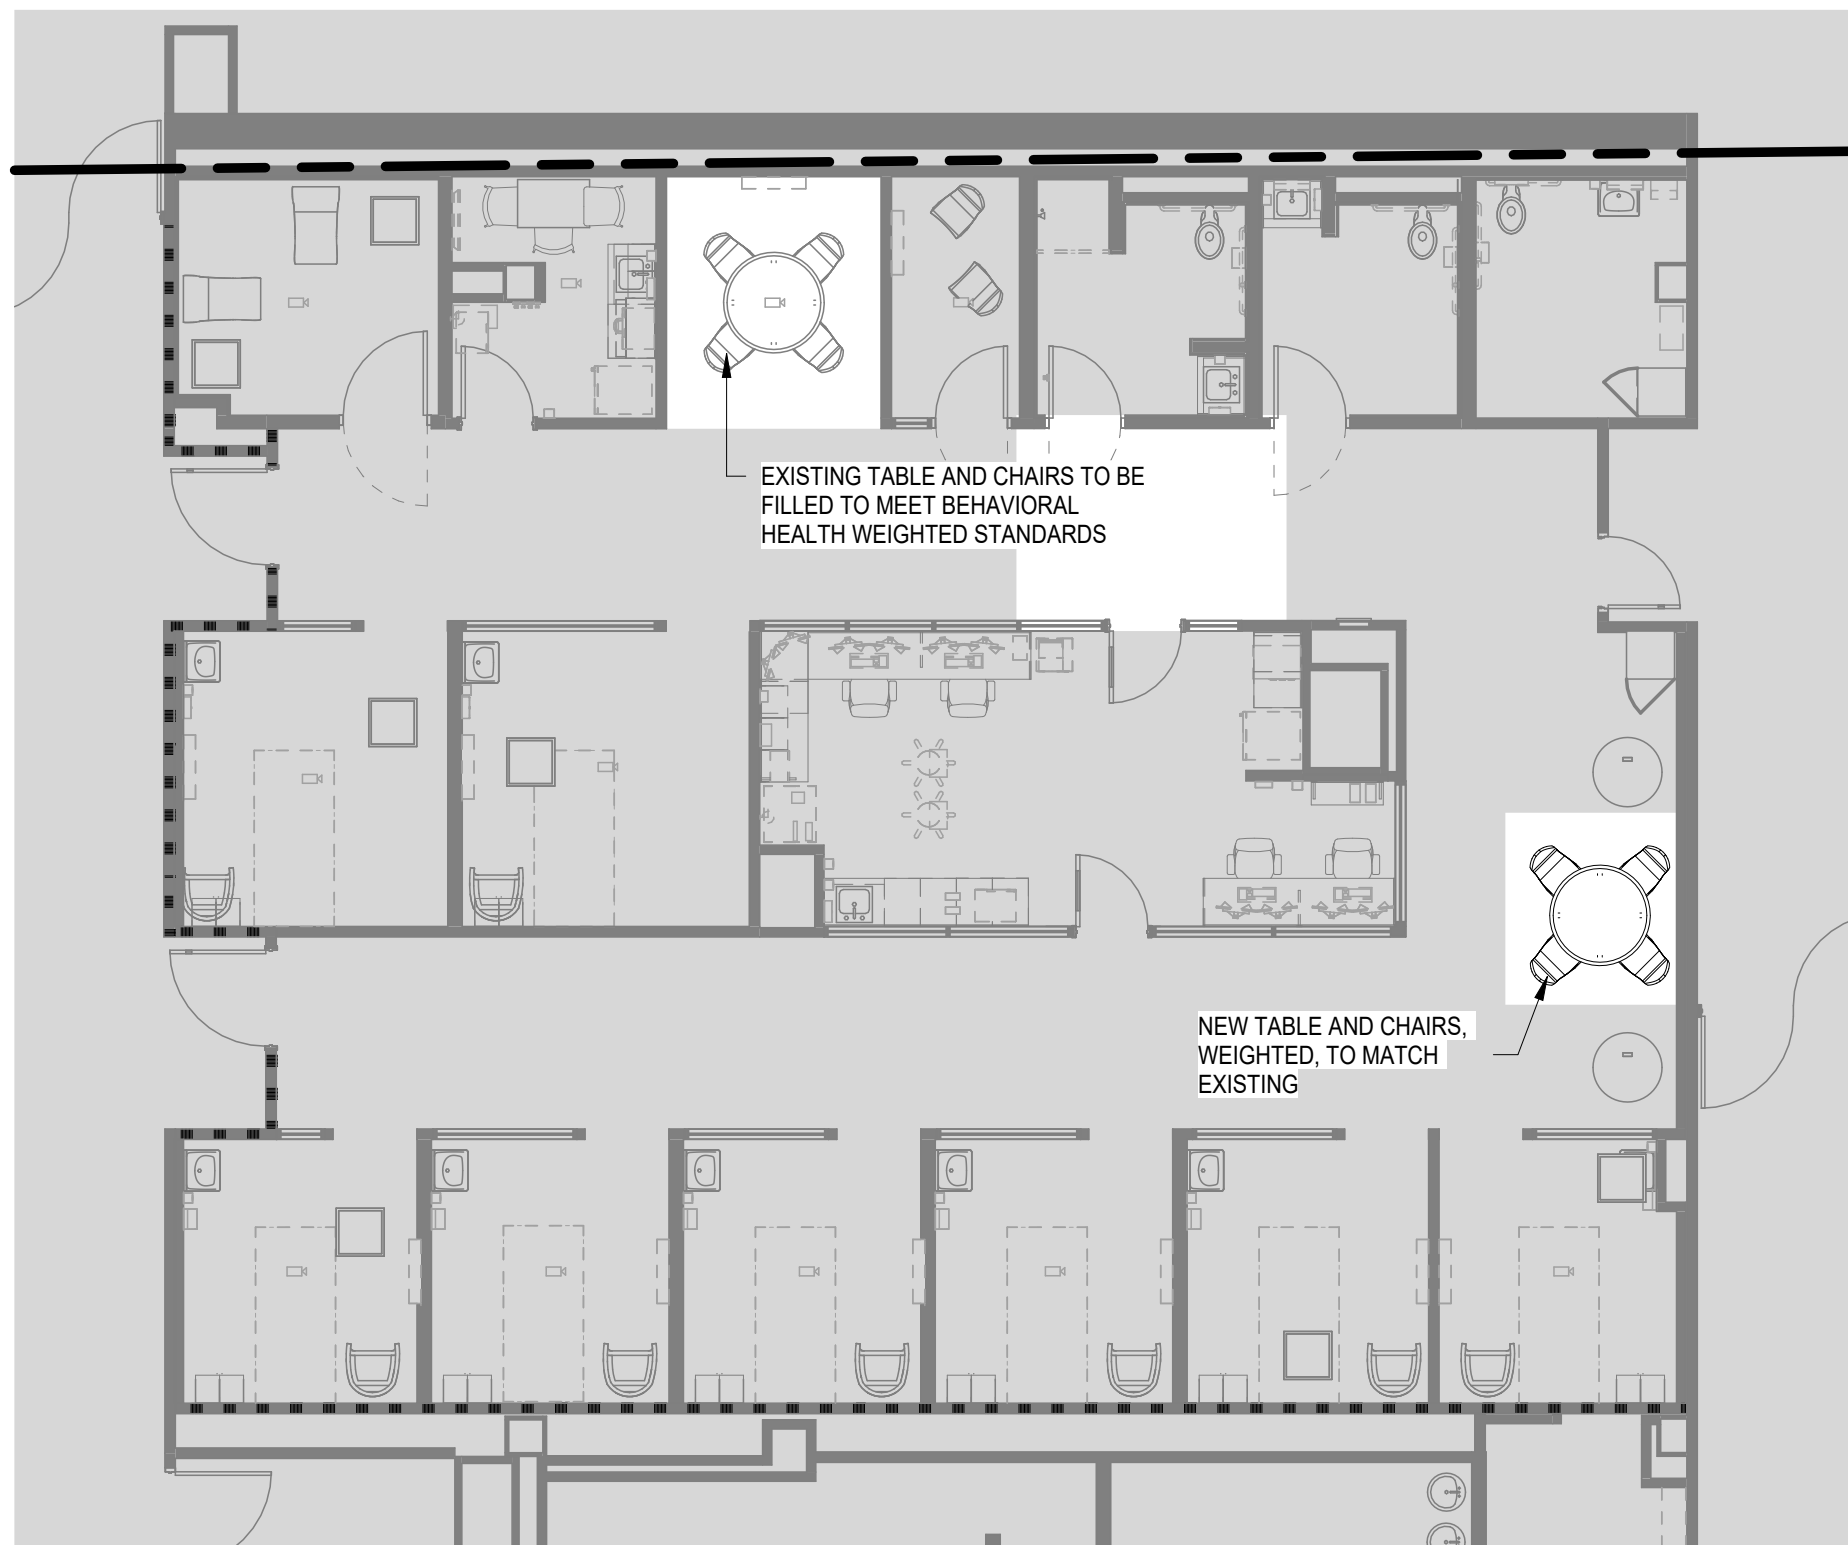

B4 INT - LEVEL 01 - FURNITURE PLAN - BH HOLDING
ID112 1/8" = 1'-0"

NOTE: ALL FURNITURE TO BE SPECIFIED, PROCURED AND INSTALLED BY OFFICE ENVIRONMENTS IN COORDINATION WITH INTERIOR DESIGNER.

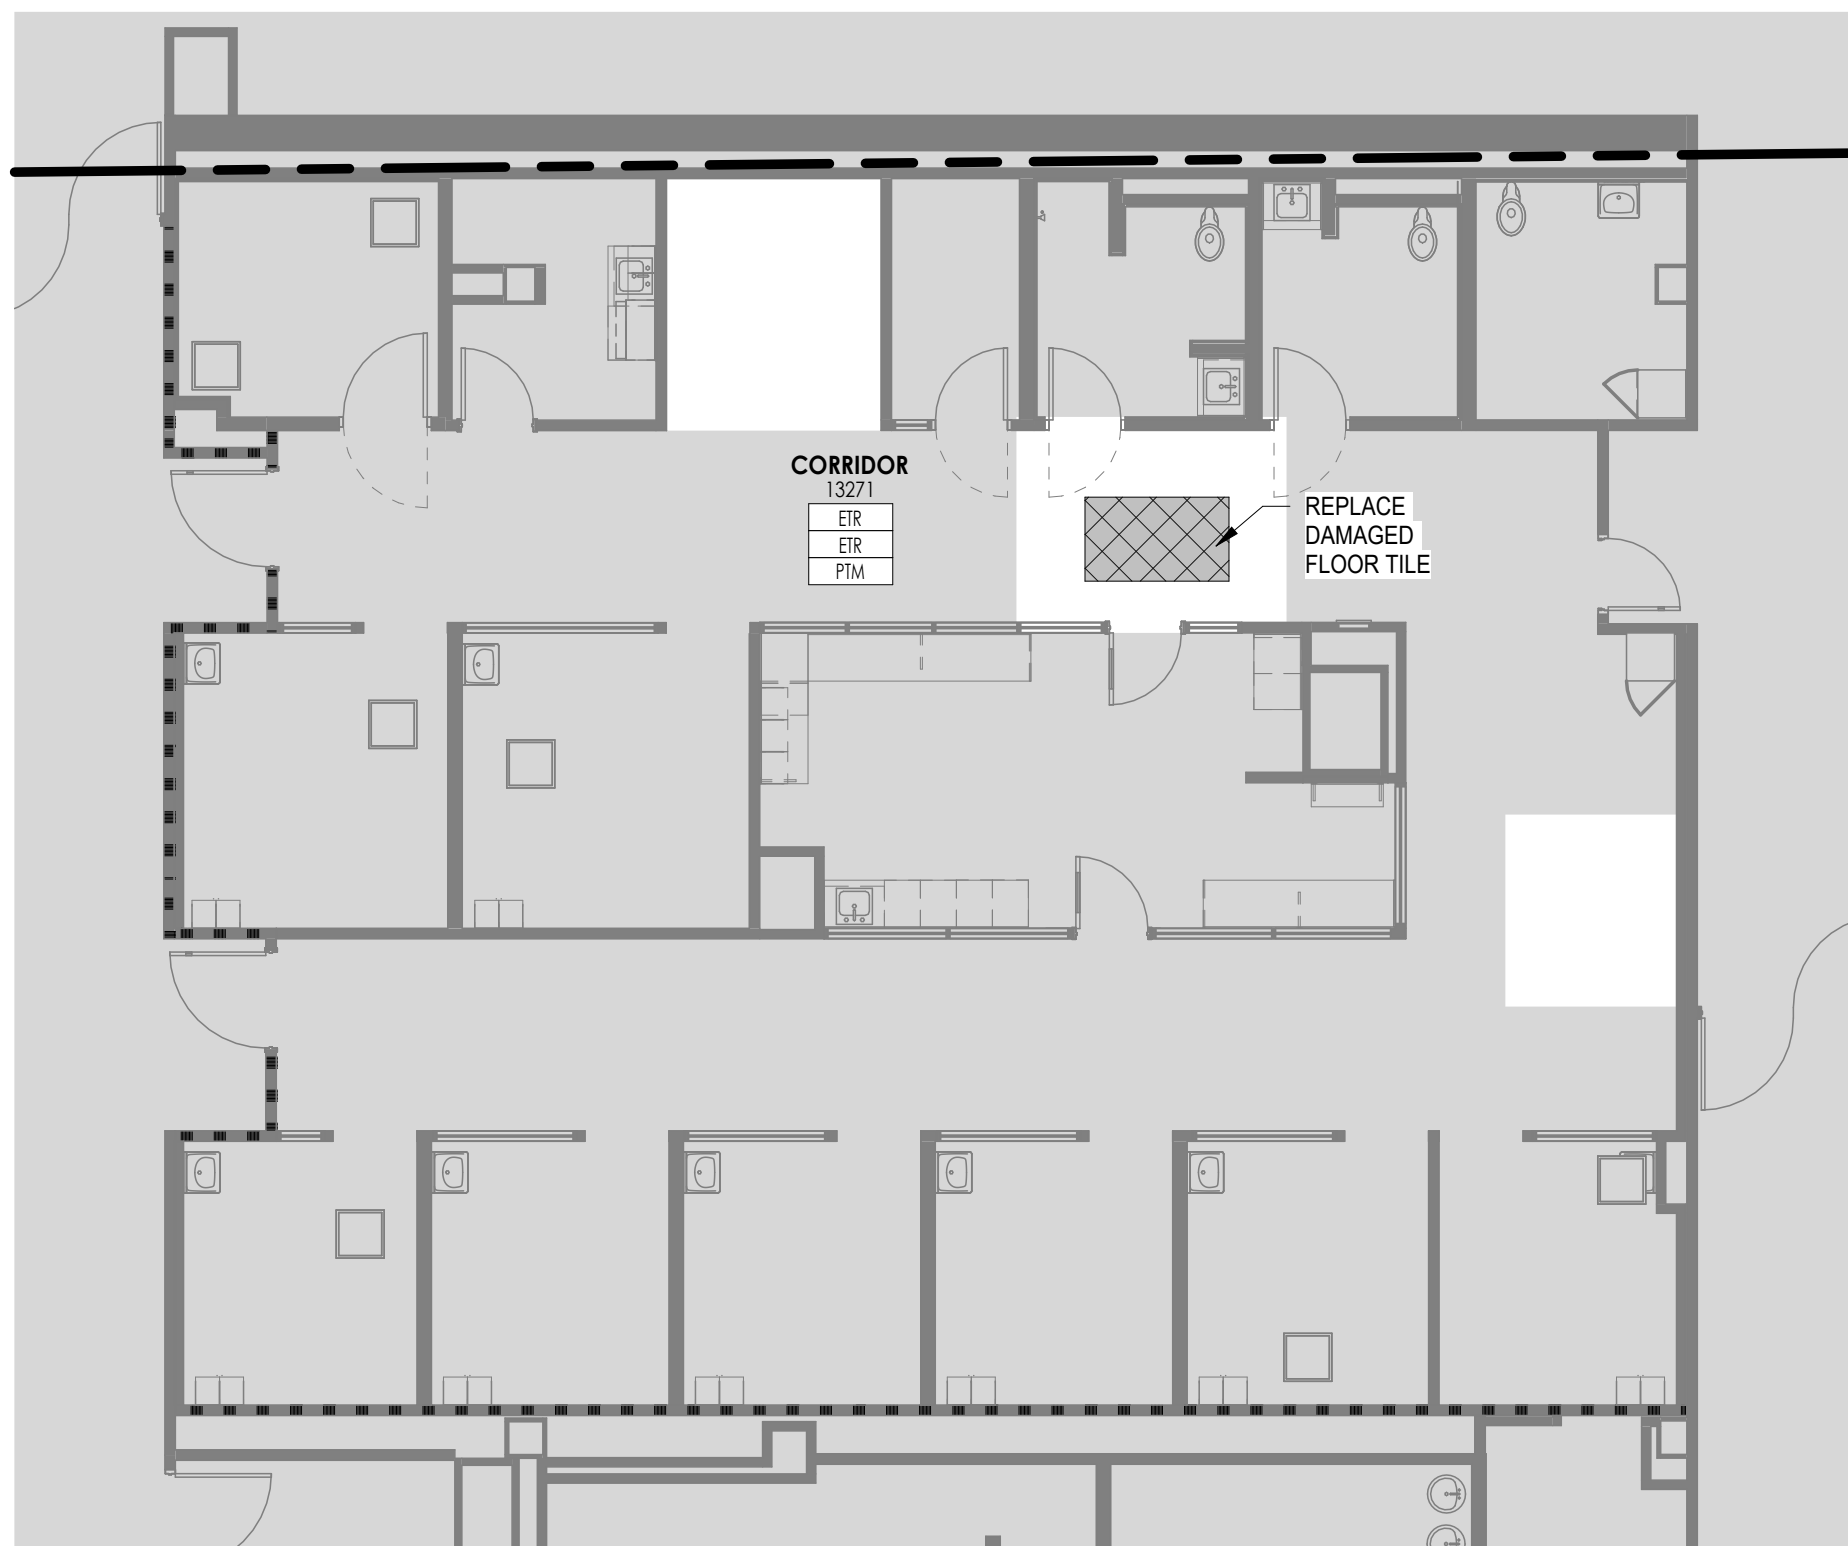

A4 INT - LEVEL 01 - INTERIOR FINISH PLAN - BH HOLDING
ID112 1/8" = 1'-0"

INTERIOR FINISH NOTES

- GENERAL**
- ALL NEW HOLLOW METAL DOORS, DOOR FRAMES AND WINDOW FRAMES IN PROJECT SCOPE SHALL BE PAINTED, U.N.O.
 - CAULK AT BASE OF DOOR FRAME BETWEEN DOOR FRAME AND FLOOR MATERIAL. TYPICAL AT ALL LOCATIONS. CAULK TO BE COLOR MATCHED TO DOOR FRAME TRIM COLOR. IN BEHAVIORAL HEALTH SPACES, CAULK TO BE PICK RESISTANT.
 - ALL ITEMS EXPOSED TO VIEW SHALL BE FINISHED (I.E. PAINTED, STAINED, ETC.) UNLESS PREFINISHED BY MANUFACTURER. NO UNFINISHED SURFACES WILL BE ACCEPTED.
- FLOORING**
- ALL FLOOR FINISHES SHALL TRANSITION AT THE CENTERLINE OF THE DOOR WHEN IN THE "CLOSED" POSITION OR CENTER OF WALL OPENING IF THERE IS NO DOOR, U.N.O.
 - EXTEND FLOOR FINISH MATERIALS UNDER ANY MILLWORK THAT DOES NOT MEET THE FLOOR AND INTO KNEE AND TOE KICK SPACES, DOOR REVEALS, AND SIMILAR OPENINGS.
 - REFERENCE FLOOR DIRECTION ANNOTATIONS FOR CORRECT INSTALLATION OR SEAM DIRECTION. **DO NOT FOLLOW HATCH PATTERN DIRECTION, SHOWN ON PLANS.**
 - FLOOR FINISHES TO BE IN ACCORDANCE WITH SECTION 804 NCBC.
- WALLS**
- WALL AND CEILING FINISHES TO BE IN ACCORDANCE WITH SECTION 803 NCBC.
- CEILING**
- REFER TO REFLECTED CEILING PLAN DRAWINGS FOR CEILING TYPES AND SOFFIT FINISHES. SOFFITS SHOULD BE PAINTED SPECIFIED COLOR AND FINISHED ON ALL THREE SIDES, U.N.O.
 - WALL AND CEILING FINISHES TO BE IN ACCORDANCE WITH SECTION 803 NCBC.
- MILLWORK**
- PLASTIC LAMINATE WITH A VISUAL GRAIN SPECIFIED ON VERTICAL SURFACES TO RUN VERTICALLY, U.N.O.
 - WALL CAPS, WHERE APPLICABLE, SHALL BE SOLID SURFACE MATERIAL, U.N.O. REF INTERIOR FINISH INFORMATION FOR MATERIAL SPECIFICATION.



INTERIOR FINISH PLAN ABBREVIATIONS

- | | |
|-------|---|
| ACT | ACOUSTICAL CEILING TILE |
| AF | ABOVE FINISHED FLOOR |
| ART | ARTWORK |
| AWP | ACOUSTICAL WALL PANEL |
| CG | CORNER GUARD |
| CPT | CARPET/ CARPET TILE |
| CR | CRASH RAIL |
| CT | CERAMIC TILE |
| DWC | DIGITAL WALL COVERING |
| DWP | DIGITAL WALL PANEL |
| EP | EPOXY PAINT |
| ERF | EPOXY RESIN FLOORING |
| ETR | EXISTING TO REMAIN |
| FILM | FILM |
| FRP | FIBERGLASS REINFORCED PANEL |
| GR | GROUT |
| HWSV | HEAT WELDED SHEET VINYL |
| HIM | HIGH IMPACT MATERIAL |
| HR | HANDRAIL |
| LVT | LUXURY VINYL TILE |
| MRB | MILLWORK PROFILE RESILIENT/ RUBBER BASE |
| MT | METAL TRIM |
| NA | NOT APPLICABLE |
| NIC | NOT IN CONTRACT |
| P | PAINT |
| PC | PRIVACY CURTAIN |
| PLAM | PLASTIC LAMINATE |
| PT | PORCELAIN TILE |
| PTB | PORCELAIN TILE BASE |
| PTM | PATCH TO MATCH |
| QZ | QUARTZ |
| RB | RESILIENT/ RUBBER BASE |
| RP | RESIN PANEL |
| RSF | RUBBER SHEET FLOORING |
| RTF | RUBBER TILE FLOORING |
| SC | SPECIALTY CEILING |
| SCON | SEALED CONCRETE |
| SRB | SANITARY RESILIENT/ RUBBER BASE |
| SS | SOLID SURFACE |
| SST | STAINLESS STEEL |
| STR | STAIR TREAD & RISER |
| TACK | TACKABLE SURFACE UPHOLSTERY |
| TBD | TO BE DETERMINED |
| TS | TRANSITION STRIP |
| UNFIN | UNFINISHED |
| UNO | UNLESS NOTED OTHERWISE |
| VWF | VERIFY IN FIELD |
| VWC | VINYL WALL COVERING |
| WCM | WALK OFF MAT |
| WT | WINDOW TREATMENT |

INTERIOR FLOOR FINISH LEGEND

- | | |
|--|--------|
| | LVT-03 |
| | ETR |
| | PTM |


INTERIOR FINISH PLAN LEGEND

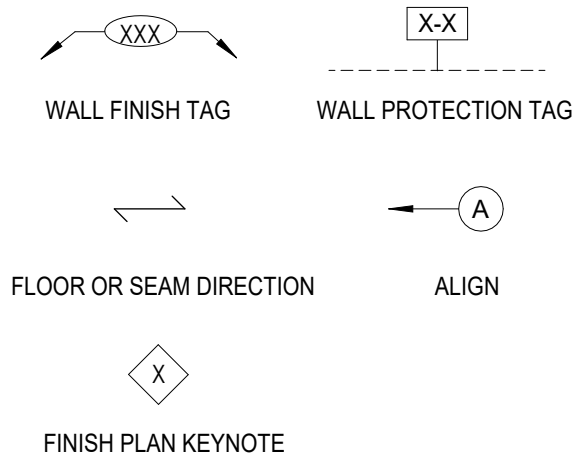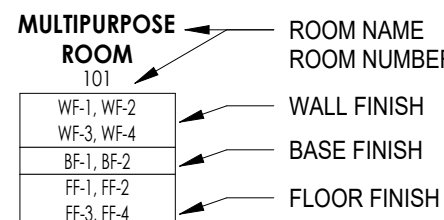



FINISH PLAN KEY NOTES

- GENERAL CONTRACTOR TO PRICE HIGH IMPACT MATERIAL AS A DEDUCT/ ALTERNATE WHERE NOTED. ASSUME WALL PROTECTION ASSEMBLY 1-A, OR TO UNDERSIDE OF FRAME.

TYPICAL WALL PROTECTION ASSEMBLIES

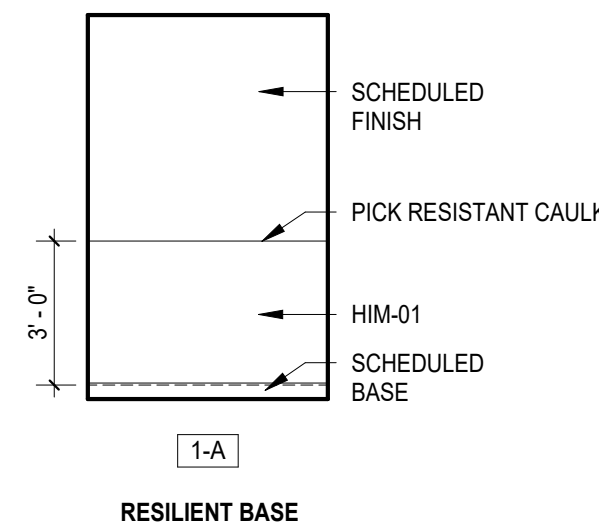

KEY PLAN

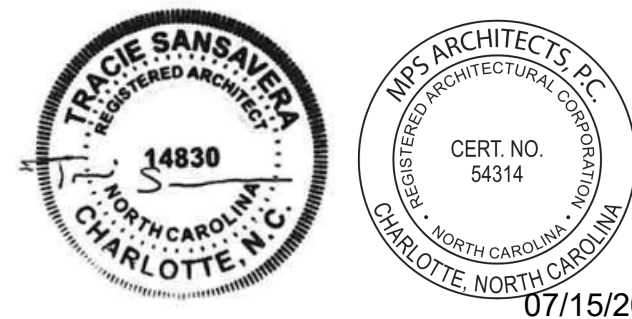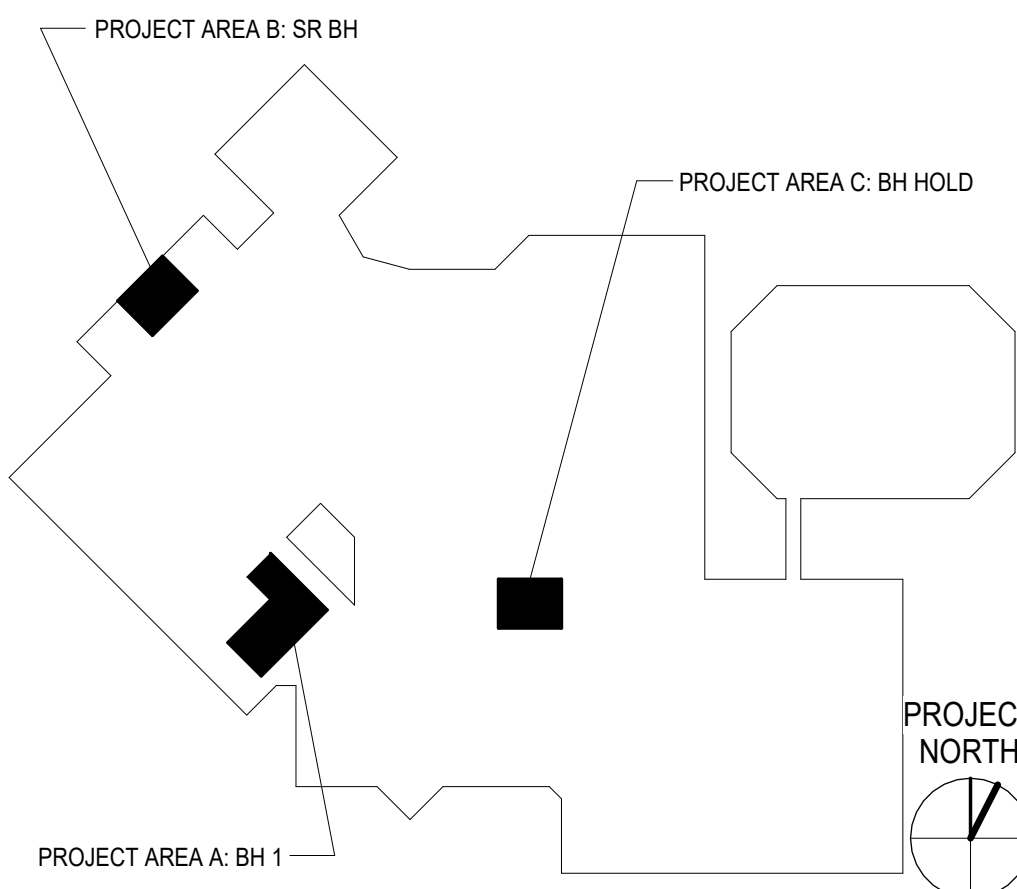

ATRIUM HEALTH
AH CABARRUS BH RENOVATION
AH Cabarrus Memorial Building
Atrium Health Facility #: 1232
920 Church Street North, Concord, NC 28025

ISSUE DATE:	7/15/2026	
PHASE:	Construction Documents	
SHEET ISSUE:		
NO.	DATE	DESCRIPTION

PRINCIPAL IN CHARGE: MS
PROJECT ARCHITECT: TAS
DRAWN BY: CH
SHEET NAME:
INTERIOR FINISH &
FURNITURE PLANS -
LEVEL 01 & LEVEL 04
SHEET NO. PROJECT NUMBER:
JAZZID_14452
A/E PROJECT #: 02600404.00

ID112

ALL DRAWINGS, SPECIFICATIONS AND COORDINATES OF THE PROJECT ARE THE PROPERTY OF ATRIUM HEALTH. ANY REUSE, REPRODUCTION, OR MODIFICATION OF ANY PART OF THIS DOCUMENT WITHOUT THE WRITTEN PERMISSION OF ATRIUM HEALTH IS STRICTLY PROHIBITED. THE PROJECT TEAM SHALL BE RESPONSIBLE FOR THE ACCURACY OF THE INFORMATION PROVIDED. THE PROJECT TEAM SHALL BE RESPONSIBLE FOR THE ACCURACY OF THE INFORMATION PROVIDED. THE PROJECT TEAM SHALL BE RESPONSIBLE FOR THE ACCURACY OF THE INFORMATION PROVIDED.

MPPF GENERAL NOTES

- THE DRAWINGS SHALL NOT BE SCALED FOR CONSTRUCTION PURPOSES. THE SCALE, WHEN INDICATED IS INTENDED FOR GENERAL REFERENCE ONLY.
- THE MECHANICAL AND PLUMBING CONTRACTORS SHALL MAKE A COMPLETE REVIEW OF THE PROJECT PLANS, SCHEDULES, AND DETAILS PRIOR TO INSTALLATION OF THE SYSTEMS AND REVIEW ANY CONFLICTS WITH THE ENGINEER.
- ALL WORK SHALL CONFORM TO ALL LOCAL, STATE, AND NATIONAL CODES. EQUIPMENT SHALL BE INSTALLED IN ACCORDANCE WITH MANUFACTURER'S WRITTEN RECOMMENDATIONS. ANY EQUIPMENT OR MATERIAL DEVIATIONS FROM THAT SPECIFIED OR DETAILED ON THIS DRAWING SHALL BE SUBJECT TO THE APPROVAL OF THE ARCHITECT/ENGINEER. ALL PROPOSED EQUIPMENT DEVIATIONS SUBMITTED SHALL BE DESIGN BOTH IN QUALITY AND CAPACITY TO THAT EQUIPMENT SPECIFIED.
- DESIGN IS BASED ON THE MANUFACTURER AND MODEL SCHEDULED OR THE FIRST MANUFACTURER LISTED IN THE DRAWINGS AND SPECIFICATIONS. CONTRACTOR SHALL BEAR ANY AND ALL COSTS FOR ALTERING ANY OTHER CONTRACT OR SUB-CONTRACT RESULTING FROM THE USE OF ANY MANUFACTURER OR MODEL OTHER THAN THE DESIGN BASIS INCLUDING LISTED EQUIVALS.
- PRIOR TO PIPING, CONSTRUCTION, FABRICATING DUCTWORK, ORDERING EQUIPMENT, ETC. THE CONTRACTOR SHALL FIELD VERIFY SPACE LIMITATIONS AT THE JOB SITE AND COORDINATE WITH OTHER TRADES.
- UNLESS OTHERWISE NOTED, ALL MATERIALS, EQUIPMENT AND PRODUCTS INCORPORATED IN THE WORK UNDER THE CONTRACT SHALL BE NEW, OF A SATISFACTORY GRADE FOR THE PURPOSES INTENDED, AND TO THE EXTENT POSSIBLE, STANDARD PRODUCTS OF THE VARIOUS MANUFACTURERS EXCEPT WHERE SPECIAL CONSTRUCTION OR PERFORMANCE FEATURES ARE CALLED FOR. THEY SHALL BE INSTALLED IN ACCORDANCE WITH THE MANUFACTURER'S REQUIREMENTS.
- THE MECHANICAL AND PLUMBING CONTRACTORS ARE RESPONSIBLE FOR ANY DAMAGE CAUSED BY THEIR ACTIONS. SUCH DAMAGE SHALL BE RETURNED TO ORIGINAL NORMAL WORKING CONDITION, SUBJECT TO ACCEPTANCE OF THE OWNER AND ENGINEER, WITHOUT EXTRA COST TO THE OWNER.
- THE MECHANICAL AND PLUMBING CONTRACTORS SHALL KEEP THEIR WORK SITE AND ALL ACCESS POINTS OF THE BUILDING FREE OF RUBBISH AND WASTE MATERIAL. REFER TO ARCHITECTURAL DRAWINGS, AS AVAILABLE, FOR LOCATIONS OF ALL RATED WALLS AND FLOOR ASSEMBLIES. PROVIDE FIRE DAMPERS AND/OR UL LISTED ASSEMBLIES AND/OR SEALANTS PER DRAWINGS, SPECIFICATIONS, AND APPLICABLE CODES AT ALL PENETRATIONS.
- THE MECHANICAL OR PLUMBING CONTRACTOR SHALL FURNISH ACCESS DOORS FOR ALL GYPSUM BOARD CEILINGS AT ANY EQUIPMENT OR OTHER ITEMS REQUIRING ACCESS OR SERVICE. ACCESS DOORS SHALL BE INSTALLED BY THE GENERAL CONTRACTOR. SEE PLANS AND GENERAL CONSTRUCTION SPECIFICATIONS FOR ACCESS DOOR REQUIREMENTS.

2018 APPENDIX B	
NC MECHANICAL SUMMARY	
MECHANICAL SYSTEMS, SERVICE SYSTEMS AND EQUIPMENT	
CLIMATE ZONE	3A
INTERIOR DESIGN CONDITIONS	
WINTER DRY BULB	10 DEG F
SUMMER DRY BULB	98 DEG F
WINTER DRY BULB	70 DEG F
SUMMER DRY BULB	75 DEG F
RELATIVE HUMIDITY	50%
BUILDING HEATING LOAD	EXISTING UNCHANGED
BUILDING COOLING LOAD	EXISTING UNCHANGED
MECHANICAL SPACE CONDITIONING SYSTEM	
UNITARY	
DESCRIPTION OF UNIT	N/A
HEATING EFFICIENCY	N/A
COOLING EFFICIENCY	N/A
HEAT OUTPUT OF UNIT	N/A
COOLING OUTPUT OF UNIT	N/A
BOILER	
TOTAL BOILER OUTPUT, IF OVERSIZED, STATE REASON	EXISTING UNCHANGED
CHILLER	
TOTAL CHILLER OUTPUT, IF OVERSIZED, STATE REASON	EXISTING UNCHANGED
LIST EQUIPMENT EFFICIENCIES	

CODES/STANDARDS	
- NORTH CAROLINA BUILDING CODES - NORTH CAROLINA BUILDING CODE 2018 - NORTH CAROLINA MECHANICAL CODE 2018 - NORTH CAROLINA ENERGY CONSERVATION CODE 2018 - NORTH CAROLINA EXISTING BUILDING CODE 2018 - NORTH CAROLINA PLUMBING CODE 2018 - NATIONAL FIRE PROTECTION ASSOCIATION (NFPA) - NFPA 90A-2021, STANDARD FOR THE INSTALLATION OF AIR-CONDITIONING AND VENTILATING SYSTEMS - NFPA 99-2021, HEALTHCARE FACILITIES CODE - FACILITY GUIDELINES INSTITUTE - HOSPITAL FACILITIES DESIGN CODE - 2022 EDITION INCLUDING ALL ADDENDA - ASHRAE STANDARDS 92-1201S, VENTILATION FOR ACCEPTABLE INDOOR AIR QUALITY 90-1201S, ENERGY STANDARD FOR BUILDINGS EXCEPT LOW-RISE RESIDENTIAL BUILDINGS 170-2021, VENTILATION OF HEALTH CARE FACILITIES - SMACNA 2020, HVAC DUCT CONSTRUCTION STANDARDS-METAL & FLEXIBLE, 4TH EDITION - BEHAVIORAL HEALTH DESIGN GUIDE - 2022 EDITION - ATRIUM HEALTH FACILITY GUIDELINES	

MECHANICAL ABBREVIATIONS			
ABBREVIATION	DESCRIPTION	ABBREVIATION	DESCRIPTION
AAV	AUTOMATIC AIR VENT	HX	HEAT EXCHANGER
ADJ	ADJUSTABLE OR ADJUSTMENT	IND	INDUCTION UNIT
AO	ANALOG OUT	IWC	INCHES WATER COLUMN
AFF	ABOVE FINISHED FLOOR	JUN	JUNCTION BOX
AFG	ABOVE FINISHED GRADE	LAT	LEAVING AIR TEMPERATURE
AHU	AIR HANDLING UNIT	LPS	LOW PRESSURE CONDENSATE
APH	AIRSIDE PRESSURE DROP	LPS	LOW PRESSURE STEAM
BF	BELOW FINISHED FLOOR	LWT	LEAVING WATER TEMPERATURE
BLDG	BUILDING	MAV	MEDIUM AIR VENT
BMP	BUILDER MANAGEMENT PANEL	MPC	MEDIUM PRESSURE CONDENSATE
CFM	CUBIC FEET PER MINUTE	MPS	MEDIUM PRESSURE STEAM
CMD	COMMAND	MTD	MONTH TO DATE
COND	CONDENSATE DRAINAGE	NA	NOT AVAILABLE / NOT APPLICABLE
CV	CONSTANT VOLUME	NC	NORMALLY CLOSED
CWMU	COLD WATER MAKEUP UNIT	NC	NOT IN CONTRACT
CHWR	CHILLED WATER RETURN	NO	NORMALLY OPEN
CHWS	CHILLED WATER SUPPLY	NTS	NOT TO SCALE
CWS	CONDENSER WATER SUPPLY	OCC	OCCUPANT OR OCCUPANCY
CWR	CONDENSER WATER RETURN	OC	OUTSIDE AIR
D	DIGITAL IN	PC	PLUMBING CONTRACTOR
DO	DIGITAL OUT	PSI	POUNDS PER SQUARE INCH
DN	DOWN	RA	RETURN AIR
EA	EXHAUST AIR	RAG-X	RETURN AIR GRILLE - TYPE
EAG-X	EXHAUST AIR GRILLE - TYPE	RTU	ROOM TOP UNIT
EAT	ENTERING AIR TEMPERATURE	SA	SUPPLY AIR
EC	ELECTRIC CONTRACTOR	SAX-X	SUPPLY AIR DIFFUSER - TYPE
ESP	EXTERNAL STATIC PRESSURE	SC	SAFETY CIRCUIT
ETR	EXISTING TO REMAIN	S/S	START/STOP
EWT	ENTERING WATER TEMPERATURE	STM COND	STEAM CONDENSATE RETURN
EX	EXISTING	TAB	TEST AND BALANCE
FACP	FIRE ALARM CONTROL PANEL	TEMP	TEMPERATURE
FAN COIL UNIT	FAN COIL UNIT	TEMP	TOTAL STATIC PRESSURE
FM	FEET PER MINUTE	UH	UNIT HEATER
GC	GENERAL CONTRACTOR	VEL	VELOCITY
GPM	GALLONS PER MINUTE	VAV	VARIABLE AIR VOLUME
HWS	HEATING HOT WATER SUPPLY	VP	VIRTUAL POINT
HWR	HEATING HOT WATER RETURN	WDR	WATER/STEAM PRESSURE DROP
HP	HORSEPOWER	XFMR	TRANSFORMER
HPC	HIGH PRESSURE CONDENSATE		
HPS	HIGH PRESSURE STEAM		

INSULATION


ANY INSULATION DAMAGED DURING THE PROJECT SHALL BE REPAIRED AND ALL VAPOR BARRIERS RESTORED.

COORDINATION

- ALL SHUTDOWNS SHALL BE COORDINATED AND APPROVED THROUGH THE OWNERS' REPRESENTATIVE AND WILL REQUIRE ADVANCE NOTICE OF TWO WEEK MINIMUM. THIS TIME/LENGTH MAY BE LONGER OR SHORTER FOR SOME SHUTDOWNS AND SHALL BE AT THE OWNERS' DISCRETION.
- THESE DRAWINGS DEFINE THE BASIC AREA OF DEMOLITION AND ARE AS ACCURATE AS WAS POSSIBLE FROM SITE INVESTIGATIONS MADE DURING THE DESIGN PROCESS. NOT ALL EXISTING MATERIALS AND EQUIPMENT ARE SHOWN. ANY MECHANICAL MATERIALS AND EQUIPMENT THAT ARE NOT BEING USED AFTER THE RENOVATION SHALL BE REMOVED WHETHER SHOWN OR NOT. NO MATERIALS OR EQUIPMENT SHALL BE ABANDONED IN PLACE UNLESS OTHERWISE NOTED.
- ALL EQUIPMENT TO BE REUSED IS TO BE CLEANED. ANY EQUIPMENT FOUND TO BE NON-FUNCTIONING SHALL BE DOCUMENTED AND BROUGHT TO THE ATTENTION OF THE OWNER PRIOR TO COMMENCEMENT OF DEMOLITION. IF PROPER NOTIFICATION IS NOT PROVIDED THEN REPAIR OR REPLACEMENT OF THE EQUIPMENT SHALL BE MADE AT NO ADDITIONAL COST TO THE OWNER.
- THE MECHANICAL AND PLUMBING CONTRACTORS SHALL OBTAIN AND PAY FOR ALL PERMITS, FEES, AND INSPECTIONS REQUIRED FOR THEIR WORK. ALL MATERIALS REQUIRED FOR TESTING (E.G. - SMOKE GENERATORS) SHALL BE PROVIDED BY THE CONTRACTOR AT NO ADDITIONAL COST TO THE PROJECT. IF A PROJECT FAILS AN INSPECTION, THE CONTRACTOR SHALL BE RESPONSIBLE FOR ANY AND ALL COSTS ASSOCIATED WITH THE RE-INSPECTION.

ANY EQUIPMENT OR MATERIAL DEVIATIONS FROM THAT SPECIFIED OR DETAILED ON THIS DRAWING SHALL BE SUBJECT TO THE APPROVAL OF THE ARCHITECT/ENGINEER. ALL PROPOSED EQUIPMENT DEVIATIONS SUBMITTED SHALL BE SIMILAR BOTH IN QUALITY AND CAPACITY TO THAT EQUIPMENT SPECIFIED.

- ALL MECHANICAL AND PLUMBING EQUIPMENT SHALL BE LISTED AND LABELED BY APPROVED THIRD PARTY LISTING AGENCY.
- DUCTWORK AND PIPING LAYOUTS AND LOCATIONS ARE SCHEMATIC. DO NOT SCALE THESE DRAWINGS. EXACT ROUTING OF DUCTWORK AND PIPING MUST BE DETERMINED IN THE FIELD. ALL DIMENSIONS SHALL BE FIELD VERIFIED BY THE CONTRACTOR BY ACTUAL MEASUREMENT AND OBSERVATION BEFORE ORDERING OR FABRICATING ANY DUCTWORK, PIPING OR EQUIPMENT. ANY DISCREPANCIES BETWEEN THE REQUIREMENTS OF THE CONTRACT DOCUMENTS AND THE EXISTING CONDITIONS OR DIMENSIONS SHALL BE REPORTED TO THE ENGINEER BEFORE THE PERFORMANCE OF ANY WORK. FAILURE TO VERIFY AND REPORT SHALL CONSTITUTE THE CONTRACTOR'S ACCEPTANCE OF THE EXISTING CONDITIONS AS FIT FOR THE PROPER EXECUTION OF THEIR WORK.
- DUCTWORK AND PIPING SHALL BE KEPT AS CLOSE AND HIGH AS POSSIBLE TO THE BUILDING WALLS, CEILING AND FLOOR AND ROOF STRUCTURE IN ORDER THAT THE MAXIMUM AMOUNT OF SPACE IS AVAILABLE. ADDITIONAL OFFSETS, FITTINGS, ETC. NOT SHOWN BUT REQUIRED TO MAINTAIN MAXIMUM CLEARANCE SHALL BE PROVIDED AT NO ADDITIONAL COST.
- EXISTING FLOOR DRAINS SHALL BE COVERED DURING DEMOLITION AND NEW WORK CONSTRUCTION.

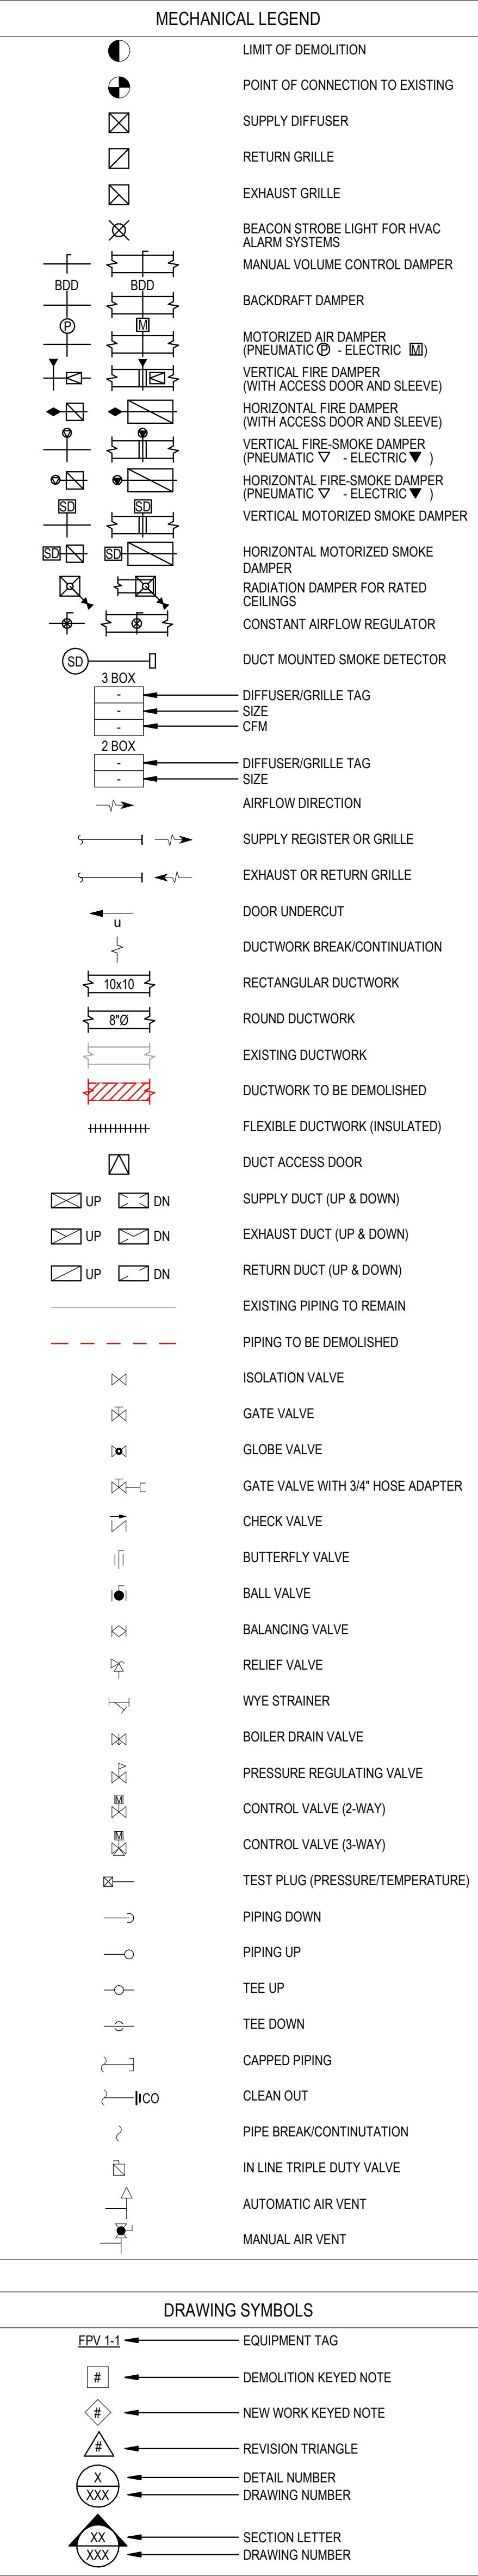

PLUMBING SPECIFICATIONS

- GENERAL
 - FURNISH ALL EQUIPMENT, MATERIALS, LABOR, TOOLS, ETC., FOR THE COMPLETE PLUMBING SYSTEM. INSTALL COMPLETE AND PLACE IN OPERATION.
 - CONFORM TO ALL GENERAL AND SPECIAL CONDITIONS OF CONTRACT AS SPECIFIED BY ARCHITECT AND/OR OWNER.
 - PRODUCTS AND INSTALLATION SHALL COMPLY WITH ALL APPLICABLE LAWS, CODES, GOVERNMENT REGULATIONS, UTILITY COMPANY REQUIREMENTS, ETC. OF ALL AUTHORITIES HAVING JURISDICTION, WHERE CONFLICTS EXIST BETWEEN CODES, STANDARDS OR THIS SPECIFICATION THE MOST STRINGENT SHALL APPLY. DEVIATIONS FROM THE CONTRACT DOCUMENTS REQUIRED BY THE ABOVE AUTHORITIES SHALL BE SUBMITTED TO THE ENGINEER FOR REVIEW, OBTAIN PERMITS AND PAY ALL FEES. ARRANGE FOR ALL REQUIRED INSPECTIONS AND APPROVALS. CONFIRM ALL UTILITY COMPANY REQUIREMENTS AND CONNECTION POINTS IN THE FIELD, PRIOR TO STARTING WORK.
 - ALL SPECIFICATIONS AND DRAWINGS, I.E., ARCHITECTURAL, MECHANICAL, PLUMBING, AND ELECTRICAL ARE COMPLEMENTARY AND MUST BE USED IN COMBINATION TO OBTAIN COMPLETE CONSTRUCTION INFORMATION. ANY INFORMATION CONFLICTS WITH THE SPECIFICATIONS AND DRAWINGS SHALL BE BROUGHT TO THE ENGINEER'S ATTENTION.
 - VISIT SITE, CHECK FACILITIES AND CONDITIONS MAKE ALL NECESSARY OBSERVATIONS, MEASUREMENTS, NOTE CONDITIONS UNDER WHICH WORK IS TO BE PERFORMED, AND TAKE ALL ITEMS INTO CONSIDERATION IN BID.
 - THE CONTRACTOR SHALL PROVIDE FOR THEIR OWN CLEAN-UP, REMOVAL AND LEGAL DISPOSAL OF ALL RUBBISH DAILY. CONTRACTORS SHALL PROTECT THEIR WORK AND EXISTING OR ADJACENT PROPERTY AGAINST WEATHER, TO MAINTAIN THEIR WORK, MATERIALS, APPARATUS AND FIXTURES FREE FROM INJURY OR DAMAGE. ANY WORK DAMAGED BY FAILURE TO PROVIDE THE PROTECTION REQUIRED SHALL BE REMOVED AND REPLACED WITH NEW WORK AT THE CONTRACTOR'S EXPENSE.
 - THE CONTRACTOR SHALL COORDINATE WITH THE OWNER'S PROJECT MANAGER PRIOR TO, AND FOR, SCHEDULING ANY INTERRUPTION OF ANY BUILDING UTILITY.
 - THE CONTRACTOR SHALL BE SOLELY RESPONSIBLE FOR CONSTRUCTION MEANS, METHODS AND SEQUENCES OF CONSTRUCTION AND THE SAFETY OF WORKMEN.
 - WORK RELATED TO THE EXISTING BUILDING SHALL BE COORDINATED TO MINIMIZE THE INTERFERENCE OR INTERRUPTION OF NORMAL BUILDING USE BY OWNER. REFER TO ARCHITECTURAL PLANS FOR PHASING REQUIREMENTS.
 - IN CASES OF DOUBT AS TO THE WORK INTENDED, OR IN THE EVENT OF NEED FOR EXPLANATION THEREOF, THE CONTRACTOR SHALL REQUEST SUPPLEMENTARY INSTRUCTIONS FROM THE ENGINEER. NO CHANGES ARE TO BE MADE TO THE WORK OF THIS CONTRACT WITHOUT PRIOR KNOWLEDGE AND APPROVAL OF THE ENGINEER. THE CONTRACTOR SHALL HOLD THE OWNER AND ITS CONSULTANTS HARMLESS AGAINST ALL CLAIMS AND JUDGEMENTS ARISING OUT OF THE CONTRACTOR'S PERFORMANCE OF THE WORK OF THIS CONTRACT. THE CONTRACTOR SHALL NOT PROCEED WITH ANY WORK IN WHICH ADDITIONAL COMPENSATION IS EXPECTED BEYOND THE CONTRACT AMOUNT WITHOUT WRITTEN AUTHORIZATION FROM THE APPROPRIATE AUTHORITY. FAILURE TO OBTAIN SUCH AUTHORIZATION SHALL INVALIDATE ANY CLAIM FOR EXTRA COMPENSATION.
 - IT SHALL BE THE RESPONSIBILITY OF THIS CONTRACTOR TO INSTALL ALL SYSTEMS SO AS TO ENSURE QUIET OPERATION. NO VIBRATION OR SOUND SHALL BE TRANSMITTED TO THE BUILDING, STRUCTURE OR OCCUPIED AREAS. THE DECISION OF THE ENGINEER AS TO THE QUIETNESS OF THE SYSTEM AND EQUIPMENT SHALL BE FINAL. IT SHALL BE THIS CONTRACTOR'S RESPONSIBILITY TO CORRECT OR REPLACE ANY NOISY SYSTEM OR EQUIPMENT AS REQUIRED.
 - ALL CONCRETE WORK SHALL CONFORM TO THE REQUIREMENTS OF ACI 301 "SPECIFICATIONS FOR STRUCTURAL CONCRETE FOR BUILDINGS", LATEST EDITION, ALL REINFORCING BARS SHALL CONFORM TO ASTM A615, GRADE 60, EXCEPT TIES, WHICH MAY BE GRADE 40. ALL REINFORCING BARS SHALL BE FABRICATED AND PLACED IN ACCORDANCE WITH ACI 315 AND CONCRETE REINFORCING STEEL INSTITUTE RECOMMENDATIONS. CONCRETE CURING PROCEDURES SHALL BE IN ACCORDANCE WITH ACI 301. CONCRETE SHALL BE NORMAL WEIGHT CONCRETE WITH 3500 PSI MINIMUM 28 DAY COMPRESSION STRENGTH.
- DRAWINGS
 - DRAWINGS ARE DIAGRAMMATIC AND ARE INTENDED TO CONVEY THE SCOPE AND GENERAL ARRANGEMENT OF WORK. CONFIRM ALL DIMENSIONS BY FIELD MEASUREMENT.
 - THE EXACT LOCATIONS FOR APPARATUS, FIXTURES, EQUIPMENT AND PIPING WHICH IS NOT COVERED BY DRAWINGS, SHALL BE OBTAINED FROM THE ARCHITECT OR THEIR REPRESENTATIVE IN THE FIELD, AND THE WORK SHALL BE LAID OUT ACCORDINGLY.
 - ALL OFFSETS, RISES, TRANSITIONS AND DROPS IN PIPING AROUND OBSTRUCTIONS SHALL BE PROVIDED AT NO ADDITIONAL COST TO THE OWNER.
 - LOCATIONS OF TERMINAL DEVICES, PLUMBING FIXTURES, ETC., ARE APPROXIMATE. LOCATE PER THE ARCHITECTURAL DRAWINGS AND TO AVOID OTHER TRADES WORK. COORDINATE LOCATIONS WITH OTHER TRADES. CONSULT ARCHITECT/ENGINEER FOR CLARIFICATION IF CONFLICTS OCCUR.
 - DRAWINGS AND SPECIFICATIONS ARE INTENDED TO BE SUPPLEMENTARY. ANY MATERIALS, LABOR OR SERVICES REQUIRED BY EITHER IS TO BE CONSIDERED AS REQUIRED FOR THE PROJECT.
 - THE CONTRACTOR SHALL PROVIDE AS-BUILT DRAWINGS UPON PROJECT COMPLETION.
- DEMOLITION
 - DEMOLITION SHALL BE DONE IN A MANNER TO NOT DAMAGE ADJACENT WALLS AND NOT AFFECT THE OPERATION OF SYSTEMS TO REMAIN IN USE. ANY ITEM TO REMAIN THAT IS DAMAGED BY THE CONTRACTOR OR THAT REQUIRES DAMAGE DUE TO THE ABSOLUTE NECESSITY FOR DEMOLITION REQUIREMENTS SHALL BE REPLACED AND/OR REPAIRED AT THE CONTRACTOR'S EXPENSE.
 - DISCONNECT, DISASSEMBLE, CAP, PLUG AND REMOVE ALL VENT ELEMENTS (PIPING, ELECTRICAL DEVICES, WIRING, CONDUIT, EQUIPMENT, HANGERS, SUPPORTS, ETC.) INDICATED ON THE DRAWINGS OR NOT OTHERWISE REQUIRED FOR COMPLETED PRODUCT. NO MEP ELEMENTS ARE TO BE ABANDONED IN PLACE UNLESS SPECIFICALLY NOTED. NOT ALL ITEMS TO BE REMOVED ARE INDICATED ON DRAWING.
 - ALL OPENINGS IN PIPING THAT REMAIN SHALL BE CAPPED AND PROPERLY SECURED. WIRING SHALL BE DISCONNECTED AT CIRCUIT BREAKERS AND REMOVED AND BREAKERS MARKED "SPARE".
 - ANY EQUIPMENT DESIGNATED BY OWNER TO BE SALVAGED SHALL BE PROTECTED AND DELIVERED TO AN OWNER DESIGNATED AREA ON SITE.
- CUTTING, PATCHING AND DRILLING
 - ALL CUTTING AND PATCHING OF THE BUILDING CONSTRUCTION REQUIRED FOR THE DIVISIONS OF THE WORK SHALL BE BY THE RESPECTIVE CONTRACTOR REQUIRING SAME UNLESS THIS WORK IS INDICATED ON ARCHITECTURAL DRAWINGS AND CONFIRMED AS TO SIZE AND LOCATION PRIOR TO NEW CONSTRUCTION. CUTTING SHALL BE IN A NEAT AND WORKMANLIKE MANNER SO AS TO MINIMIZE PATCHING.
 - NEATLY SAW CUT ALL RECTANGULAR OPENINGS, SET SLEEVE THROUGH OPENING, AND FINISH PATCH OR PROVIDE TRIM FLANGE AROUND OPENING.
 - NEATLY SAW CUT FLOORS FOR SEWER INSTALLATION AND PATCH FLOOR TO MATCH EXISTING, INCLUDING FLOOR COVERING OR FINISH.
 - CORE DRILL AND SLEEVE OPENINGS.
 - DO NOT CUT ANY STRUCTURAL COMPONENTS WITHOUT THE ARCHITECT'S APPROVAL.
 - PATCH AND FINISH TO MATCH ADJACENT AREAS THAT HAVE BEEN CUT, DAMAGED OR MODIFIED AS A RESULT OF THE INSTALLATION OF PLUMBING EQUIPMENT. FIRE STOP ALL PENETRATIONS OF FIRE RATED CONSTRUCTION IN A CODE APPROVED MANNER.
 - THE CONTRACTOR SHALL CONFORM WITH OWNER, PRIOR TO DOING, TIMES AVAILABLE FOR ROUSE PRODUCING WORKSUCH AS CUTTING AND CORE DRILLING OF FLOORS, WALLS, ETC., AS WELL AS TIMES FOR WORK WHICH REQUIRES ACCESS INTO ADJOINING TENANT SPACES. INCLUDE ANY REQUIRED PREMIUM TIME TO COMPLY WITH THESE TIMES IN BID.
 - INFORMATION REGARDING REQUIRED PIPE OR OTHER OPENINGS IN WALLS, FLOORS, CHASES, ETC., AND CONCRETE EQUIPMENT PADS OR FOUNDATIONS ARE TO BE PROVIDED TO THE GENERAL CONTRACTOR BY THIS CONTRACTOR PRIOR TO THE CONSTRUCTION PERIOD. IF THIS CONTRACTOR FAILS TO COMPLY WITH THIS REQUEST, OR PROVIDES INCORRECT INFORMATION, THIS CONTRACTOR WILL BE RESPONSIBLE FOR ALL CORRECTIVE COSTS FOR ALL NECESSARY CUTTING, PATCHING OR OTHER CORRECTION WHICH WILL BE PERFORMED BY THE GENERAL CONTRACTOR.
- WARRANTY
 - INCLUDED AS A PART OF THE WORK UNDER EACH PLUMBING, MECHANICAL, OR ELECTRICAL SECTION, ALL MATERIALS, APPARATUS, AND EQUIPMENT INSTALLED AND SERVICES TO BE PROVIDED ARE WARRANTED FREE FROM DEFECTS IN MATERIALS AND WORKMANSHIP. ANY PORTION OF THE WORK WHICH MAY PROVE DEFECTIVE WITHIN A PERIOD OF ONE (1) YEAR FROM THE DATE OF ACCEPTANCE OF THE WORK BY THE OWNER, SHALL BE REPLACED OR REPAIRED IN AN APPROVED MANNER WITHOUT ADDITIONAL COST TO THE OWNER, IN ADDITION TO THIS ONE (1) YEAR WARRANTY.
 - WITH REGARD TO THE TIME OF DISCOVERY, ANY AND ALL PORTIONS OF THE WORK FOUND NOT IN COMPLIANCE WITH THE CONTRACT SHALL BE REPLACED OR REPAIRED IN AN APPROVED MANNER WITHOUT ADDITIONAL COST TO THE OWNER, SAID REPAIR OR REPLACEMENT SHALL BE REQUIRED AS THE SPECIFIC PERFORMANCE OF THE CONTRACT AND IS NOT TO BE CONSIDERED AS WAIVING ANY OTHER RECOURSE OR REMEDIES AVAILABLE TO THE OWNER.
- SHOP DRAWING SUBMITTALS
 - SUBMIT SHOP DRAWINGS FOR PLUMBING FIXTURES WITH ADEQUATE DETAILS AND SCALES TO CLEARLY INDICATE CONSTRUCTION. INDICATE THE OPERATING CHARACTERISTICS FOR EACH REQUIRED ITEM. CLEARLY IDENTIFY EACH ITEM ON THE SUBMITTAL AS TO MARK, LOCATION AND USE. USING SAME IDENTIFICATION AS PROVIDED ON DESIGN DRAWINGS. STRIKE OUT ALL ITEMS THAT DO NOT APPLY TO THIS PROJECT.
 - THE CONTRACTOR SHALL ALLOW SUFFICIENT TIME (2 WEEKS) FOR SHOP DRAWING REVIEWS BY THE ENGINEER TO MEET THE OWNER'S CONSTRUCTION SCHEDULE.
 - CONTRACTOR SHALL REVIEW AND INDICATE APPROVAL OF EACH SHOP DRAWING PRIOR TO SUBMITTAL FOR REVIEW. ALL COSTS FOR STARTING WORK OR FABRICATION PRIOR TO SHOP DRAWING REVIEW AND RETURN TO THE CONTRACTOR ARE THE RESPONSIBILITY OF THE CONTRACTOR.
 - SUBMITTALS WILL BE REVIEWED ONLY FOR GENERAL COMPLIANCE WITH THE CONTRACT DOCUMENTS AND NOT FOR DIMENSIONS OR QUANTITIES. THE SUBMITTAL REVIEW DOES NOT WAIVE THE CONTRACTOR'S RESPONSIBILITY FOR PURCHASE OF ANY ITEM OR COMPLETE COMPLIANCE WITH THE CONTRACT DOCUMENTS.
 - WHERE SUBMITTALS VARY FROM THE CONTRACT REQUIREMENTS, THE CONTRACTOR SHALL CLEARLY INDICATE THE NATURE AND REASON FOR VARIATIONS ON SUBMITTAL OR ACCOMPANYING DOCUMENTS.
 - THE CONTRACTOR MUST CHECK THE APPLICATION OF EQUIPMENT AND CERTIFY AT TIME OF SHOP DRAWING SUBMITTAL THAT EQUIPMENT HAS BEEN PROPERLY APPLIED AND CAN BE INSTALLED, SERVICED AND MAINTAINED WHERE INDICATED ON DRAWINGS. ADVISE ENGINEER IN WRITING WITH SUBMITTAL DRAWINGS OF ANY POTENTIAL PROBLEMS. WHERE CERTIFICATION IS NOT EXPRESSED, SUBMITTAL IMPLIES CERTIFICATION.
- RECORD DRAWINGS (AS-BUILTS)
 - EACH CONTRACTOR OR SUBCONTRACTOR SHALL KEEP ONE (1) COMPLETE SET OF THE CONTRACT WORKING DRAWINGS ON THE JOB SITE AND REGULARLY RECORD ANY DEVIATIONS OR CHANGES FROM SUCH CONTRACT DRAWINGS MADE DURING CONSTRUCTION.
 - THESE DRAWINGS SHALL RECORD THE LOCATION OF ALL CONCEALED EQUIPMENT, PIPING, SEWERS, SANITARY PIPING, VENTS, AND OTHER PIPING, BY MEASURED DIMENSIONS TO EACH SUCH ITEM FROM READILY IDENTIFIABLE AND ACCESSIBLE WALLS OR CORNERS OF THE BUILDING. PLANS ALSO SHALL SHOW INVERT ELEVATION OF SEWERS AND TOP ELEVATION OF ALL OTHER BELOW-GRADE PIPING.
 - RECORD DRAWINGS SHALL BE KEPT CLEAN AND UNDAUNAGED AND SHALL NOT BE USED FOR ANY PURPOSE OTHER THAN RECORDING DEVIATIONS FROM WORKING DRAWINGS AND EXACT LOCATIONS OF CONCEALED WORK.
 - AT PROJECT COMPLETION, SCANDED PDF COPY OF THE AS-BUILT DRAWING SHALL BE DELIVERED AT PROJECT COMPLETION TO THE ARCHITECT OR OWNER, AS DIRECTED, IN GOOD CONDITION, AS A PERMANENT RECORD OF THE INSTALLATION AS ACTUALLY CONSTRUCTED.

PRINCIPAL IN CHARGE: MS
PROJECT ARCHITECT: TAS
DRAWN BY: JMW

SHEET NAME:
**MECHANICAL
SYMBOLS, NOTES,
AND ABBREVIATIONS**

SHEET NO. PROJECT NUMBER:
JAZZID_14452

A/E PROJECT #:
02600404.00

MP001



McKIM & CREED

8020 Tower Point Drive
Charlotte, NC 28227
704.841.2588 (Voice)
704.841.2587 (Fax)
NC License # F-1222

Designed JMW
Checked JMW
Date 07/15/2026

Drawn JMW
Date 07/15/2026
Project No. 06681-0043

THE INFORMATION CONTAINED HEREIN IS THE PROPERTY OF MCKIM & CREED, INC. NO REPRODUCTION, ALTERATION, OR USE FOR OTHER THAN THE PROJECT FOR WHICH IT WAS PREPARED IS PERMITTED WITHOUT THE WRITTEN PERMISSION OF MCKIM & CREED, INC. IT IS EXPRESSLY FORBIDDEN TO REPRODUCE, COPY, MIRROR, OR ALTER THIS INFORMATION.




Atrium Health

PROJECT & CONSTRUCTION MANAGEMENT
1400 East Morehead St.
Charlotte, NC 28204






McKIM & CREED
ENGINEERS SURVEYORS PLANNERS

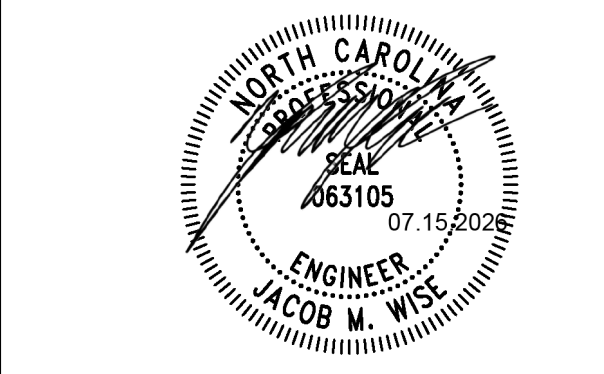


AH CABARRUS BH RENOVATION

AH Cabarrus Memorial Building
Atrium Health Facility # 1232
920 Church Street North, Concord, NC 28025


ISSUE DATE:	07/15/2026	
PHASE:	Construction Documents	
SHEET ISSUE:		
NO.	DATE	DESCRIPTION

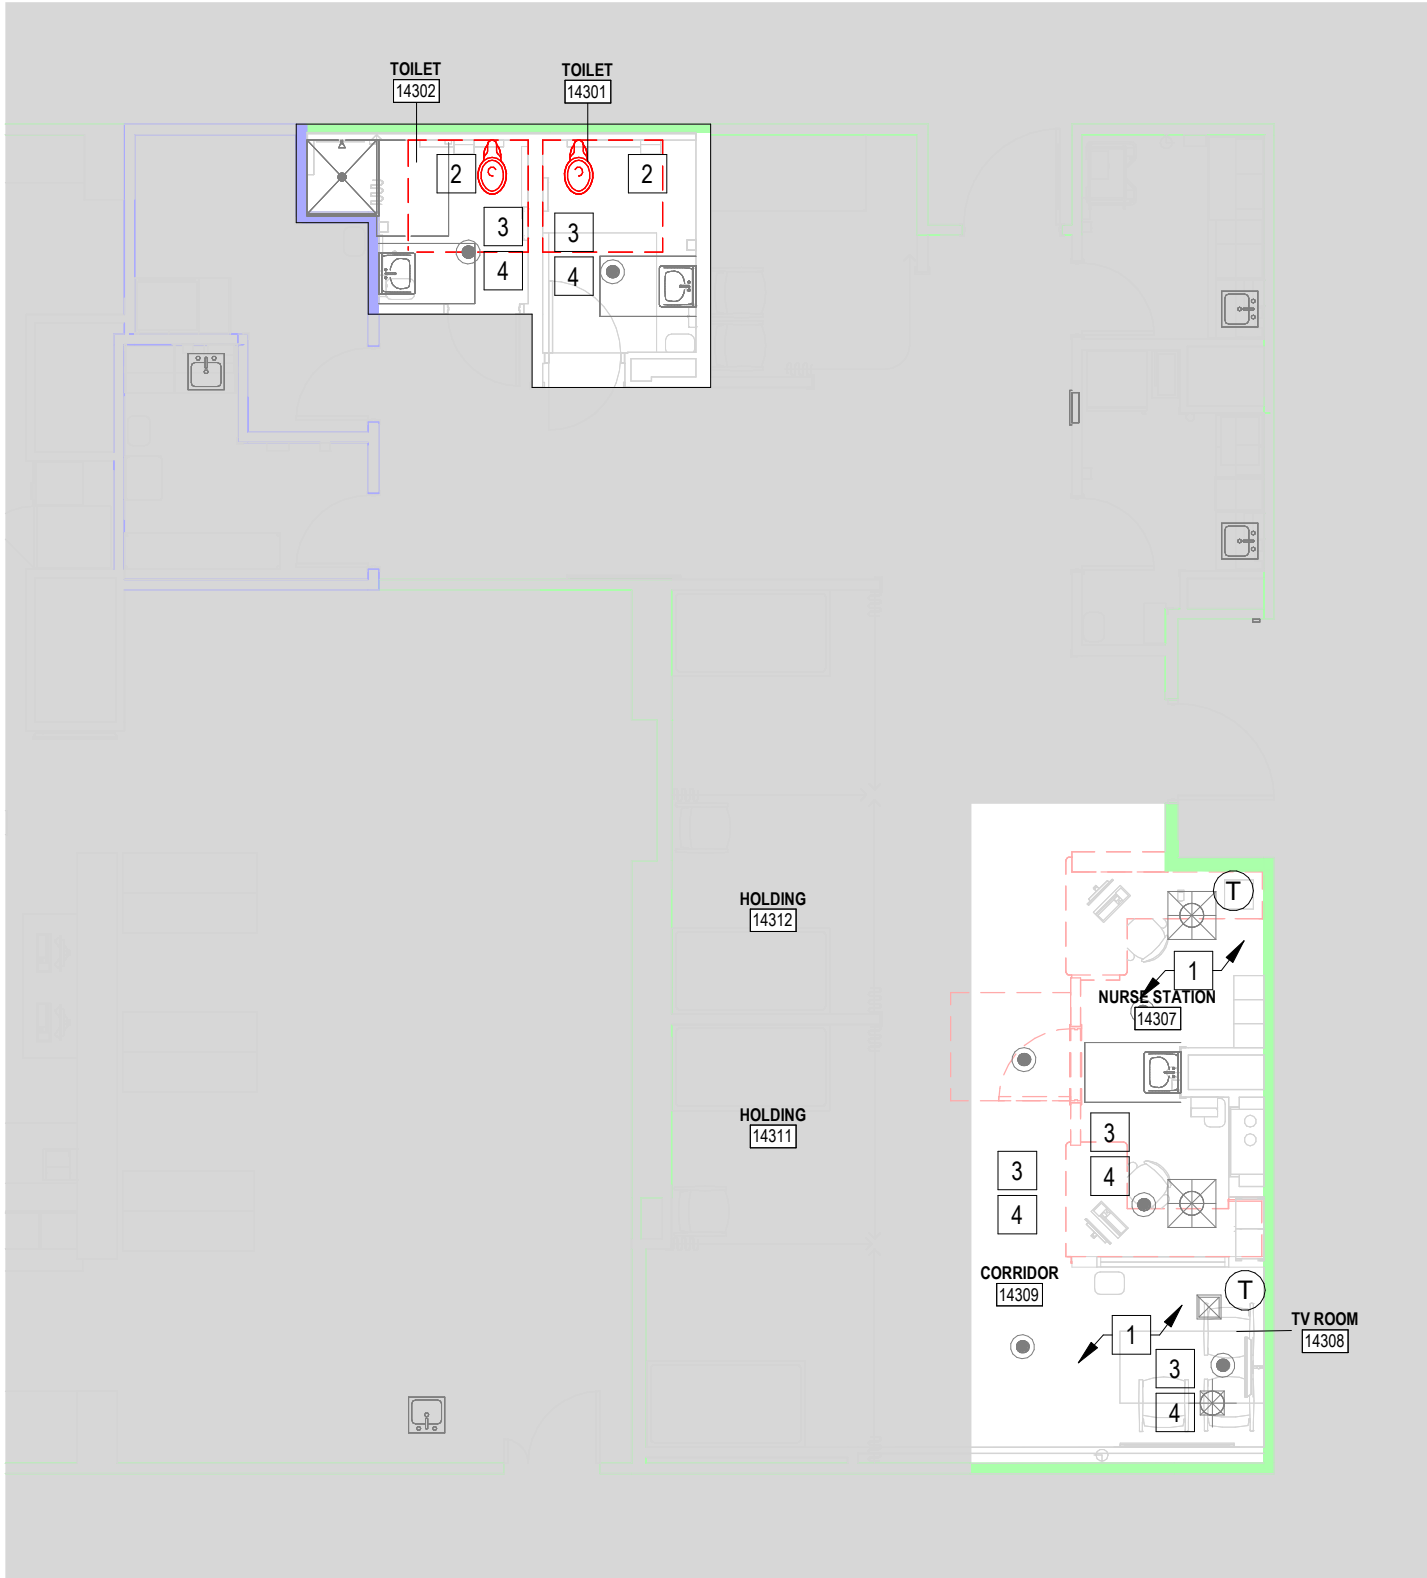

1 LEVEL 01 - AREA A - BH 1 - MECHANICAL - DEMOLITION PLAN
SCALE: 1/8" = 1'-0"

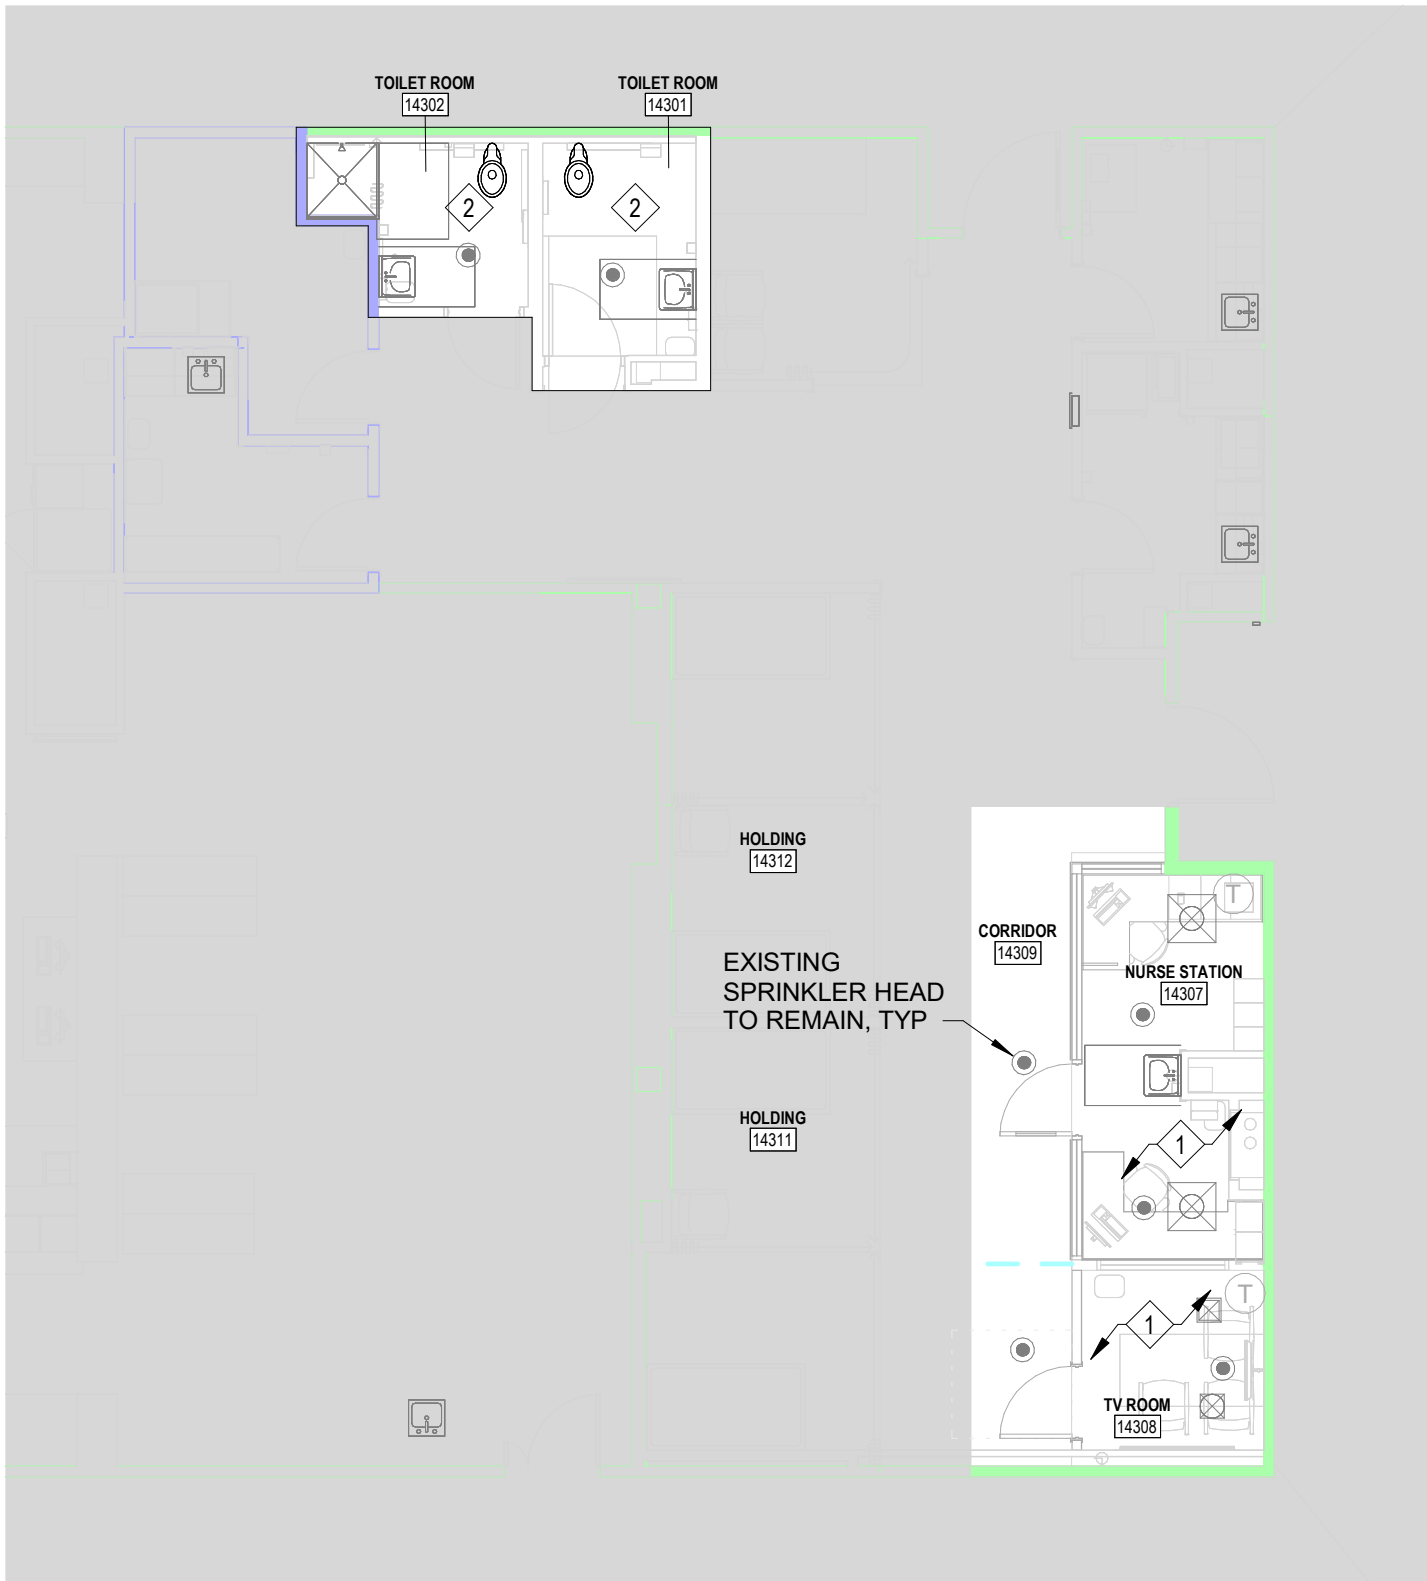

2 LEVEL 01 - AREA A - BH 1 - MECHANICAL - NEW WORK PLAN
SCALE: 1/8" = 1'-0"

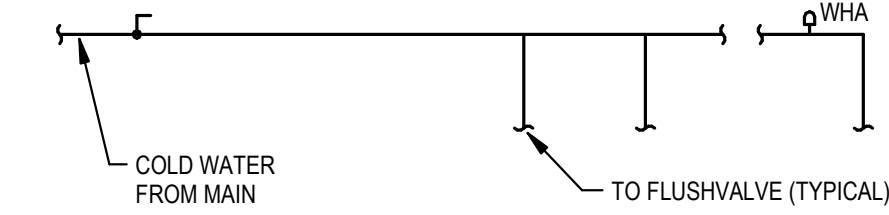

WATER HAMMER ARRESTOR SCHEDULE *	
NO. OF FIXTURE UNITS	ZURN SERIES
1 - 11	Z-1700 - 100
12 - 32	Z-1700 - 200
33 - 60	Z-1700 - 300
61 - 113	(2) Z-1700 - 300

* FOR FIXTURE UNITS IN EXCESS OF 113 VERIFY SIZE AND No. PRIOR TO INSTALLATION.
URINAL - 5 F.U., WATER CLOSET - 10 F.U., CLINIC SERVICE SINK - 10 F.U., BED PAN WASHER - 10 F.U.

3 WATER HAMMER ARRESTOR PIPING DIAGRAM
SCALE: NTS

PIPING INSULATION MATERIAL AND WALL THICKNESS						
SERVICE	INSULATION MATERIAL	VAPOR BARRIER REQUIRED	INSULATION WALL THICKNESS AT THE FOLLOWING NOMINAL PIPE DIAMETERS			
			1" and Less	1 1/4" - 2"	NOT USED	NOT USED
DOMESTIC HOT WATER AND RECIRCULATING PIPING	GLASS FIBER	NO	1"	1 1/2"		
DOMESTIC COLD WATER PIPING	GLASS FIBER	YES	1"	1"		


4 PIPING INSULATION MATERIAL AND WALL THICKNESS
SCALE: NTS

- GENERAL NOTES:
- PLUMBING CONTRACTOR SHALL COORDINATE THE SHUTDOWN OF AREA OF WORK A MINIMUM OF 2 WEEKS PRIOR WITH ATRIUM HEALTH PROJECT MANAGER, DEPARTMENT MANAGER AND POM.
 - PLUMBING CONTRACTOR SHALL FIELD VERIFY ACTUAL LOCATIONS AND SIZES OF ALL EXISTING EQUIPMENT AND PIPING PRIOR TO PROVIDING PRICING.
 - NEW PIPING SHALL BE INSULATED AS SHOWN IN THE PIPING INSULATION SCHEDULE THIS SHEET. ANY INSULATION DAMAGED BY THE NEW WORK SHALL BE REPAIRED ACCORDING TO THE PIPING INSULATION SCHEDULE.
- DEMOLITION KEY NOTES:
- CEILING MOUNTED DEVICES SHOWN FOR COORDINATION PURPOSES ONLY. COORDINATE WITH ARCHITECTURAL SCOPE AS REQUIRED.
 - DEMOLISH EXISTING TOILET. PREPARE ASSOCIATED PIPING FOR CONNECTION TO NEW TOILET IN NEW WORK PHASE OF PROJECT. EXISTING FLUSH VALVE AND SENSOR TO REMAIN.
 - EXISTING SPRINKLER HEADS, THIS SPACE, TO REMAIN. CONFIRM EXISTING SPRINKLERS, THIS SPACE, ARE IMPACT, TAMPER, AND LIGATURE-RESISTANT AND NOTIFY THE ENGINEER IMMEDIATELY IF ANY DISCREPANCIES ARE FOUND.
 - EXISTING AIR DISTRIBUTION DEVICES, THIS SPACE, TO REMAIN. CONFIRM EXISTING AIR DISTRIBUTION DEVICES, THIS SPACE, ARE IMPACT, TAMPER, AND LIGATURE-RESISTANT AND NOTIFY THE ENGINEER IMMEDIATELY IF ANY DISCREPANCIES ARE FOUND.
- NEW WORK KEY NOTES:
- CEILING MOUNTED DEVICES SHOWN FOR COORDINATION PURPOSES ONLY. COORDINATE WITH ARCHITECTURAL SCOPE AS REQUIRED.
 - PROVIDE NEW LIGATURE AND VANDAL RESISTANT SOLID SURFACE, BACK-TO-WALL TOILET SUITABLE FOR THROUGH THE WALL INSTALLATION AND CONNECTION TO EXISTING DOMESTIC WATER, SANITARY WASTE AND SANITARY VENT PIPING. BASIS OF DESIGN CWC156 BY BRITEX WITH DARK GREY FIXED SEAT. FIXTURE SHALL BE PROVIDED WITH INLET SEAL AND WASTE ADAPTOR TO ALLOW FOR INSTALLATION USING THE EXISTING 4-1/4" ROUGH-IN. PLUMBING CONTRACTOR SHALL FIELD VERIFY COMPATIBILITY WITH THE EXISTING WASTE ROUGH-IN PRIOR TO PROVIDING PRICING. EXISTING FLUSH VALVE AND SENSOR PLATE SHALL REMAIN. PLUMBING CONTRACTOR SHALL CONFIRM COMPATIBILITY, AND INCLUDE IN THEIR PRICING, ANY ADJUSTMENT REQUIRED TO CONNECT THE NEW FIXTURE TO THE EXISTING FLUSH VALVE. ENSURE WATER HAMMER ARRESTOR IS PROVIDED.

LIFE SAFETY LEGEND

RATING LEGEND	
RGB 000-000-000	BUILDING SEPARATION
RGB 255-000-000	3 HR & 4 HR FIRE WALL SEPARATION (NCBC SECTION 706)
RGB 255-000-000	2 HR FIRE BARRIER (NCBC SECTION 707)
RGB 255-127-191	2 HR FIRE/SMOKE BARRIER (NCBC SECTION 407.5709)
RGB 111-000-127	1 HR FIRE BARRIER (NCBC SECTION 707)
RGB 000-000-255	1 HR FIRE/SMOKE BARRIER (NCBC SECTION 407.5709)
RGB 155-145-042	1 HR FIRE PARTITION (NCBC SECTION 708)
RGB 000-255-255	SMOKE PARTITION (NCBC SECTION 407.710)
RGB 000-255-000	SUITE BOUNDARY (NCBC SECTION 407.4.4.2.710)
RGB 255-127-000	

KEY PLAN

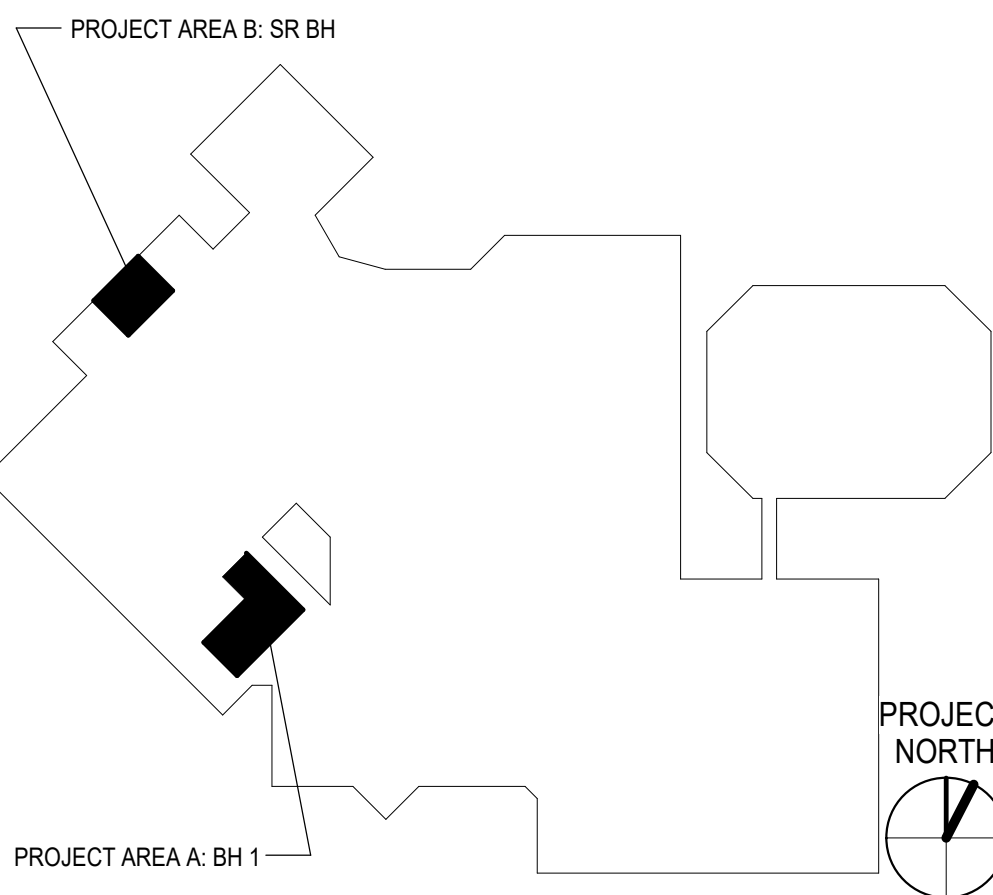

PRINCIPAL IN CHARGE: MS
PROJECT ARCHITECT: TAS
DRAWN BY: JMW

SHEET NAME:
**MECHANICAL AND
PLUMBING - LEVEL 01
- DEMOLITION & NEW
WORK PLAN**

SHEET NO. PROJECT NUMBER:
JAZZID_14452

A/E PROJECT #:
02600404.00

MP101

ALL DRAWINGS, SPECIFICATIONS AND NOTES HEREOF FURNISHED BY MC MILLAN PAZDAN SMITH ARCHITECTURE ARE AND SHALL REMAIN THE PROPERTY OF MC MILLAN PAZDAN SMITH ARCHITECTURE. THESE DRAWINGS ARE TO BE USED ONLY WITH RESPECT TO THE PROJECT AND NOT TO BE REPRODUCED OR COPIED IN ANY MANNER WITHOUT THE WRITTEN CONSENT OF MC MILLAN PAZDAN SMITH ARCHITECTURE. ANY REUSE OR MODIFICATION OF THESE DRAWINGS WITHOUT THE WRITTEN CONSENT OF MC MILLAN PAZDAN SMITH ARCHITECTURE IS PROHIBITED. SUBMISSION OF THESE DRAWINGS TO ANY OTHER PROJECT OR FOR ANY OTHER PURPOSE WITHOUT THE WRITTEN CONSENT OF MC MILLAN PAZDAN SMITH ARCHITECTURE IS PROHIBITED. ALL RIGHTS RESERVED.


THIS DRAWING IS AN INSTRUMENT OF SERVICE. THE DESIGN AND INFORMATION THEREON IS THE PROPERTY OF MC MILLAN PAZDAN SMITH ARCHITECTURE, INC. NO PORTION OF THIS DRAWING IS TO BE REPRODUCED OR COPIED IN ANY MANNER WITHOUT THE WRITTEN CONSENT OF MC MILLAN PAZDAN SMITH ARCHITECTURE, INC. ANY REUSE OR MODIFICATION OF THIS DRAWING WITHOUT THE WRITTEN CONSENT OF MC MILLAN PAZDAN SMITH ARCHITECTURE, INC. IS EXPRESSLY FORBIDDEN. COPYRIGHT 2026, MC MILLAN PAZDAN SMITH ARCHITECTURE, INC.

A


B

C


D

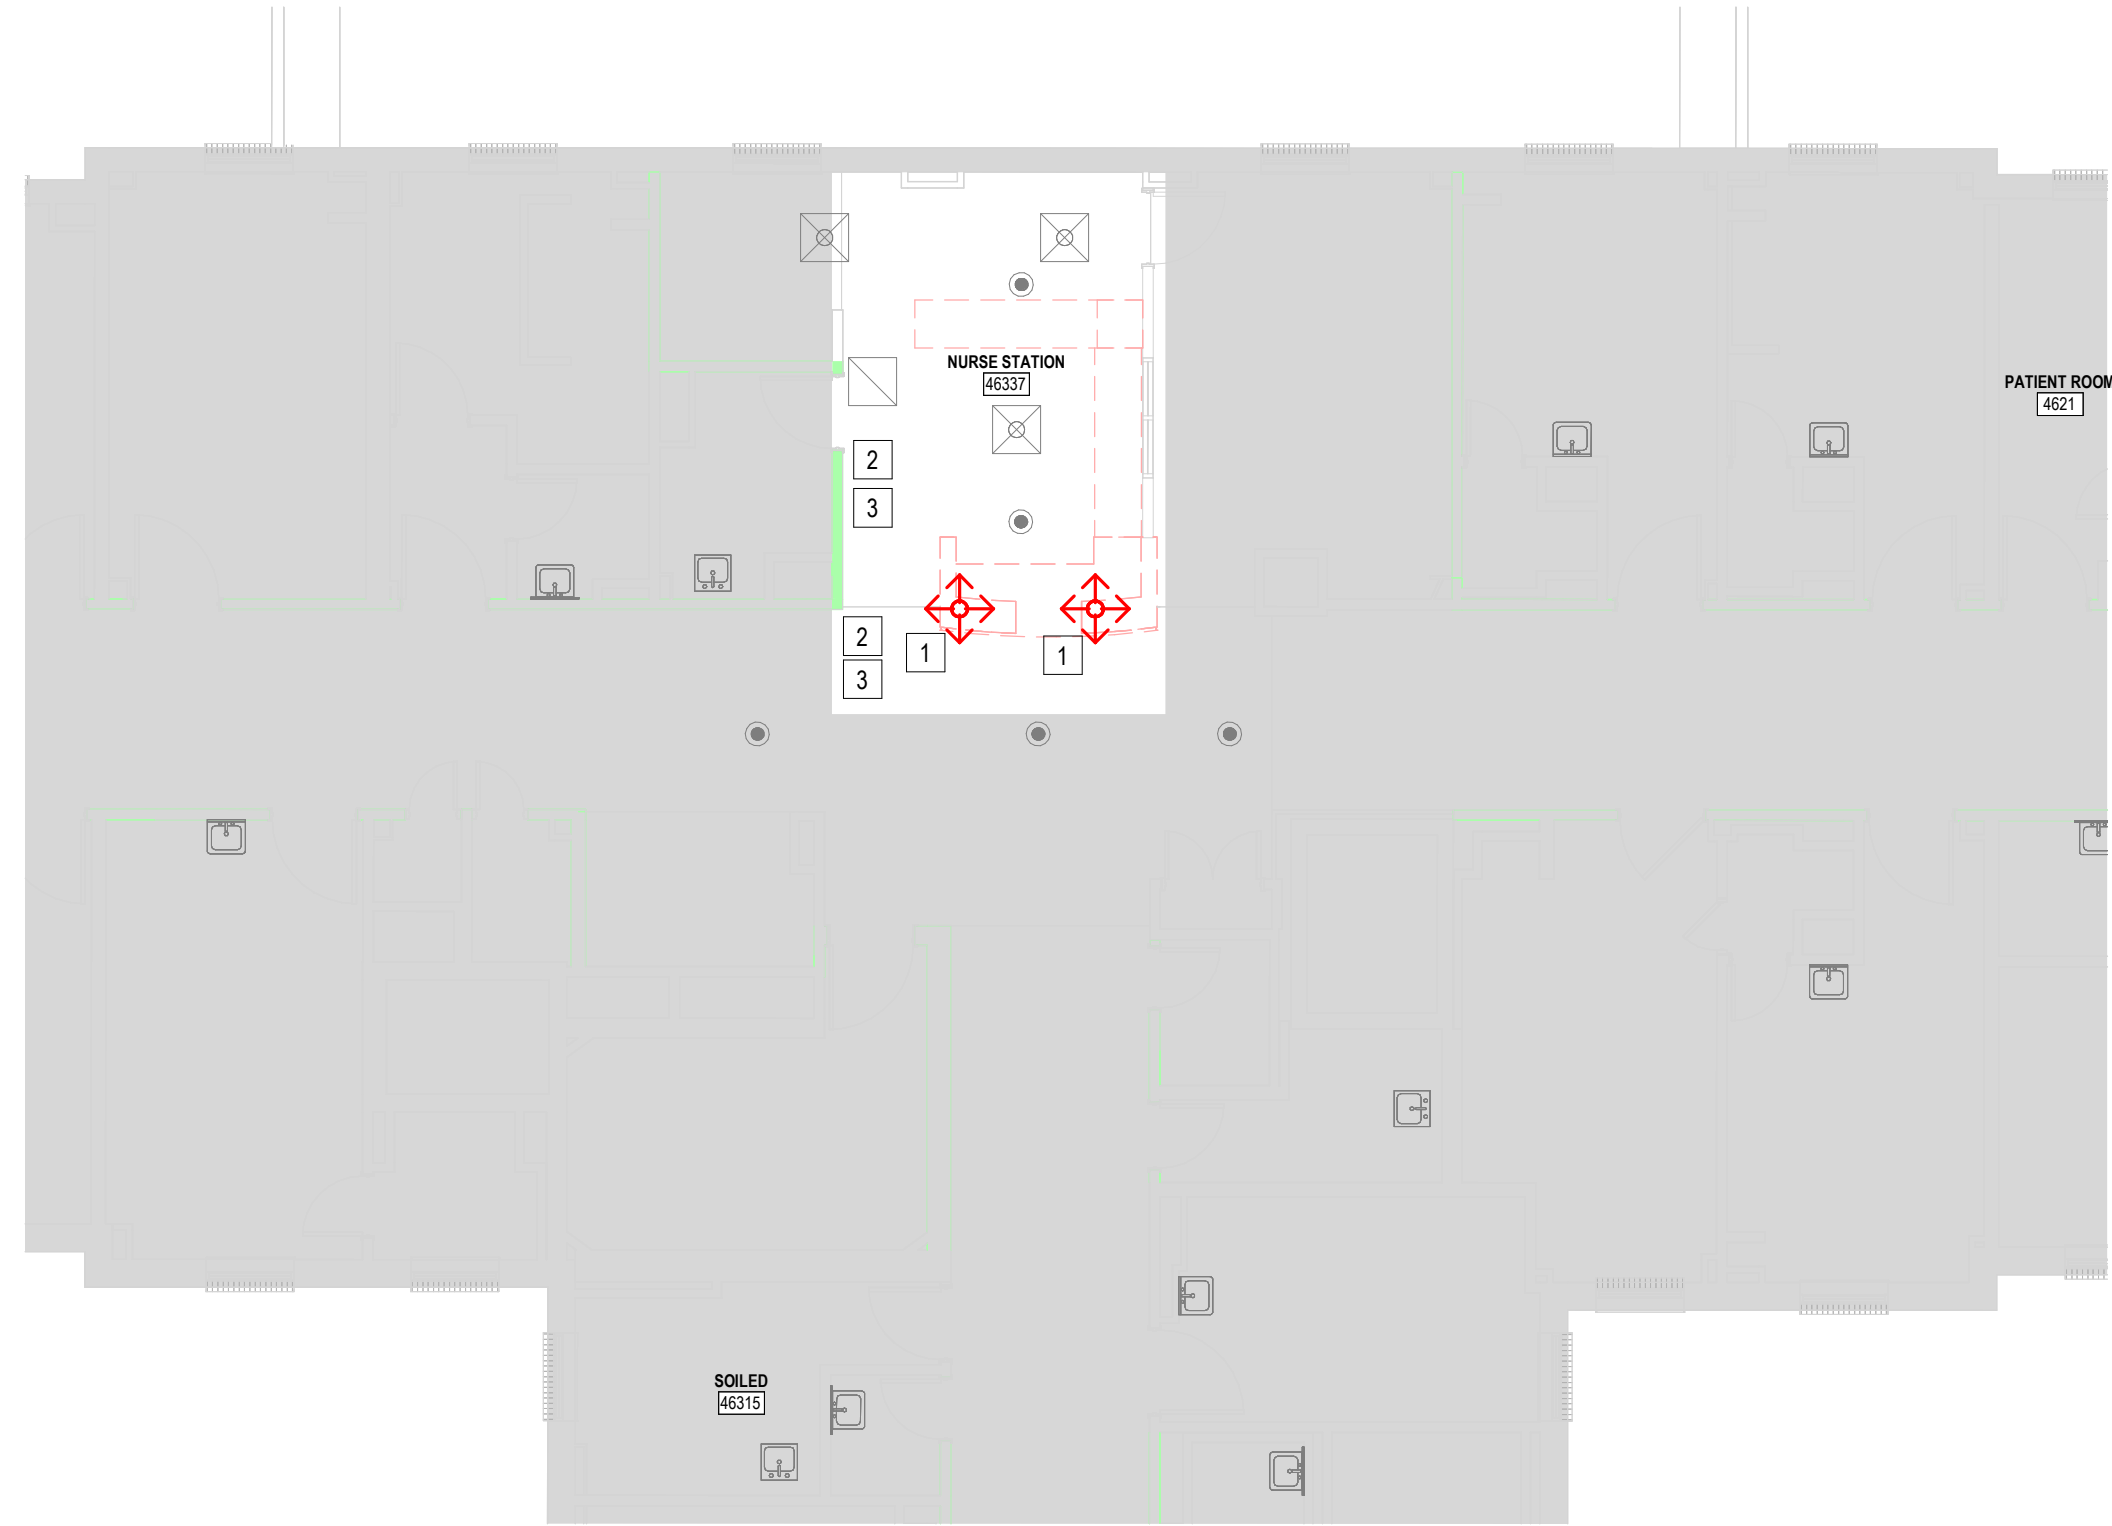

1 LEVEL 04 - AREA B - SENIOR BH - MECHANICAL - DEMOLITION PLAN
SCALE: 1/8" = 1'-0"

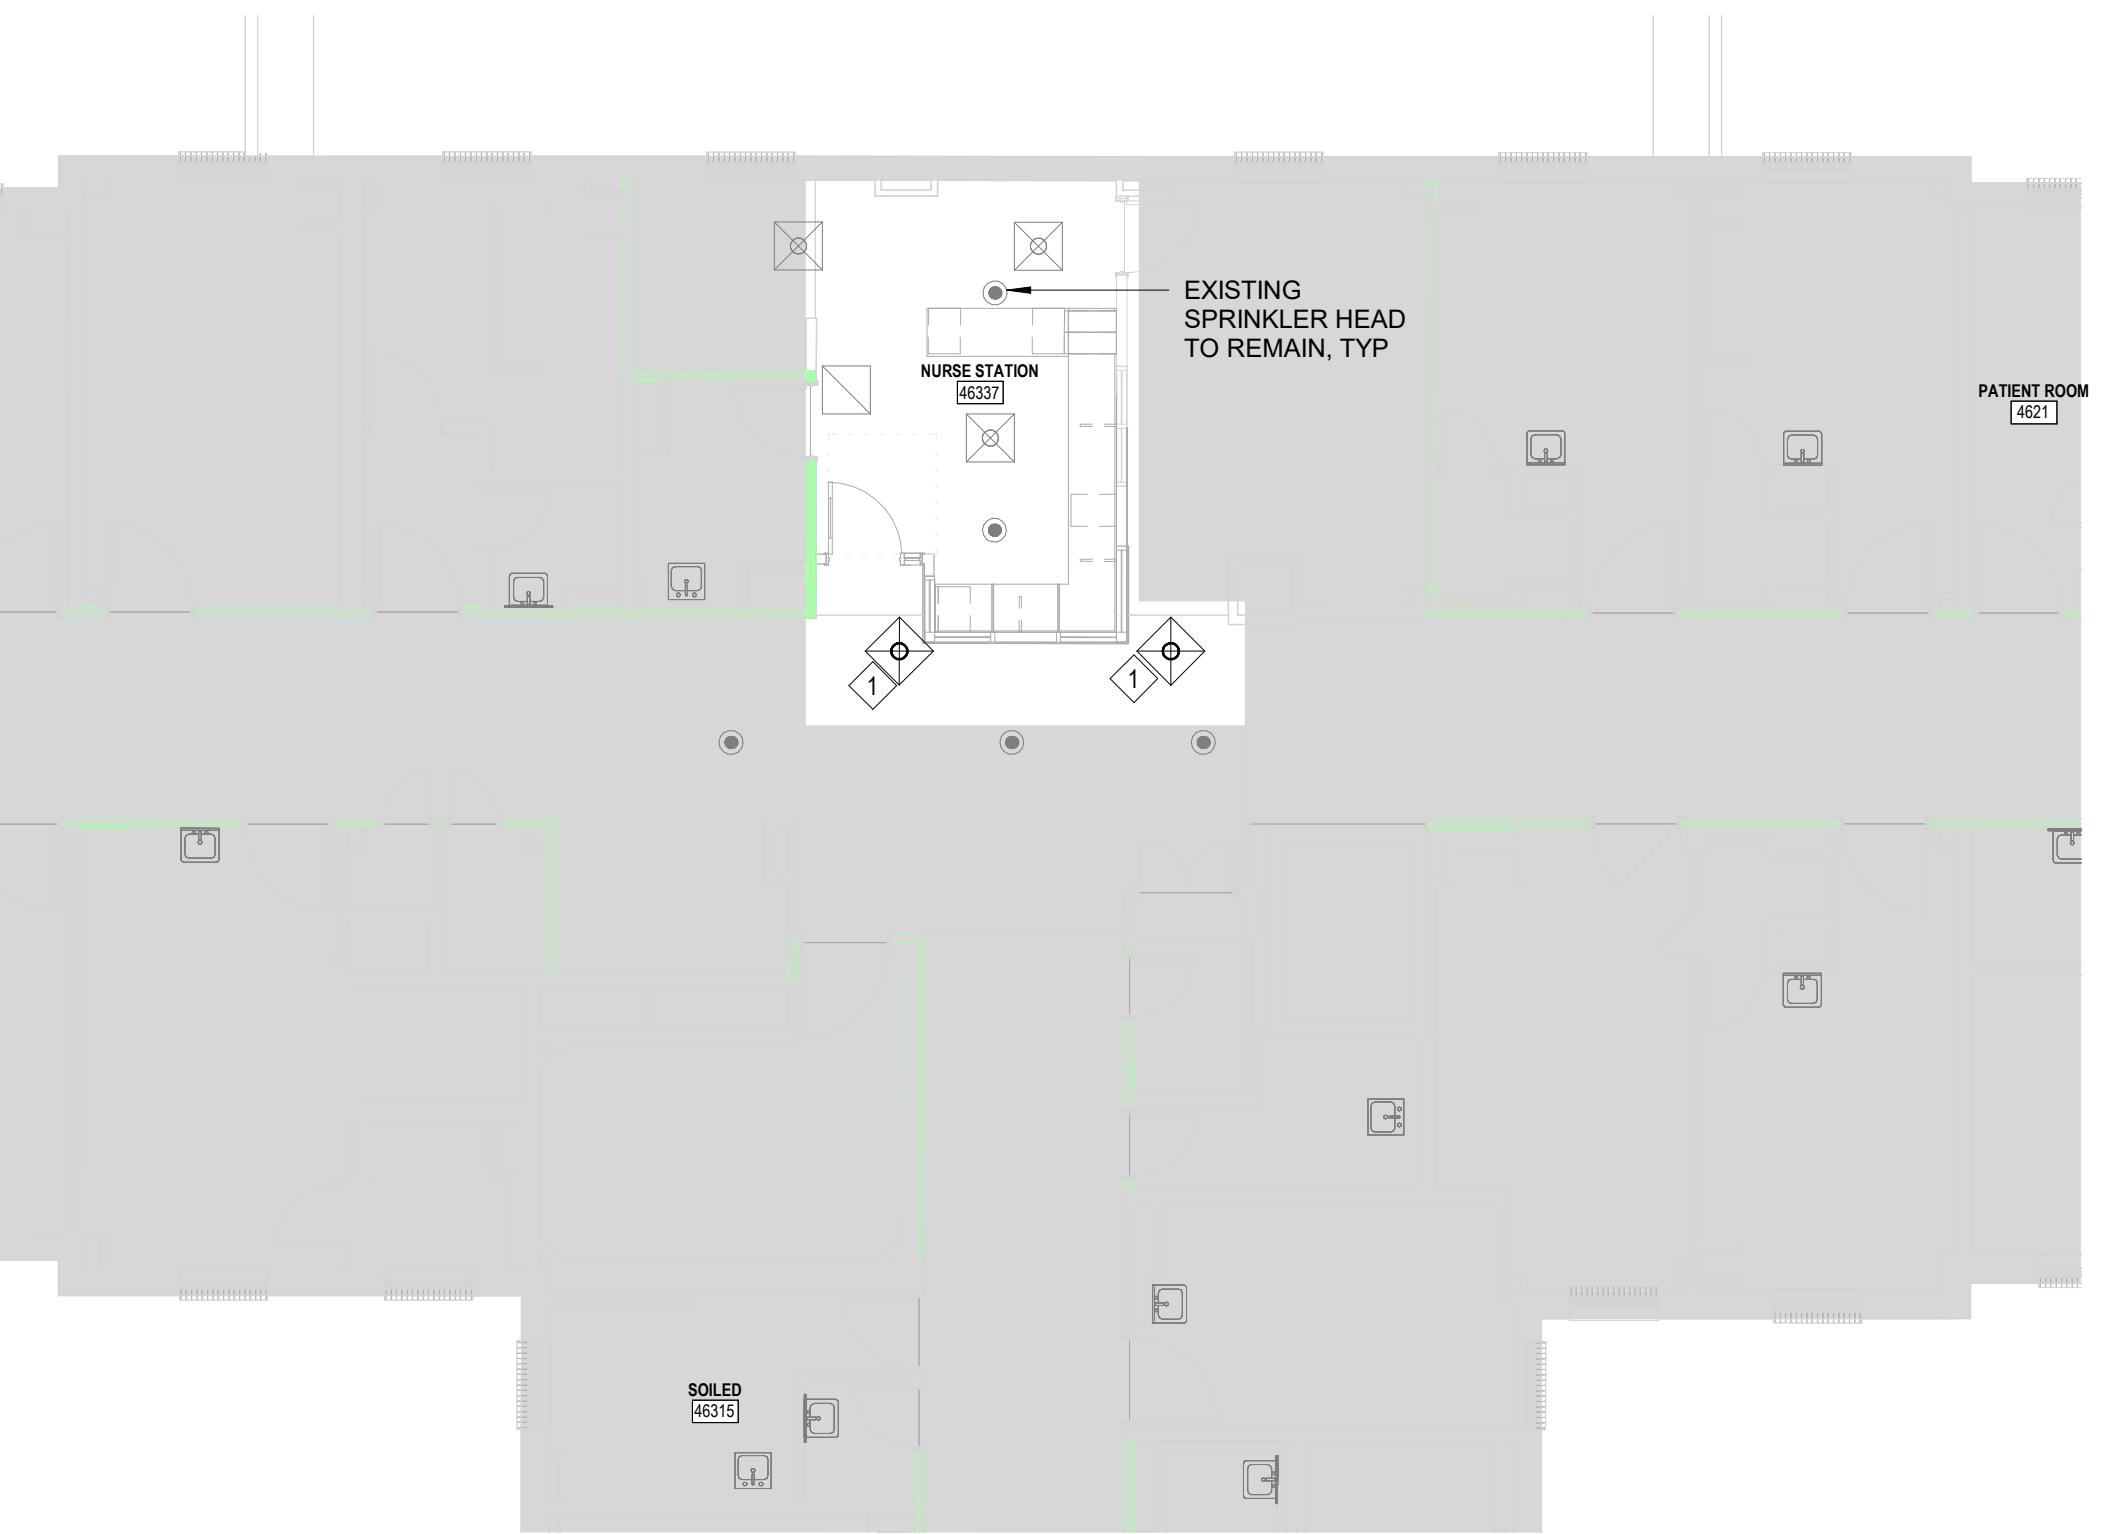

2 LEVEL 04 - AREA B - SENIOR BH - MECHANICAL - NEW WORK PLAN
SCALE: 1/8" = 1'-0"

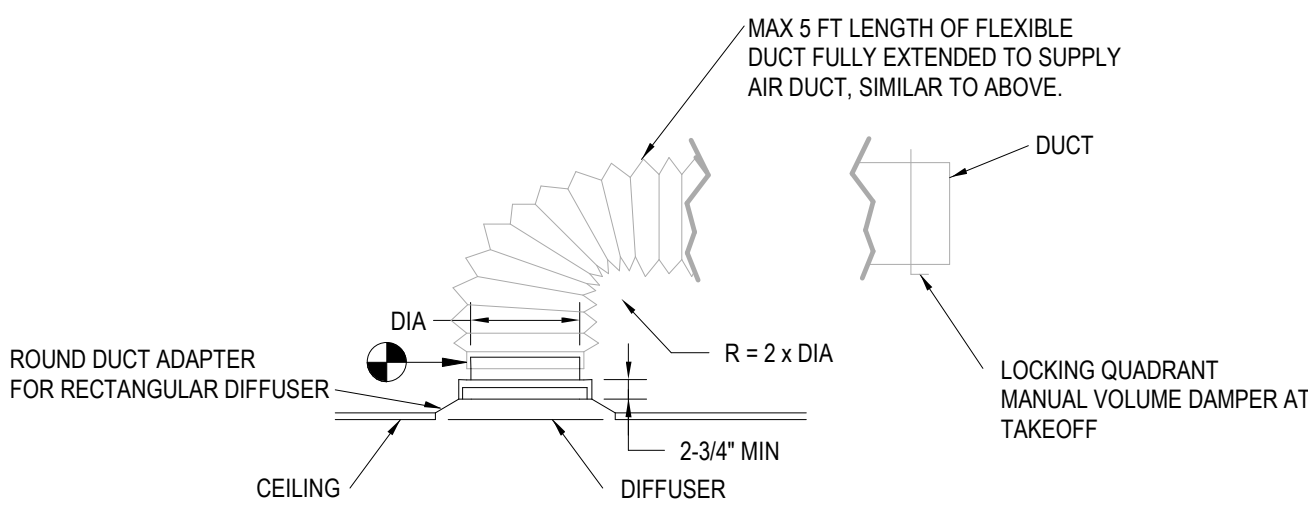

- NOTES:
- ALL RUNOUT DUCT SIZES SHALL MATCH AIR DISTRIBUTION NECK SIZE FOR A DISTANCE OF AT LEAST 5' UNLESS OTHERWISE NOTED
 - PROVIDE FLEX DUCT SADDLE WHERE NECESSARY TO MAINTAIN FLEX DUCT RADIUS SPECIFIED ABOVE
 - DIFFUSERS TO BE INDEPENDENTLY MOUNTED


3 DIFFUSER CONNECTION
SCALE: NOT TO SCALE

LIFE SAFETY LEGEND


RATING LEGEND

RGB 000-000-000	BUILDING SEPARATION
RGB 255-000-000	3 HR & 4 HR FIRE WALL SEPARATION (NCBC SECTION 706)
RGB 255-000-255	2 HR FIRE BARRIER (NCBC SECTION 707)
RGB 255-127-191	2 HR FIRE/SMOKE BARRIER (NCBC SECTION 407.5709)
RGB 111-063-127	1 HR FIRE BARRIER (NCBC SECTION 707)
RGB 000-000-255	1 HR FIRE/SMOKE BARRIER (NCBC SECTION 407.5709)
RGB 155-145-042	1 HR FIRE PARTITION (NCBC SECTION 708)
RGB 000-255-255	SMOKE PARTITION (NCBC SECTION 407.7710)
RGB 000-255-000	SUITE BOUNDARY (NCBC SECTION 407.4.4.2710)
RGB 255-127-000	


KEY PLAN

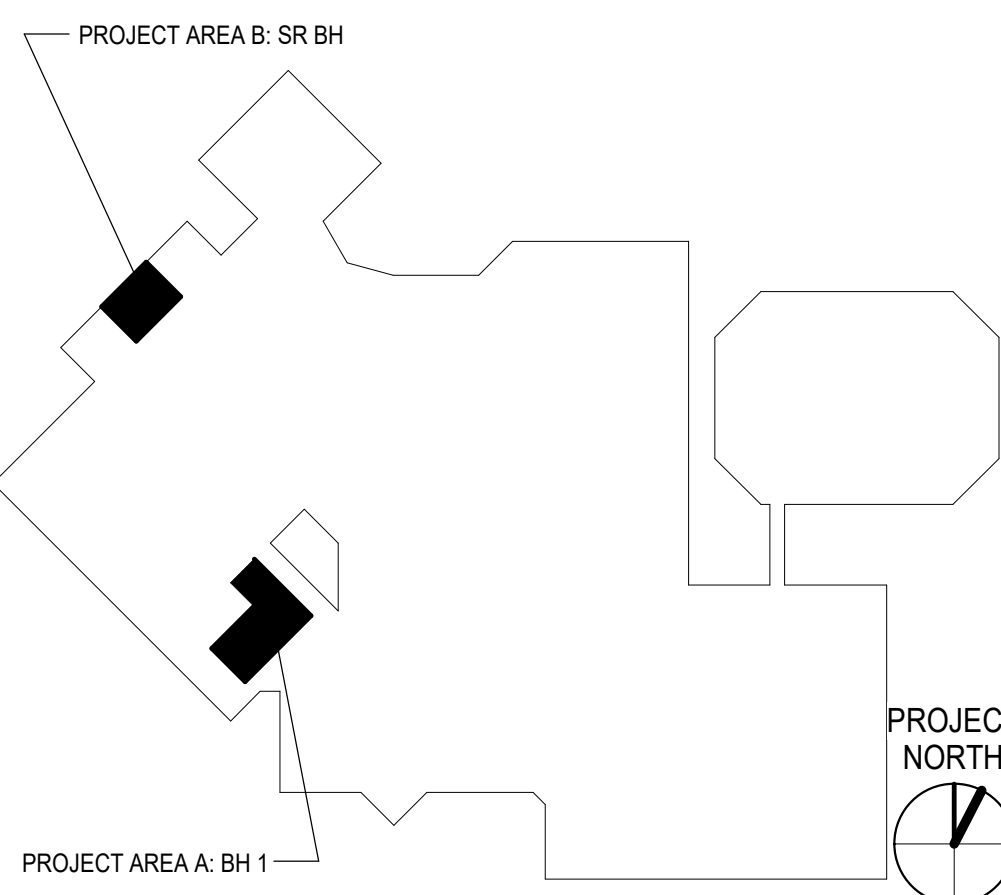

1/8" = 1'-0" 8' 4' 0' 8' 16'

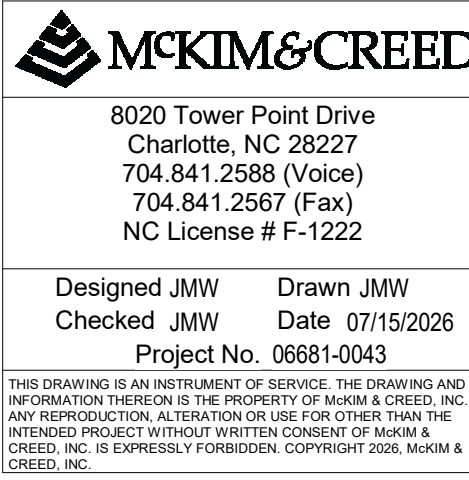

PROJECT & CONSTRUCTION MANAGEMENT
1400 East Morehead St.
Charlotte, NC 28204

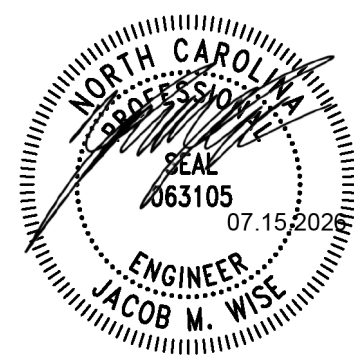

ATRIUM HEALTH
AH CABARRUS BH RENOVATION
AH Cabarrus Memorial Building
Atrium Health Facility #: 1232
920 Church Street North, Concord, NC 28025

ISSUE DATE: 07/15/2026
PHASE: Construction Documents
SHEET ISSUE:
NO. DATE DESCRIPTION

PRINCIPAL IN CHARGE: MS
PROJECT ARCHITECT: TAS
DRAWN BY: JMW

SHEET NAME:
MECHANICAL AND
PLUMBING - LEVEL 04
- DEMOLITION & NEW
WORK PLAN

PROJECT NUMBER:
JAZZID_14452
A/E PROJECT #:
02600404.00

MP102

GENERAL		
	DEMOLITION KEYED NOTE	
	NEW WORK KEYED NOTE	
	REVISION TAG	

LIGHTING CONTROLS		
WALL	CEILING	
		DUAL TECHNOLOGY OCCUPANCY SENSOR IN FLUSH (FINISHED SPACES) OR SURFACE (UNFINISHED SPACES) CEILING-MOUNTED OUTLET BOX. 'X' DENOTES CONTROL ZONE
		SINGLE-POLE SWITCH - 'X' DENOTES TYPE (MAY BE MULTIPLE): a,b,c... SWITCH / CONTROL ZONE / GROUP z1,z2,z3
3	THREE-WAY	MC MOTOR STARTER M MOTOR STARTER, MOTOR RATED
4	FOUR-WAY	OS DUAL TECH OCCUPANCY SENSOR OS2 DUAL TECH DUAL CIRCUIT OCCUPANCY SENSOR
D	DIMMER	OSD DUAL TECH OCCUPANCY SENSOR DIMMER
E	EMERGENCY (RED COLOR)	P PILOT LIGHT
F	FAN	T TIMER SWITCH WITH VISUAL AND AUDIBLE OFF WARNING
K	KEY OPERATED	VS DUAL TECH VACUANCY SWITCH
LV	LOW VOLTAGE	VS2 DUAL TECH DUAL CIRCUIT VACUANCY SENSOR
LVD	LOW VOLTAGE DIMMER	VSD DUAL TECH VACUANCY SWITCH DIMMER
LV2D	LOW VOLTAGE, 2 ZONES	WP WEATHER PROOF COVER
LV4D	LOW VOLTAGE, 4 ZONES	XP EXPLOSION PROOF

ALL DRAWINGS, SPECIFICATIONS AND NOTES HEREBY FURNISHED BY MCMILLAN PAZDAN SMITH ARCHITECTURE ARE THE PROPERTY OF MCMILLAN PAZDAN SMITH ARCHITECTURE. THESE MATERIALS ARE TO BE USED ONLY WITH RESPECT TO THE PROJECT FOR WHICH THEY WERE PREPARED AND NOT BE REPRODUCED OR TRANSMITTED IN ANY FORM OR BY ANY MEANS, ELECTRONIC OR MECHANICAL, INCLUDING PHOTOCOPYING, RECORDING, OR BY ANY INFORMATION STORAGE AND RETRIEVAL SYSTEM, WITHOUT PERMISSION IN WRITING FROM MCMILLAN PAZDAN SMITH ARCHITECTURE. ANY UNAUTHORIZED REPRODUCTION OR TRANSMISSION OF THESE MATERIALS IS STRICTLY PROHIBITED AND WILL BE PROSECUTED TO THE FULL EXTENT OF THE LAW.

LIGHTING FIXTURES		
		SURFACE, RECESSED, OR WALL MOUNTED LIGHTING FIXTURE. SEE LIGHTING FIXTURE KEY FOR TAG INFORMATION. SEE LIGHTING FIXTURE SCHEDULE FOR EXACT REQUIREMENTS.
		SURFACE, RECESSED, OR WALL MOUNTED LIGHTING FIXTURE CONNECTED TO EMERGENCY/LIFE SAFETY BRANCH CIRCUIT OR PROVIDE EMERGENCY DRIVER. SEE LIGHTING FIXTURE KEY FOR TAG INFORMATION. SEE LIGHTING FIXTURE SCHEDULE FOR EXACT REQUIREMENTS.
		SURFACE, RECESSED, OR WALL MOUNTED LIGHTING FIXTURE CONNECTED TO CRITICAL BRANCH CIRCUIT OR PROVIDE EMERGENCY DRIVER. SEE LIGHTING FIXTURE KEY FOR TAG INFORMATION. SEE LIGHTING FIXTURE SCHEDULE FOR EXACT REQUIREMENTS.
		SURFACE MOUNTED TRACK LIGHTING SYSTEM. LETTER INDICATES TYPE. SEE LIGHTING FIXTURE KEY FOR TAG INFORMATION. SEE LIGHTING FIXTURE SCHEDULE FOR EXACT TRACK AND FIXTURE REQUIREMENTS.
		CEILING MOUNTED EXIT SIGN, SHADED AREA INDICATES FACE WITH DIRECTIONAL ARROWS AS SHOWN. SEE LIGHTING FIXTURE SCHEDULE FOR EXACT REQUIREMENTS. CONNECT UNSWITCHED TO INDICATED BRANCH CIRCUIT.
		WALL MOUNTED EXIT SIGN, SHADED AREA INDICATES FACE WITH DIRECTIONAL ARROWS AS SHOWN. SEE LIGHTING FIXTURE SCHEDULE FOR EXACT REQUIREMENTS. CONNECT UNSWITCHED TO INDICATED BRANCH CIRCUIT.
		EMERGENCY BATTERY PACK UNIT WITH NUMBER OF LAMPS AS INDICATED WITH SELF DIAGNOSTICS. SEE LIGHTING FIXTURE SCHEDULE FOR EXACT REQUIREMENTS. CONNECT UNSWITCHED TO INDICATED BRANCH CIRCUIT.
LIGHTING FIXTURE KEY		
INDICATES PANEL NAME		
INDICATES FIXTURE TYPE SEE SCHEDULE FOR DESCRIPTION		
INDICATES CIRCUIT NUMBER		
INDICATES SWITCH CONTROL (a,b,c,...)		

DATA / COMMUNICATION - PATHWAYS & BOXES		
WALL	FLOOR	CEILING
DATA OUTLET - 4" SQUARE BOX WITH SINGLE GANG DEVICE BRACKET FLUSH (FINISHED SPACES) OR SURFACE (UNFINISHED SPACES). MINIMUM 1" CONDUIT TO ABOVE ACCESSIBLE CEILING WITH PULL STRING.		
VOICE OUTLET - 4" SQUARE BOX WITH SINGLE GANG DEVICE BRACKET FLUSH (FINISHED SPACES) OR SURFACE (UNFINISHED SPACES). MINIMUM 1" CONDUIT TO ABOVE ACCESSIBLE CEILING WITH PULL STRING.		
VOICE/DATA OUTLET - 4" SQUARE BOX WITH SINGLE GANG DEVICE BRACKET FLUSH (FINISHED SPACES) OR SURFACE (UNFINISHED SPACES). MINIMUM 1" CONDUIT TO ABOVE ACCESSIBLE CEILING WITH PULL STRING.		
DATA & VOICE DEVICE TAG KEY		
NUMBER OF VOICE PORTS		
NUMBER OF DATA PORTS		
WIRELESS ACCESS POINT - 4" SQUARE BOX WITH SINGLE GANG DEVICE BRACKET CEILING MOUNTED FLUSH (FINISHED SPACES) OR SURFACE (UNFINISHED SPACES) OUTLET BOX.		
TELEVISION CABLE OUTLET - 4" SQUARE BOX WITH SINGLE GANG DEVICE BRACKET FLUSH (FINISHED SPACES) OR SURFACE (UNFINISHED SPACES) OUTLET BOX. MINIMUM 1" CONDUIT TO ABOVE ACCESSIBLE CEILING WITH PULL STRING.		
WALL	FLOOR	CEILING
COMMUNICATION SYSTEM SPEAKER. SUBSCRIPT, WHEN SHOWN, INDICATES ZONE.		

ACCESS CONTROL - PATHWAY & BOXES	
	FLUSH MOUNTED ACCESS CONTROL CARD READER MOUNTED 48-INCHES ABOVE FINISHED FLOOR UNLESS OTHERWISE INDICATED.
	FLUSH MOUNTED ACCESS CONTROL CARD READER MOUNTED 48-INCHES ABOVE FINISHED FLOOR UNLESS OTHERWISE INDICATED.
	DOOR RELEASE BUTTON. SUBSCRIPT, WHEN SHOWN, INDICATES ZONE.
	INFRARED HAND SENSOR FOR HANDS FREE DOOR OPERATION. SUBSCRIPT, WHEN SHOWN, INDICATES ZONE.
	PUSH PANEL FOR HANDS FREE DOOR OPERATION. SUBSCRIPT, WHEN SHOWN, INDICATES ZONE.
	DOOR CONTACTS. SUBSCRIPT, WHEN SHOWN, INDICATES ZONE.

SECURITY - PATHWAY & BOXES	
	PANIC BUTTON
	VIDEO CAMERA
	VIDEO CAMERA IN DOME
VIDEO CAMERA NOMENCLATURE:	
FW	FIXED WALL MOUNTED VIDEO CAMERA
FC	FIXED CEILING MOUNTED
PTZ-C	PAN, TILT, ZOOM CEILING MTD
PTZ-W	PAN, TILT, ZOOM WALL MTD
PROVIDE POWER RACEWAYS, EMPTY 1" CONDUIT WITH PULL STRING AND BACK BOXES FOR SECURITY DEVICES AND EQUIPMENT AS REQUIRED.	

POWER EQUIPMENT	
	480/277 VOLT PANELBOARD, FLUSH AND SURFACE MOUNTED RESPECTIVELY. DESIGNATION AS INDICATED. REFER TO PANELBOARD SCHEDULES FOR EXACT REQUIREMENTS.
	208/120 OR 240/120 VOLT PANELBOARD, FLUSH AND SURFACE MOUNTED RESPECTIVELY. DESIGNATION AS INDICATED. REFER TO PANELBOARD SCHEDULES FOR EXACT REQUIREMENTS.
	208/120 OR 240/120 VOLT LOAD CENTER, FLUSH AND SURFACE MOUNTED RESPECTIVELY. DESIGNATION AS INDICATED. REFER TO PANELBOARD SCHEDULES FOR EXACT REQUIREMENTS.
	EXISTING PANELBOARD, FLUSH AND SURFACE MOUNTED RESPECTIVELY. DESIGNATION AS INDICATED. REFER TO PANELBOARD SCHEDULES FOR EXACT REQUIREMENTS.
	ELECTRICAL POWER POLE, MOUNTING AND CONFIGURATION AS SPECIFIED.
	ENCLOSED CIRCUIT BREAKER. FRAME SIZE AND TRIP RATING AS INDICATED ON PLANS.
	NON-FUSED DISCONNECT. FRAME SIZE AS INDICATED ON PLANS.
	FUSED DISCONNECT. FRAME SIZE AND TRIP RATING AS INDICATED ON PLANS. PROVIDE FUSES PER NAMEPLATE OF EQUIPMENT SERVED UNLESS OTHERWISE INDICATED.
	SPECIAL EQUIPMENT CONNECTION. SEE KEYED NOTE OR EQUIPMENT CONNECTION SCHEDULE FOR EXACT REQUIREMENTS.
DISCONNECT SWITCH TAG KEY	
SIZE	
NO. OF POLES	
NEMA TYPE	
FUSE SIZE OR NF	
	TRANSFORMER - SEE RISER DIAGRAM

POWER DEVICES		
WALL	FLOOR	CEILING
DUPLEX RECEPTACLE		
SPLIT-WIRED DUPLEX RECEPTACLE		
EMERGENCY DUPLEX RECEPTACLE		
QUAD RECEPTACLE		
EMERGENCY QUAD RECEPTACLE		
GFI DUPLEX RECEPTACLE		
EMERGENCY GFI DUPLEX RECEPTACLE		
GFI QUAD RECEPTACLE		
EMERGENCY GFI QUAD RECEPTACLE		
SPECIAL EQUIPMENT RECEPTACLE. SUBSCRIPT INDICATES NEMA CONFIGURATION, IF APPLICABLE.		
EMERGENCY SPECIAL EQUIPMENT RECEPTACLE. SUBSCRIPT INDICATES NEMA CONFIGURATION, IF APPLICABLE.		
JUNCTION BOX FLUSH (FINISHED SPACES) OR SURFACE (UNFINISHED SPACES) OUTLET BOX. COORDINATE LOCATION WITH MANUFACTURER FOR EQUIPMENT MOUNTED BOXES.		
POWER DEVICE NOMENCLATURE		
+	ABOVE COUNTER	TR TAMPER RESISTANT
##H	CUSTOM MOUNTING HEIGHT	USB DUPLEX WITH USB-A & USB-C PORTS
EW	ELECTRIC WATER COOLER	WP WEATHER PROOF
IG	ISOLATED GROUND	XP EXPLOSION PROOF
HG	HOSPITAL GRADE	C CONTROLLED
POWER DEVICE TAG KEY		
INDICATES PANEL NAME		
DEVICE SYMBOL		
XX-XX		
INDICATES CIRCUIT NUMBER		
ELECTRIC PUSH BUTTON - FLUSH (FINISHED SPACES) OR SURFACE (UNFINISHED SPACES) OUTLET BOX. MOUNT 48-INCHES ABOVE FINISHED FLOOR UNLESS OTHERWISE INDICATED OR REQUIRED BY SITE CONDITIONS.		
EMERGENCY STOP MUSHROOM TYPE BUTTON IN SURFACE MOUNTED BOX. MOUNT 48-INCHES ABOVE FINISHED FLOOR UNLESS OTHERWISE INDICATED OR REQUIRED BY SITE CONDITIONS.		

NURSE CALL SYMBOLS	
WALL	CEILING
CALL DOME LIGHT	
CALL ZONE LIGHT	
EMERGENCY CALL STATION	
NURSE CALL STATION	
PANIC CODE BLUE PUSHBUTTON STATION	
DUTY STATION	
STAFF ASSIST	

- ALL ELECTRICAL WORK SHALL BE IN ACCORDANCE WITH ALL APPLICABLE ORDINANCES, CODES, AND REGULATIONS OF ALL AUTHORITIES HAVING JURISDICTION. ALL ELECTRICAL WORK SHALL BE INSPECTED AND APPROVED BY THE LOCAL ELECTRICAL INSPECTION AGENCY. THE ELECTRICAL CONTRACTOR SHALL PROVIDE ALL NECESSARY FEES AND PERMITS, INCLUDING THE CERTIFICATE OF ELECTRICAL INSPECTION.
- THE ELECTRICAL CONTRACTOR SHALL BE RESPONSIBLE FOR CONSTRUCTION SAFETY, ARCHITECT AND/OR ENGINEER SHALL ASSUME NO RESPONSIBILITY FOR WORKMAN'S OR PEDESTRIAN'S SAFETY. NOTHING IN THE CONTRACT DOCUMENTS SHALL BE CONSTRUED TO INSTRUCT PROCEDURES OR COMPONENTS FOR PROJECT SAFETY.
- WHERE A CONFLICT ARISES BETWEEN PLANS, SPECIFICATIONS, DETAILS, SCHEDULES, APPLICABLE CODES OR REGULATIONS, THE MOST STRINGENT SHALL APPLY.
- NOTHING CONTAINED IN THE CONTRACT DOCUMENTS SHALL BE CONSTRUED TO CONFLICT WITH ANY NATIONAL, STATE, MUNICIPAL, OR LOCAL LAWS OR REGULATIONS GOVERNING THE WORK INDICATED OR SPECIFIED. THE ELECTRICAL CONTRACTOR, AT NO ADDITIONAL EXPENSE TO THE OWNER, SHALL SATISFY ALL SUCH REQUIREMENTS.
- THE CONTRACT DOCUMENTS ARE COMPRISED OF DRAWINGS AND SPECIFICATIONS. EACH ELECTRICAL BIDDER SHALL VISIT THE SITE TO DETERMINE EXISTING CONDITIONS PRIOR TO SUBMITTING BID PROPOSAL. BIDS SHALL BE BASED ON THE COMPLETE EXAMINATION OF THE DRAWINGS, SPECIFICATIONS, AND EXISTING CONDITIONS. NO CONSIDERATION SHALL BE GIVEN TO ANY CONTRACTOR WHO FAILS TO DO SO.
- THE WORK UNDER THIS CONTRACT SHALL INCLUDE THE FURNISHING OF ALL NECESSARY MATERIALS, TOOLS, AND LABOR FOR A COMPLETE AND WORKING INSTALLATION AS DEFINED BY THE PLANS AND SPECIFICATIONS. THE ELECTRICAL CONTRACTOR SHALL WARRANT THE WORK INDICATED AND SPECIFIED FOR A PERIOD OF ONE (1) YEAR. THE WORK SHALL FUNCTION AS INTENDED, BE COMPLETE IN ALL DETAILS, AND SHALL INCLUDE ALL INDICATED, SPECIFIED, OR REQUIRED ACCESSORIES FOR A FUNCTIONING SYSTEM.
- THE ELECTRICAL CONTRACTOR SHALL PROVIDE TEMPORARY LIGHT AND POWER AS REQUIRED BY THE GENERAL CONDITIONS OF THE SPECIFICATIONS.
- THE ELECTRICAL CONTRACTOR SHALL COORDINATE THEIR WORK WITH ALL OTHER TRADES. ALL DEVICES PROVIDED BY OTHERS THAT REQUIRE LINE VOLTAGE ELECTRICAL POWER SHALL BE CONNECTED BY THE ELECTRICAL CONTRACTOR. POWER, PHONE, DATA, TV, AND SIMILAR DEVICE OUTLET LOCATIONS SHALL BE COORDINATED WITH THE ARCHITECTURAL INTERIOR LAYOUTS. THE GENERAL CONTRACTOR, AND THE OWNER.
- THE ELECTRICAL CONTRACTOR SHALL COORDINATE WITH THE OWNER'S PROJECT MANAGER PRIOR TO AND FOR SCHEDULING ANY INTERRUPTION OF BUILDING UTILITIES.
- THE ELECTRICAL CONTRACTOR SHALL COORDINATE WITH THE LOCAL UTILITIES AND ARRANGE FOR THE FOLLOWING SERVICES: ELECTRICAL POWER, CABLE TV, AND TELEPHONE SERVICE. THE ELECTRICAL CONTRACTOR SHALL MEET WITH THE REPRESENTATIVES OF THE ELECTRICAL UTILITY & TELECOMM UTILITY TO CONFIRM DETAILS ON THE SERVICE AND METERING. THE ELECTRICAL CONTRACTOR SHALL PAY ALL NECESSARY COSTS, FEES, AND PERMITS INVOLVED IN ESTABLISHING SERVICE AT THE BUILDING.

- IT SHALL BE THE RESPONSIBILITY OF THE ELECTRICAL CONTRACTOR TO DISCONNECT AND REMOVE ALL ITEMS OF THE ELECTRICAL EQUIPMENT (E.G. LIGHTING FIXTURES, WIRING DEVICES, WIRE, CONDUIT, ETC.) IN THE AREAS AFFECTED BY RENOVATION, WHICH ARE NO LONGER A FUNCTIONING PART OF THE ELECTRICAL SYSTEM OR ANY AUXILIARY SYSTEM. ONLY THOSE ITEMS WHICH ARE ESSENTIAL FOR MAINTAINING CONTINUITY OF SERVICES OUTSIDE THE AFFECTED AREAS SHALL REMAIN.
- WHERE PRESENT EQUIPMENT IS NOTED TO REMAIN OR LABELED "PR", IT IS TO REMAIN IN THE PRESENT LOCATION, BUT MAKE ALL REQUIRED ADJUSTMENTS TO PROVIDE FOR ALL NEW WIRING EXTENSIONS FROM SUCH OUTLETS OR EQUIPMENT AS REQUIRED.
- ALL EXPOSED RACEWAYS, DEVICES, PANELBOARDS, AND OTHER ELECTRICAL EQUIPMENT THAT ARE NO LONGER A FUNCTIONING PART OF THE ELECTRICAL SYSTEM OR ANY AUXILIARY ELECTRICAL SYSTEM, SHALL BE DE-ENERGIZED, DISCONNECTED, AND REMOVED. GENERALLY, THESE REMOVALS ARE NOT SPECIFICALLY INDICATED ON THE DRAWINGS. THIS CONTRACTOR SHALL PATCH ALL CEILING, WALL, OR FLOOR OPENINGS LEFT BY THIS REMOVAL.
- IF THE CONTINUITY OF ANY EXISTING CIRCUITS THAT ARE TO REMAIN IS INTERRUPTED BY THESE ALTERATIONS, EVEN THOUGH IT MAY NOT BE INDICATED, THE CONTRACTOR SHALL RESTORE SUCH CIRCUITS, PROVIDING ALL NECESSARY MATERIALS AND LABOR TO ACCOMPLISH THIS.
- ITEMS INDICATED ON THE DRAWINGS THAT ARE TO BE RELOCATED SHALL BE REMOVED, CLEANED, AND STORED PRIOR TO RE-USE. ALL ITEMS INDICATED TO BE REMOVED & RELOCATED SHALL BE REWIRING AS NECESSARY TO ACCOMPLISH THE INTENDED FUNCTION.
- EXISTING DEVICES AND OTHER ELECTRICAL EQUIPMENT NOT SHOWN OR NOT INDICATED TO BE REMOVED OR REPLACED SHALL REMAIN IF SUCH DEVICES OR EQUIPMENT ARE NECESSARY FOR PROPER FUNCTIONING OF THE ELECTRICAL SYSTEM. IF REQUIRED, EXISTING WIRING SHALL BE MODIFIED OR REPLACED TO SUIT THE NEW LAYOUT.
- ALL REMOVED ELECTRICAL EQUIPMENT REQUESTED BY THE OWNER SHALL BE TURNED OVER TO THE OWNER AND STORED WHERE DIRECTED. IN THE CONDITION AS FOUND. ALL OTHER REMOVED EQUIPMENT AND MATERIAL SHALL BECOME THE PROPERTY OF THIS CONTRACTOR AND SHALL BE REMOVED FROM THE PREMISES BY CONTRACTOR.
- FOR THE DURATION OF THE CONTRACT, THIS CONTRACTOR SHALL MAKE EVERY EFFORT TO KEEP ELECTRICAL OUTAGES TO A MINIMUM. IN ORDER TO INTERRUPT CONTINUITY OF ELECTRICAL SERVICE TO ANY PART OF THE BUILDING, IT SHALL BE NECESSARY FOR THIS CONTRACTOR TO REQUEST PERMISSION FOR SUCH OUTAGES BY LETTER. THE LETTER SHALL STATE THE DATE OF PROPOSED OUTAGE, TIME IT SHALL START, TOTAL OUTAGE TIME REQUIRED, AND REASON FOR THE OUTAGE. THE REQUEST SHALL BE SUBMITTED A MINIMUM OF 21 DAYS BEFORE THE PROPOSED OUTAGE.
- ALL ITEMS AND DEVICES SHOWN WITH DASHED LINES ARE INTENDED TO BE DISCONNECTED & REMOVED.
- ALL ITEMS SHOWN WITH SOLID LINES ARE INTENDED TO REMAIN. E.C. SHALL MAKE ANY ADJUSTMENTS NECESSARY TO MAINTAIN ITEMS & DEVICES, INCLUDING EXISTING WIRING.
- INFORMATION ON THIS DRAWING WAS OBTAINED FROM FIELD OBSERVATION AND EXISTING DRAWINGS, AND MUST BE FIELD VERIFIED BY E.C.

ELECTRICAL SHEET INDEX	
E001	ELECTRICAL SYMBOLS, LEGENDS AND ABBREVIATIONS
E002	ELECTRICAL SPECIFICATIONS
E100	ELECTRICAL - LEVEL 01 - OVERALL PLANS
E200	ELECTRICAL - LEVEL 01 - LIGHTING - DEMOLITION
E201	ELECTRICAL - LEVEL 01 - POWER AND SPECIAL SYSTEMS - DEMOLITION
E202	ELECTRICAL - LEVEL 04 - LIGHTING - DEMOLITION
E203	ELECTRICAL - LEVEL 04 - POWER AND SPECIAL SYSTEMS - DEMOLITION
E300	ELECTRICAL - LEVEL 01 - LIGHTING - NEW WORK
E301	ELECTRICAL - LEVEL 01 - POWER AND SPECIAL SYSTEMS - NEW WORK
E302	ELECTRICAL - LEVEL 04 - LIGHTING - NEW WORK
E303	ELECTRICAL - LEVEL 04 - POWER AND SPECIAL SYSTEMS - NEW WORK
E601	ELECTRICAL - PARTIAL RISER DIAGRAM AND PANEL SCHEDULES
E701	ELECTRICAL DETAILS

8020 Tower Point Drive
Charlotte, NC 28227
704.841.2588 (Voice)
704.841.2587 (Fax)
NC License # F-1222

Designed JGR
Checked TPB
Drawn JGR
Date 07/15/2026
Project No. 06681-0043

THIS DRAWING IS AN INSTRUMENT OF SERVICE. THE DRAWING AND INFORMATION THEREON IS THE PROPERTY OF MCKIM & CREED, INC. AND IS NOT TO BE REPRODUCED, COPIED, OR TRANSMITTED IN ANY FORM OR BY ANY MEANS, ELECTRONIC OR MECHANICAL, INCLUDING PHOTOCOPYING, RECORDING, OR BY ANY INFORMATION STORAGE AND RETRIEVAL SYSTEM, WITHOUT PERMISSION IN WRITING FROM MCKIM & CREED, INC. IT IS EXPRESSLY FORBIDDEN. COPYRIGHT 2026, MCKIM & CREED, INC.



Atrium Health
PROJECT & CONSTRUCTION MANAGEMENT
1400 East Morehead St.
Charlotte, NC 28204



MCKIM & CREED
ENGINEERS SURVEYORS PLANNERS



ATRIUM HEALTH

AH CABARRUS BH RENOVATION

AH Cabarrus Memorial Building
Atrium Health Facility #: 1232
920 Church Street North, Concord, NC 28025

ISSUE DATE:	07/15/2026	
PHASE:	Construction Documents	
SHEET ISSUE:		
NO.	DATE	DESCRIPTION

PRINCIPAL IN CHARGE: MS
PROJECT ARCHITECT: TAS
DRAWN BY: JGR

SHEET NAME:
**ELECTRICAL
SYMBOLS, LEGENDS
AND ABBREVIATIONS**

SHEET NO. PROJECT NUMBER:
JAZZID_14452
A/E PROJECT #: 02600404.00

E001

SECTION 26 05 01-BASIC ELECTRICAL REQUIREMENTS	
PART 1	GENERAL
1.1	REQUIREMENTS
A.	GENERAL CONDITIONS OF THE CONTRACT, SUPPLEMENTARY GENERAL CONDITIONS, AND INSTRUCTIONS TO BIDDERS SECTIONS CONTAINED IN THE CONTRACT DOCUMENTS ARE A PART OF THESE SPECIFICATIONS.
1.2	EXTENT OF THE WORK
A.	THIS CONTRACTOR SHALL FURNISH ALL LABOR, MATERIALS, AND EQUIPMENT, AND PERFORM ALL OPERATIONS NECESSARY FOR INSTALLATION OF COMPLETE ELECTRICAL WORK WITHIN THE INTENT OF, AND AS INDICATED ON, THE DRAWINGS AND AS HEREIN SPECIFIED. PRIOR TO SUBMITTING A BID, THE CONTRACTOR SHALL MAKE A VISIT TO THE SITE TO BECOME THOROUGHLY FAMILIAR WITH ALL ELEMENTS OF THE REQUIRED WORK.
1.3	REGULATIONS AND COMPLIANCE
A.	LATEST APPROVED EDITIONS OF THE NATIONAL ELECTRICAL CODE AND THE NORTH CAROLINA STATE BUILDING CODE GOVERN THIS WORK. ALL THEIR REQUIREMENTS SHALL BE SATISFIED, ALSO THE REQUIREMENTS OF THE NORTH CAROLINA DIVISION OF HEALTH SERVICE REGULATION.
B.	THIS CONTRACTOR SHALL SECURE AND PAY FOR ALL PERMITS, FEES, INSPECTIONS, AND LICENSES REQUIRED. UPON COMPLETION OF THE JOB THEY SHALL PRESENT TO THE ENGINEER A CERTIFICATE OF INSPECTION AND APPROVAL FROM THE INSPECTION AUTHORITIES.
D	PRODUCTS
2.1	MATERIALS

A.	ALL MATERIALS SHALL BE NEW, WITH REQUIRED UNDERWRITERS LABORATORIES (OR THIRD PARTY LISTED) LABEL, AND WITH MANUFACTURERS LABEL OR NAMEPLATE GIVING COMPLETED ELECTRICAL DATA.
B.	WHERE A MANUFACTURERS CATALOG NUMBER IS USED, ALL PARTS SHALL BE FURNISHED TO MAKE IT COMPLETE AND TO FIT THE CONSTRUCTION INTENDED.
C.	WITHIN TEN DAYS AFTER AWARD, CONTRACTOR SHALL SUBMIT TO ENGINEER A COMPLETE LIST IN TRIPlicate OF ALL MATERIALS THEY PROPOSE TO USE. LIST SHALL SHOW A SINGLE MANUFACTURER WITH NOT ONLY MAJOR MATERIALS AND EQUIPMENT, BUT ALSO SUCH ITEMS AS, BUT NOT LIMITED TO, CONDUIT FITTINGS, RACEWAY SUPPORTS, CONDUCTIVE PASTE, TIGHT COMPOUND, ASPHALTUM, SEALING MATERIAL, CLAMPS, ANCHORS, OUTLET BOXES, GUTTERS, TERMINAL CABINETS, WIRE-PULLING COMPOUND, SPlice CONNECTORS, TAPE, WIRE MARKERS, LAMPS, ETC.
D.	MATERIAL SHALL BE THE MAKE AND NUMBER GIVEN IN THESE SPECIFICATIONS OR SHOWN ON DRAWINGS, OR EQUIVALENT WHERE SPECIFICALLY STATED AS BEING ALLOWED. EQUIVALENT ITEMS OR MATERIALS WILL BE SUBJECT TO ACCEPTANCE BY THE ENGINEER AT SUBMITTAL STAGE. IF CONTRACTOR WISHES TO FURNISH A SUBSTITUTE FOR THE ITEM(S) SPECIFIED (OR EQUIVALENT WHERE ALLOWED), THEY SHALL FURNISH COMPLETE, DETAILED DATA AND OBTAIN APPROVAL OF THE SUBSTITUTION IN WRITING FROM THE ENGINEER NO LATER THAN 10 DAYS PRIOR TO BID. IN SOME CASES, AT THE REQUEST OF THE ENGINEER, SAMPLES OF THE SUBSTITUTE ITEMS SHALL BE SUBMITTED FOR REVIEW, DATA (AND SAMPLE IF REQUIRED) SHALL BE SUBMITTED IN A TIMELY MANNER SUCH THAT APPROVAL BY ENGINEER CAN BE RETURNED TO CONTRACTOR NO LATER THAN 10 DAYS PRIOR TO BID DATE. DATA OR SAMPLE NOT SUBMITTED IN SUFFICIENT TIME TO ALLOW EVALUATION BY ENGINEER WILL BE AUTOMATICALLY REJECTED.
E.	ENGINEERS REVIEW OF SAMPLES, CUT SHEETS, SHOP DRAWINGS, AND OTHER MATTER SUBMITTED BY THE CONTRACTOR SHALL NOT RELIEVE THE CONTRACTOR OF RESPONSIBILITY FOR FULL COMPLIANCE WITH THE DRAWINGS AND SPECIFICATIONS. IF A SUBMITTED ITEM DOES NOT COMPLY IN ANY WAY (COLOR, STYLE, QUALITY, FUNCTION, OR PERFORMANCE), CONTRACTOR SHALL CALL THE SPECIFIC NON-COMPLIANCE TO THE ATTENTION OF THE ENGINEER IN WRITING IN A COVER LETTER TO THE SUBMITTALS REQUESTING A DEVIATION FROM SPECIFICATIONS. THIS DOES NOT IMPLY THAT APPROVAL OF REQUESTED DEVIATION WILL BE GIVEN, ONLY THAT IT WILL BE REVIEWED. ENGINEERS REVIEW OF SUBMITTALS IS NOT INTENDED TO CONFIRM QUANTITY COUNTS OF MATERIALS AND EQUIPMENT MADE BY CONTRACTOR. CONTRACTOR IS REQUIRED TO PROVIDE QUANTITIES OF ITEMS AS NECESSARY FOR SYSTEMS TO FUNCTION AS DESCRIBED AND SHOWN ON THE PLANS AND IN THESE SPECIFICATIONS.
G.	SPECIALLY SYSTEMS SUCH AS FIRE ALARM SYSTEMS, SECURITY SYSTEMS, ETC., THAT ARE INCLUDED AS PART OF THE ELECTRICAL CONTRACT SHALL BE FURNISHED AND INSTALLED BY AN AUTHORIZED REPRESENTATIVE OF THE MANUFACTURER OF THE EQUIPMENT SUPPLIED. THIS INCLUDES USE OF FACTORY TRAINED AND AUTHORIZED INSTALLERS WHERE REQUIRED TO FULFILL MANUFACTURERS WARRANTY PROVISIONS.
H.	SUBMIT CUT SHEETS, SHOP DRAWINGS, AND OTHER DESCRIPTIVE MATERIALS REQUESTED, IN SIX (6) COPIES, OR AS REQUIRED BY THE SUPPLEMENTARY GENERAL CONDITIONS SECTION. CONTRACTOR SHALL SUBMIT SHOP DRAWINGS AND/OR MANUFACTURERS DATA TO THE ENGINEER PRIOR TO BEGINNING WORK. SUBMITTALS WILL NOT BE ACCEPTED FOR REVIEW OR APPROVAL BY THE ENGINEER UNLESS THE ELECTRICAL CONTRACTORS STAMP SIGNIFYING HIS REVIEW AND APPROVAL IS EVIDENT ON THE SUBMITTALS. SUBMITTALS SHALL CONTAIN THE FOLLOWING INFORMATION: LIGHT FIXTURES, SWITCHES, RECEPTACLES, COVER PLATES, CONDUCTORS, CABLE, TERMINAL CABINETS, MOTOR CONNECTIONS, FITTINGS, TIGHTENING TOOLS, AND PANELBOARDS.
I.	FIRESTOP MATERIAL SHALL BE MANUFACTURED BY STI (SPECIFIED TECHNIQUES, INC.).
J.	PLYWOOD IS NOT PERMITTED AS BLOCKING FOR MOUNTING OF ELECTRICAL EQUIPMENT.
K.	MATERIALS SHOULD BE INSPECTED UPON THEIR ARRIVAL AT THE SITE TO BE SURE THEY ARE CORRECT, NO EXTENSION OF TIME FOR COMPLETION WILL BE ALLOWED BECAUSE MATERIALS RECEIVED ARE WRONG. COMPLETELY ADEQUATE HOUSING SHALL BE PROVIDED ON THE SITE FOR ORDERLY AND CAREFUL STORAGE OF ALL MATERIALS AND EQUIPMENT. NOTHING SHALL BE STORED OUTSIDE EXCEPT CONDUIT, WHICH MAY BE STORED IN RACKS SO IT IS AT LEAST 12 INCHES ABOVE GROUND AND NOT SUBJECT TO MUD BEING SPATTERED ON IT.

C	PAINTING
A.	SUITABLE FINISH COATINGS SHALL BE PROVIDED UNDER THIS SECTION OF THE SPECIFICATIONS ON ALL ITEMS OF ELECTRICAL EQUIPMENT AND WIRING WHICH ARE EXPOSED. THIS SHALL CONSIST OF EITHER AN APPROVED FACTORY APPLIED FINISH OR AN ACCEPTABLE FINISH APPLIED DURING OR AFTER INSTALLATION. EQUIPMENT WHICH IS FURNISHED IN FINISHES SUCH AS STAINLESS STEEL OR SATIN ALUMINUM ARE NOT TO BE PAINTED. EXPOSED EQUIPMENT AND/OR WIRING IN FINISHED AREAS SUCH AS PANEL COVERS OR SURFACE RACEWAY SHALL BE SUPPLIED WITH FACTORY APPLIED PRIME COAT AND SHALL BE PROFESSIONALLY PAINTED OR ENAMELED AS DIRECTED TO RESULT IN A COMPLETELY COATED AND ATTRACTIVELY FINISHED MANOR. ALL SUCH FINISHING SHALL BE AS DIRECTED BY AND SHALL BE SATISFACTORY TO THE ENGINEER.

PART 3	EXECUTION
3.1	GENERAL INSTALLATION
A.	THE ELECTRICAL DRAWINGS ARE DIAGRAMMATIC ONLY, AND ARE INTENDED TO EXPLAIN SYSTEM FUNCTION AND DEFINE QUALITY OF MATERIALS AND INSTALLATION. THEY ARE NOT INTENDED TO DEFINE CONSTRUCTION METHODS.
B.	THE CONTRACTOR SHALL KEEP THE SITE, AT ALL TIMES, ONE SET OF ELECTRICAL DRAWINGS AND SPECIFICATIONS, AND ONE SET OF DRAWINGS AND SPECIFICATIONS ON THE WORK OF OTHER TRADES. IN ADDITION, ONE COMPLETE SET OF ALL ELECTRICAL SUBMITTALS AND SHOP DRAWINGS SHALL BE MAINTAINED AT THE SITE BY THE ELECTRICAL CONTRACTOR.
C.	THE CONTRACTOR SHALL CHECK OTHER TRADES' DRAWINGS, SPECIFICATIONS, AND SHOP DRAWINGS AS WELL AS EXISTING CONDITIONS TO SEE IF THERE ARE ANY CONFLICTS OR DISCREPANCIES. IF SO, THEY SHALL CONTACT THE ENGINEER FOR INSTRUCTIONS.
D.	IF THE CONTRACTOR SHALL PROPERLY PROTECT THEIR WORK AGAINST DAMAGE BY WEATHER OR OTHER TRADES. ALL WORK SHALL BE LEFT WELL CLEANED, AND DAMAGED FINISHES SHALL BE RESTORED TO ORIGINAL CONDITION.
E.	THE CONTRACTOR SHALL PLACE THEIR OWN SLEEVES AND NOTIFY OTHER TRADES OF CHASES AND OPENINGS FAR ENOUGH AHEAD SO THEY CAN BE PROPERLY BUILT IN, WHERE ANY RACEWAYS, SUPPORTS, ETC., INSTALLED UNDER THE CONTRACT PENETRATE THE ROOF.
F.	SUITABLE PITCH POCKETS SHALL BE PROVIDED AND COORDINATED WITH THE ROOFING CONTRACTOR AS NECESSARY TO BE ACCEPTABLE TO THE ENGINEER. PROVIDE SUITABLE FITTINGS WHERE ANY RACEWAYS OR EQUIPMENT CROSS EXPANSION JOINTS.
G.	THE CONTRACTOR SHALL BE RESPONSIBLE FOR ALL TRENCHING, BACKFILLING, CUTTING, CORE DRILLING, AND PATCHING RELATED TO THEIR WORK.
H.	WHEN CUTTING AND PATCHING IS REQUIRED, THE CONTRACTOR IS NOT ALLOWED TO USE IMPACT TOOLS. ROTATING DEVICES MUST BE USED.
I.	CONTRACTOR SHOULD NOT SCALE DRAWINGS FOR OUTLET AND EQUIPMENT LOCATIONS, UNLESS SPECIFICALLY DIMENSIONED ON DRAWINGS OR DEFINED IN SPECIFICATIONS. OUTLETS AND EQUIPMENT SHALL BE LOCATED AS EVIDENTLY INTENDED OR AS DETAILED ON ARCHITECTURAL DRAWINGS. LIGHTING OUTLETS ARE TO BE CENTERED OR SPACED SYMMETRICALLY UNLESS THEY ARE DIMENSIONED, ANY DIMENSIONS SHOWN ON THE DRAWINGS SHALL BE VERIFIED BY THE FIELD BY THE CONTRACTOR PRIOR TO ROUGHING. ALL OUTLET AND EQUIPMENT LOCATIONS SHALL BE COORDINATED WITH THE OTHER TRADES. IF ANY DOUBT ARISES, CONTACT THE ENGINEER PRIOR TO ROUGHING.
J.	THE CONTRACTOR SHALL KEEP PREMISES FREE OF DEBRIS RESULTING FROM THIS WORK.

3.2	TESTS AND GUARANTEES
A.	ALL CURRENT-CARRYING PHASE CONDUCTORS AND NEUTRALS SHALL BE TESTED AS INSTALLED, AND BEFORE CONNECTIONS ARE MADE, FOR INSULATION RESISTANCE AND ACCIDENTAL GROUNDING. EACH FIXTURE AND ITEM OF EQUIPMENT FOR CONNECTION UNDER THE CONTRACT SHALL BE TESTED FOR INSULATION RESISTANCE FROM ITS CONDUCTORS TO ITS GROUNDING SURFACE OR CONTACT. THESE TESTS SHALL BE DONE WITH A 500 VOLT (MINIMUM) HIGH VOLTAGE MEGGER.

B.	1. MINIMUM READINGS SHALL BE ONE MILLION (1,000,000) OR MORE OHMS FOR #6 AWG AND SMALLER WIRE, 250,000 OHMS OR MORE FOR #4 AWG AND LARGER WIRE. BETWEEN CONDUCTORS AND BETWEEN CONDUCTORS AND THE GROUNDING CONDUCTOR.
	2. AFTER ALL FIXTURES, DEVICES, AND EQUIPMENT ARE INSTALLED AND ALL CONNECTIONS COMPLETED TO EACH PANEL, THE CONTRACTOR SHALL DISCONNECT THE NEUTRAL FEEDER CONDUCTOR FROM THE NEUTRAL BAR AND TAKE A MEGGER READING BETWEEN THE NEUTRAL BAR AND THE GROUNDING ENCLOSURE OR GROUND BAR. IF THIS READING IS LESS THAN 250,000 OHMS, THE CONTRACTOR SHALL DISCONNECT THE BRANCH CIRCUIT NEUTRAL WIRES FROM THIS NEUTRAL BAR. THEY SHALL, THEN TEST EACH ONE SEPARATELY TO THE PANEL AND UNTIL THE LOW READINGS ARE FOUND. THE CONTRACTOR SHALL CORRECT TROUBLES, RECONNECT AND RETEST UNTIL AT LEAST 250,000 OHMS FROM THE NEUTRAL BAR TO THE GROUNDING PANEL CAN BE ACHIEVED WITH ONLY THE NEUTRAL FEEDER DISCONNECTED.
	3. THE CONTRACTOR SHALL SEND A LETTER TO THE ENGINEER CERTIFYING THAT THE ABOVE HAS BEEN DONE AND SHOWING THE TABULATION OF THE MEGGER READINGS FOR EACH PANEL OR FEEDER. THIS SHALL BE DONE AT LEAST FOUR (4) DAYS PRIOR TO FINAL WALK-THROUGH BY ENGINEER.
	4. AT FINAL WALK-THROUGH BY THE ENGINEER, THE CONTRACTOR SHALL FURNISH A MEGGER AND DEMONSTRATE THAT THE PANELS COMPLY WITH THE ABOVE REQUIREMENTS. THEY SHALL ALSO FURNISH A CLAMP-ON TYPE AMMETER AND A VOLT/METER TO TAKE CURRENT AND VOLTAGE READINGS AS DIRECTED BY THE ENGINEER.
B.	VALIDITY OF THE GROUND PATH SHALL BE ASSURED BY CONSTANT AND CAREFUL ATTENTION TO THE THOROUGH TIGHTENING OF ALL COUPLINGS, CONNECTORS, LOCKNUTS, SCREWS, BOLTS, ETC. AND BY FREQUENT CHECKING OF THE PATH RESISTANCE WITH A QUALITY LOW-RANGE OHMMETER. RESISTANCE OF THE PATH SHOULD NOT EXCEED ONE OHM BETWEEN ANY TWO POINTS. IF A READING IN EXCESS OF THIS IS OBTAINED, THE CONTRACTOR SHALL BE DISQUALIFIED BY THE ENGINEER FOR AN APPRAISAL OF THE CONDITION.
	CONTRACTOR SHALL GUARANTEE THAT THE WORK IS DONE IN ACCORDANCE WITH DRAWINGS AND SPECIFICATIONS, AND THAT IT IS FREE OF IMPERFECT MATERIALS OR DEFECTIVE WORKMANSHIP. ANYTHING UNSATISFACTORY SHALL BE CORRECTED IMMEDIATELY AND AT CONTRACTORS EXPENSE.
D.	FOR THE PERIOD OF ONE YEAR AFTER ACCEPTANCE BY THE OWNER, THE CONTRACTOR SHALL REPLACE, WITHOUT ANY EXPENSE TO THE OWNER, ANY IMPERFECT MATERIALS OR DEFECTIVE WORKMANSHIP.

3.3	RECORD DRAWINGS/MANUALS
-----	-------------------------

A.	UPON COMPLETION OF THE INSTALLATION, CONTRACTOR SHALL SUBMIT TO THE ENGINEER MARKED PRINTS OF DRAWINGS SHOWING ANY CHANGES MADE IN CIRCUITS, LOCATION OF EQUIPMENT, PANELBOARDS, OR ANY OTHER REVISION IN THE CONTRACT DRAWINGS. FOR THE OWNERS USE IN MAINTENANCE WORK AND FOR FUTURE ADDITIONS AND EXPANSIONS. MARKED CHANGES SHALL ALSO INCLUDE CHANGES DUE TO CHANGE ORDERS UNLESS ALREADY RECORDED BY REVISED DRAWING OR BULLETIN DRAWING.
B.	THESE RECORD DRAWINGS SHALL BE SUBMITTED IN ONE OF TWO FORMATS: EITHER A CLEAN, LEGIBLE, MARKED SET OF BLUE-LINE PRINTS WITH ALL MARKINGS IN DISTINGUISHABLE COLORED PENCIL SUCH AS RED, OR A SET OF REVERSE-RUN REPRODUCIBLE SEPIA PRINTS MARKED IN STENCIL. SUCH THAT BLUE-LINE PRINTS CAN BE REPRODUCED AS REQUIRED. THE FORMAT TO BE USED SHALL BE AS DEFINED IN THE GENERAL REQUIREMENTS SECTION OF THE CONTRACT DOCUMENTS. IF NO FORMAT IS DEFINED, THE MARKED BLUE-LINE PRINTS SHALL BE SUBMITTED.
C.	OPERATION AND MAINTENANCE MANUALS SHALL BE SUBMITTED TO THE ENGINEER AT THE END OF THE PROJECT PRIOR TO CLOSEOUT OF THE PROJECT. INFORMATION INCLUDED SHALL BE A COPY OF ALL SUBMITTAL DATA, SHOP DRAWINGS, AND NECESSARY OPERATING AND MAINTENANCE INSTRUCTIONS AND WIRING DIAGRAMS ON ALL MAJOR ITEMS OF EQUIPMENT AND ALL SPECIAL SYSTEMS (FIRE ALARM, INTERCOM, ETC.). SUBMIT THESE MANUALS IN THE QUANTITIES AND FORMAT DESCRIBED IN THE GENERAL REQUIREMENTS SECTION.

END OF SECTION 26 05 01	
-------------------------	--

SECTION 26 05 02-ALTERATIONS AND ADDITIONS TO EXISTING ELECTRICAL WORK AND BUILDING AREAS	
PART 1	GENERAL
1.1	REQUIREMENTS
A.	MANUFACTURERS ARE NOT APPLICABLE.
PART 2	PRODUCTS
2.1	NOT APPLICABLE
PART 3	INSTALLATION
3.1	ALL NECESSARY ADDITIONS AND ALTERATIONS TO EXISTING WORK SHALL BE INCLUDED IN THE CONTRACT AS REQUIRED TO PROVIDE AND MAINTAIN A COMPLETE AND PROPER ELECTRICAL INSTALLATION. THIS WORK SHALL INCLUDE:
A.	RELOCATION OF FIXTURES, PULLBOXES, RACEWAYS, ETC., TO PERMIT THE INSTALLATION OF NEW EQUIPMENT.
B.	INSTALLATION OF NEW CONDUITS AND CONDUCTORS TO MAINTAIN TEMPORARY AND PERMANENT USE OF ELECTRICAL FACILITIES THROUGHOUT THE FACILITY.
C.	DISCONNECTION/RECONNECTIONS AND REMOVAL/REINSTALLATION OF ELECTRICAL SUPPLY, CONTROL, AND UTILIZATION EQUIPMENT REQUIRED FOR CONTINUED OPERATION, INCLUDING TEMPORARY WORK AS REQUIRED.

END OF SECTION 26 05 02	
-------------------------	--

D.	PROVISIONS FOR THE RELOCATION OF ALL PIPING, DUCTWORK, ETC., AS REQUIRED FOR ELECTRICAL WORK, WHERE NOT SHOWN OR SPECIFIED BY OTHERS. THE ELECTRICAL CONTRACTOR SHALL NOTIFY THE AE PRIOR TO BID SO THAT THE APPROPRIATE TRADE MAY BE ASSIGNED TO BID. OTHERWISE, THE ELECTRICAL CONTRACTOR SHALL BE HELD RESPONSIBLE FOR ALL SUCH RELOCATIONS.
E.	REUSE OF EXISTING RACEWAY SYSTEM IS ACCEPTABLE; HOWEVER, THE CONTRACTOR TAKES ALL RESPONSIBILITY FOR DETERMINING SUITABILITY FOR REUSE AND COMPLIANCE WITH SPECIFICATIONS. NEW RACEWAYS SHALL BE PROVIDED, OR EXISTING RACEWAYS UPGRADED, AS NEEDED TO MEET THE REQUIREMENTS OF THE CONTRACT DOCUMENTS.
F.	ALL EXISTING RACEWAYS SHALL BE RELOCATED IN FINISHED AREAS TO BE CONCEALED WITHIN WALLS AND CEILINGS, WHETHER SPECIFICALLY INDICATED ON DRAWINGS OR NOT.
G.	SITE INVESTIGATION BY CONTRACTOR IS REQUIRED IN 26 05 01. ACCORDINGLY, THE CONTRACTOR SHALL NOT BE ENTITLED TO ANY EXTRA COMPENSATION FOR REMOVAL OR RELOCATION OF EXISTING WORK WHICH IS REQUIRED TO COMPLETE THE PROJECT, BUT NOT INDICATED ON THE CONTRACT DOCUMENTS. REFER QUESTIONS TO THE AE PRIOR TO BID DATE.
H.	EQUIPMENT TO BE TURNED OVER TO OWNER SHALL BE TURNED OVER IN A CLEAN AND WORKING CONDITION. VERIFICATION OF CONDITIONS IS THE CONTRACTORS RESPONSIBILITY PRIOR TO BIDDING.
I.	DISCONNECT ELECTRICAL SERVICES TO EQUIPMENT TO BE REMOVED, REMOVE ALL UNUSED CONDUIT AND CONDUCTORS BACK TO POINT OF ORIGIN, OR TO NEXT ACTIVE DEVICE, OR TO BE REUSED UNDER NEW CONSTRUCTION.
J.	UNUSED RACEWAY SYSTEMS CAN BE ABANDONED WHERE CONCEALED IN FLOORS OR WALLS, BUT MUST BE REMOVED FROM CEILING SPACES.
K.	EXISTING WORK WHICH MUST BE RELOCATED BUT IS NOT DETECTABLE BY A COMPETENT PRE-BID SURVEY WILL BE CONSIDERED FOR ADDITIONAL COMPENSATION BY THE CONTRACTOR.
L.	WHERE WALL OR FLOOR FINISHES ARE TO BE REPLACED IN AREAS WITH EXISTING TO REMAIN ELECTRICAL WORK, THE CONTRACTOR SHALL ADAPT THE ELECTRICAL WORK TO MATCH WITH APPROPRIATE BOX EXTENSIONS, TRIM RINGS, COVER PLATES, ETC., AS REQUIRED.
M.	DUCTWALK SHOULD ALWAYS BE MEASURED TO TOP-OF-CONCRETE AND BOTTOM-OF-CONCRETE FOR DESIGN CONDITIONS, INSTALLATIONS, AND RECORD DOCUMENTS.

END OF SECTION 26 05 02	
-------------------------	--

SECTION 26 05 19-08-CONDUCTORS, 600 VOLT INSULATION	
PART 1	GENERAL
1.1	MANUFACTURERS REQUIREMENTS
A.	WIRING: BICC CABLES, ESSEX, GENERAL CABLE, SOUTHWIRE AND PIRELLI
B.	CONNECTORS: AMERICAN INSULATED WIRE CORPORATION, AMP, BUNRDY, IDEAL, OZGIDENEY, SCOTCHMAN, POLARIS ELECTRICAL CONNECTORS, OR THOMAS & BETTS
PART 2	PRODUCTS
2.1	MATERIALS

A.	ALL WIRING FOR POWER CIRCUITS SHALL BE #12 AWG OR LARGER, TYPE THWN, THHN, OR XHHW.
B.	ALL WIRING WHERE USE IS PERMITTED FOR CONTROL AND SIGNAL CIRCUITS OPERATING ABOVE 50 VAC, WHERE MANUFACTURERS INSTALLATION REQUIREMENTS ALLOW.
C.	ALL WIRING SHALL BE STRANDED COPPER.
D.	ALL WIRING WITHIN LIGHT FIXTURES SHALL BE RATED AT LEAST 90 DEGREES CELSIUS, OR HIGHER AS REQUIRED BY THE MANUFACTURER OF THE LIGHT FIXTURE.
E.	ALL WIRING #6 AND SMALLER SHALL BE PURCHASED WITH PROPER INSULATION COLOR. WIRES #4 AND LARGER SHALL BE BLACK AND IDENTIFIED WITH COLORED TAPE.

PART 3	EXECUTION
3.1	INSTALLATION
A.	SPICES SHALL HAVE MECHANICAL STRENGTH AND INSULATION STRENGTH EQUAL TO, OR SUPERIOR TO, THE CONDUCTOR, AND SHALL BE TAPED. ALL SPLICES OF #6 AWG OR LARGER SHALL BE MECHANICAL CONNECTIONS COVERED WITH RUBBER TAPE, FRICTION TAPE OR PLASTIC TAPE. AT CONTRACTORS OPTION, SOLDERLESS MECHANICAL TYPE CONNECTORS WITH INSULATED COVERS MAY BE USED.
B.	SPLICING OF #10 AWG AND SMALLER CONDUCTORS SHALL BE MADE WITH WIRE NUTS OR WING NUTS.
C.	PROVIDE AN OPEN-ENDED SPRADE TYPE TERMINATION DEVICE ON ANY CONDUCTOR WHICH SHALL TERMINATE UNDER A SCREW OR ON A TERMINAL BLOCK (I.E. RECEPTABLES, SWITCHES, TERMINALS).
D.	#8 AND LARGER WIRING SHALL TERMINATE IN AN "INDENT TYPE" HEX SCREW OR BOLT-CLAMP TYPE BRONZE LUGS APPROVED OR EQUAL TO BUNRDY OR DZ. CAST LUGS SHALL HAVE MACHINED CONTACT SURFACE. #20 AND LARGER SIZES SHALL HAVE TWO CLAMPING OR COMPRESSION INDENTS. THE CONTRACTOR SHALL TRANSMIT THESE REQUIREMENTS TO MANUFACTURERS OF PANELBOARDS AND SWITCHBOARDS. NON-COMFORMING PRODUCTS SHALL BE REPLACED.
E.	FASTENING OF CONDUCTORS SHALL REQUIRE TWO LAYERS OF FRICTION TAPE, TWO LAYERS OF FRICTION TAPE, AND ONE LAYER OF PLASTIC TAPE.
F.	INSTALL ALL CONDUCTORS IN RACEWAY. NO RACEWAY SHALL CONTAIN MORE THAN TWO PHASE CONDUCTORS, TWO NEUTRALS, AND GROUND, EXCEPT FOR SWITCH LEGS AND TRAVELERS DERIVED FROM THE SAME PHASE CONDUCTOR IN LIGHTING RACEWAYS.
G.	EACH MULTIWIRE BRANCH CIRCUIT SHALL HAVE A DEDICATED NEUTRAL CONDUCTOR FOR EACH PHASE CONDUCTOR.
H.	CONDUCTOR LENGTHS SHALL BE ADEQUATE TO ALLOW FOR DISCONNECTION AND SERVICING, NO CONNECTIONS OR SPLICES SHALL BE UNDER TENSION.
I.	CALIBRATED TORQUE WRENCH SHALL BE USED FOR TIGHTENING OF ALL BOLT TIGHTENING. TORQUE BOLTS TO MANUFACTURERS SPECIFIED VALUES.
K.	USE RUBBER INSULATED CONNECTORS SIMILAR TO OR EQUAL TO POLARIS LUGS FOR FEEDER SPLICES. SPLIT BOLT CONNECTORS SHALL NOT BE USED.
L.	ALL CONDUCTORS FOR POWER AND LIGHTING CIRCUITS SHALL BE COLOR-CODED IN ACCORDANCE WITH THE NEC. WIRES #6 AND SMALLER SHALL BE PURCHASED WITH THE PROPER COLOR INSULATION. WIRES #4 AND LARGER SHALL BE BLACK, WITH TAPE TO IDENTIFY COLOR IN ALL PANELBOARD EQUIPMENT TERMINAL HOUSINGS, AND PULL-JUNCTION BOXES. COLOR CODES SHALL BE AS FOLLOWS:

PHASE A	288V/120V	480V/277V	ISOLATED
PHASE B	BLACK	BROWN	BROWN (LINE 1)
PHASE C	RED	ORANGE	BROWN (LINE 2)
PHASE D	BLUE	YELLOW	YELLOW (LINE 3)
NEUTRAL	WHITE	GRAY	GRAY
GROUNDING	GREEN	GREEN	GREEN

END OF SECTION 26 05 19-08	
----------------------------	--

SECTION 26 05 19-10-LIGHT AND POWER FEEDER CIRCUIT INSTALLATIONS	
--	--

PART 1	GENERAL
1.1	MANUFACTURERS REQUIREMENTS
A.	NOT APPLICABLE.
PART 2	PRODUCTS
2.1	MATERIALS
A.	NOT APPLICABLE.
PART 3	EXECUTION
3.1	INSTALLATION
A.	EVERY FEEDER SHALL INCLUDE AN EQUIPMENT GROUNDING CONDUCTOR, SIZED PER NEC, ROUTED IN THE SAME RACEWAY WITH THE CIRCUIT CONDUCTORS.
B.	ALL RACEWAYS, WIREWAY, AUXILIARY GUTTERS, PANELBOARDS, JUNCTION BOXES, ETC. SHALL HAVE ADEQUATE WIRING SPACE FOR THE CONDUCTORS INSTALLED. NOTE THAT SOME PANELBOARDS MAY REQUIRE LARGER THAN STANDARD ENCLOSURES TO PROVIDE ADEQUATE GUTTER SPACE FOR THE FEEDER CONDUCTORS CONNECTED.
C.	WIREWAY FEEDERS SHALL BE Laid FLAT AND CUT TO IDENTICAL LENGTH PRIOR TO PULLING INTO RACEWAY. DO NOT CUT OR TRIM PARALLEL FEEDERS AFTER INSTALLATION.
D.	FEEDER CONDUCTORS, INCLUDING NEUTRAL AND GROUND CONDUCTORS, SHALL BE MULTIPLEXED IN AN ARRANGEMENT WHICH ROTATES THE POSITION OF THE NEUTRAL AND GROUND CONDUCTORS ABOUT THE PHASE CONDUCTORS. WIRE TIES SHALL BE USED TO MAINTAIN ROTATION IN PULL BOXES, WIREWAYS, ETC.
E.	WHERE BRANCH CIRCUITS AND FEEDERS ARE INSTALLED IN EXISTING PANELBOARDS, THE CONTRACTOR SHALL RESEARCH AND TRACE OUT EXISTING CIRCUITS SERVED FROM THE PANELBOARDS, AND PROVIDE AN "AS BUILT" TYPEWRITTEN CIRCUIT DIRECTORY CARD FOR EACH PANELBOARD.
F.	ALL JUNCTION BOXES SHALL BE LABELED WITH PANEL NAME AND CIRCUITS BEING CONTAINED.

END OF SECTION 26 05 19-10	
----------------------------	--

SECTION 26 05 19-11-ELECTRICAL WIRING AND CONNECTIONS FOR EQUIPMENT	
---	--

PART 1	GENERAL
1.1	MANUFACTURERS REQUIREMENTS
A.	NOT APPLICABLE.
PART 2	PRODUCTS
2.1	MATERIALS
A.	NOT APPLICABLE.
PART 3	EXECUTION
3.1	INSTALLATION
A.	CONNECTIONS TO MOTORS, TRANSFORMERS, AND OTHER VIBRATING EQUIPMENT: USE LIQUID TIGHT FLEXIBLE METAL CONDUIT, LIMIT TO 6 FEET LENGTH.
B.	WHERE THE NAMEPLATE RATING OF THE SUPPLIED EQUIPMENT REQUIRES SERVICE FROM A FUSED DEVICE, CONTRACTOR SHALL PROVIDE A FUSED DISCONNECT IN LIEU OF ANY NON-FUSED DISCONNECT SHOWN ON THE DRAWINGS, AT NOT EXTRA COST.
C.	ALL LOW VOLTAGE COMMUNICATIONS WIRING SHALL BE ROUTED IN EMT CONDUIT MADE WATER TIGHT WITH COMPRESSION FITTINGS IN OUTDOOR LOCATIONS, EXCEPT WHERE RUN IN CONCEALED, ACCESSIBLE AREAS. ALL LOW VOLTAGE WIRING MUST BE ROUTED IN CONDUIT IN MECHANICAL ROOMS, ALL EXPOSED WIRING SHALL BE PLENUM RATED, AND SUPPORTED AS CODE REQUIRES.
E.	AT FEEDER/HEAD MOTOR CONNECTIONS USE RUBBER INSULATED CONNECTIONS/LUGS.

END OF SECTION 26 05 19-11	
----------------------------	--

SECTION 26 05 26-02-GROUNDING AND BONDING	
---	--

PART 1	GENERAL
1.1	REQUIREMENTS
A.	ALL SYSTEMS AND EQUIPMENT SHALL BE GROUNDED IN ACCORDANCE WITH 2020 NEC ARTICLE 250 AND 517.
PART 2	PRODUCTS
2.1	MATERIALS
A.	GROUNDING AND BONDING CONDUCTORS: 600V COPPER CONDUCTORS, THWN, THHN FOR GROUNDING SYSTEMS, XHHW-2, RHHW-2 FOR ISOLATED POWER SYSTEMS.
B.	CONDUIT: GROUNDING CONDUITS TO WIRING DEVICES OR OTHER POWERED ELECTRICAL DEVICES SHALL BE ROUTED IN EMT CONDUIT AS ARE GROUNDING CONDUCTORS FROM GROUND JUNCTION BOX TO CENTRAL GROUND JUNCTION BOX. GROUNDING CONDUCTORS TO PIPING, METAL STRUCTURE, CEILING GRID, AND SIMILAR ARE NOT REQUIRED TO BE ROUTED IN CONDUIT.
PART 3	EXECUTION
3.1	INSTALLATION
A.	IN EACH OPERATION ROOM, PROCEDURE ROOM, ETC., INDICATED TO HAVE EQUIPMENT/POINTAL GROUNDING SYSTEM, THE FOLLOWING SHALL BE BONDED TOGETHER TO THE ROOM JUNCTION BOX: 1. ALL EXPOSED METAL, 2. ALL CONDUCTIVE BUILDING SURFACES AND UTILITIES RUNNING THROUGH THE ROOM, 3. GROUND JACKS, 4. EQUIPMENT GROUND BUS IN PANELBOARDS AND LINE ISOLATION PANELBOARDS SERVING THE ROOM.
B.	BONDING CONDUCTORS FOR NON-ELECTRICAL ITEMS SHALL BE #10 STRANDED WIRE. BONDING CONDUCTORS SHALL BE DEDICATED AND NOT "LOOPED".
C.	BONDING OF METAL DOORS FRAMES, WINDOW FRAMES, AND OTHER FLAT METAL SURFACES SHALL BE MADE WITH WELDING A 10-32 STUD.
D.	TEST GROUNDING CONTINUITY PRIOR TO CLOSING WALLS AND CEILING.

END OF SECTION 26 05 26	
-------------------------	--

SECTION 26 05 33-RACEWAY, BOXES, AND SUPPORTS	
PART 1	GENERAL
1.1	REQUIREMENTS
A.	ALL MATERIAL SHALL BE AS LISTED AND SHALL BE INSTALLED IN CONFORMANCE WITH THE 2020 NATIONAL ELECTRICAL CODE.
PART 2	PRODUCTS
2.1	RACEWAYS
A.	CONDUIT BODIES: ALLIED, TRIANGLE, WHETLEAND OR APPROVED EQUIVALENT
B.	FITTINGS AND BUSHINGS: THOMAS AND BETTS, RACO, OR STEEL CITY
C.	RIGID METAL CONDUIT (RMC) SHALL BE USED FOR SERVICE ENTRANCE FEEDERS, FEEDERS LEAVING ALL FREESTANDING SWITCHBOARDS, AND ALL PANEL FEEDERS. RMC SHALL ALSO BE USED FOR FEEDER OR BRANCH CIRCUITS RUN IN POURED CONCRETE, UNDERGROUND, OR EXPOSED TO WEATHER UNLESS SHOWN OTHERWISE ON PLANS.
D.	ELECTRIC METALLIC TUBING (EMT) SHALL BE USED FOR GENERAL BRANCH CIRCUITS UNLESS INDICATED OTHERWISE ON PLANS OR STATED OTHERWISE IN THESE SPECIFICATIONS.
E.	EMT COUPLINGS AND CONNECTORS SHALL BE COMPRESSION-GLAND TYPE OF MALLEABLE STEEL, GALVANIZED OR SHERARDIZED. CONNECTORS SHALL BE INSULATED, OR SET SCREW, INSEAL, OR SET TYPE FITTINGS, OR NOT ACCEPTABLE.
F.	GALVANIZED "FLEX" IN DRY AND "SEALTITE" IN WET LOCATIONS SHALL BE USED FOR CONNECTION TO MECHANICAL EQUIPMENT OR TRANSFORMERS, OR FOR LIGHTING FIXTURE WHIPS. FLEX RINGS SHALL BE NO GREATER THAN SIX FEET IN LENGTH.
G.	MINIMUM CONDUIT SIZE SHALL BE 3/4"
H.	LIFE SAFETY AND CRITICAL BRANCH CIRCUITS SHALL BE INSTALLED IN A SOLID RACEWAY SYSTEM. FLEXIBLE METAL CONDUIT, WITH A REDUNDANT GROUND PATH SHALL BE ONLY USED IN LOCATIONS OUTLINED UNDER NEC 517.30(C)(3).

2.2	BOXES
A.	INTERIOR OUTLET BOXES: APPLETON, NATIONAL, OZGIDENEY, STEEL CITY, OR RACO.
B.	WEATHERPROOF OUTLET BOXES: APPLETON, CROUSE-HINDS, HUBBELL, OR RUSSELLSTOLL.
C.	GALVANIZED OR ALUMINUM OF GAUGE REQUIRED BY NEC.
D.	ALL INTERIOR JUNCTION BOXES SHALL BE GALVANIZED STEEL WITH STAMPED KNOCKOUTS IN THE BACK AND SIDES, AND PULL BOXES SHALL BE 4 INCH SQUARE BY 1-1/2 INCH DEEP MINIMUM.
E.	WEATHERPROOF OUTLET BOXES SHALL BE CORROSION-RESISTANT CAST METAL SUITED TO THE APPLICATION AND LISTED FOR THE LOCATION, WITH THREADED CONDUIT ENDS, CAST METAL FACE PLATE WITH SPRING-HINGED WATERPROOF GASK, CASKET, AND CORROSION-PROOF FASTENERS.

2.3	FASTENINGS AND SUPPORTS
A.	SHALL BE OF GOOD QUALITY, GALVANIZED STEEL OR OTHER NON-CORRODING MATERIAL.


PART 3	EXECUTION
3.1	RACEWAY INSTALLATION

A.	MINIMUM RACEWAY SIZE SHALL BE 3/4" UNLESS NOTED OTHERWISE.
B.	ALL RACEWAY CONDUIT ONLY SHALL HAVE A 100 LBS. NYLON PULL ROPE INSTALLED IN THE CONDUIT.
C.	RIGID METAL CONDUIT SHALL BE MADE UP WITH FULL THREADED TO WHICH TAB "XOPRE-SHIELD" COMPOUND HAS BEEN APPLIED, AND BUTTED IN COUPLINGS.
D.	2. SPLIT OR "ERICKSON" COUPLINGS WHERE NECESSARY.
E.	NO CONDUIT SHALL BE RUN IN POURED CONCRETE FLOORS OR SLABS. CONDUIT RUNS SHALL NORMALLY BE RUN OVERHEAD, WHERE IT IS NECESSARY TO RUN UNDERNEATH A CONCRETE SLAB POURED ON-GRADE, CONDUIT SHALL BE BURIED IN TRENCH BENEATH GRAVEL BASE AND TURNED UP THROUGH SLAB, WHERE IS NECESSARY TO RUN UNDERNEATH A FLOOR ABOVE A CRAWL SPACE OR ANOTHER FLOOR.
F.	CONDUIT SHALL BE RUN ALONG CEILING SPACE UNDER FLOOR AND STUBBED THROUGH FLOOR USING APPROPRIATE METHODS, SUCH AS "POKE-THROUGH" DEVICES OR OTHER MEANS UL APPROVED FOR SUCH PURPOSE.
G.	UNDERGROUND RUNS, EXCEPT UNDER CONCRETE FLOOR SLABS, SHALL HAVE A MINIMUM OF 24" COVER. BACKFILL SHALL BE MADE IN 6" LAYERS, TAMPING EACH LAYER TO A DENSITY OF 95% OF MAXIMUM POSSIBLE.
H.	ATTACH RIGID METAL CONDUITS WITH DOUBLE LOCKNUTS: ONE INSIDE AND ONE OUTSIDE, AND FIBER BUSHING.
I.	GROUNDING TYPE INSULATED BUSHINGS SHALL BE USED, WHERE RACEWAY ENTERS BOXES WITH CONCENTRIC OR OVERSIZED KNOCKOUTS. THESE BUSHINGS SHALL HAVE MACHINED CONTACT SURFACE. #20 AND LARGER SIZES SHALL HAVE TWO FORMER CABINETS. GROUNDING TYPE INSULATED BUSHINGS SHALL ALWAYS BE USED ON BOTH ENDS OF CONDUITS FEEDING PANELBOARDS.
J.	PROVIDE SUITABLE FITTINGS WHERE RACEWAY CROSSES BUILDING EXPANSION JOINTS.
K.	SECURELY FASTEN IN PLACE. ALL BRANCH CIRCUIT STUDS INTO SWITCHBOARDS, OR TRANSFORMER CABINETS, GROUNDING TYPE INSULATED BUSHINGS SHALL ALWAYS BE USED ON BOTH ENDS OF CONDUITS FEEDING PANELBOARDS.
L.	MAKE ALL CUTS SQUARE WITH HACKSAW. REMOVE ANY BURRS OR SHOULDERS BY REAMING.
M.	ALL RUNS EXPOSED AND ALL RUNS ABOVE ACCESSIBLE CEILINGS SHALL BE NEAT AND SQUARE WITH BUILDING STRUCTURE SUCH AS WALLS AND CEILING/ROOF STRUCTURES. MULTIPLE PARALLEL RUNS SHALL USE TRAPEZE SUPPORTS WHERE POSSIBLE.
N.	"FLEX" AND "SEALTITE" CONNECTIONS WITH TAB "TITE-BITE" AND "SUPER-TITE" OR APPROVED EQUIVALENT FITTINGS, SHALL HAVE INSULATED THROATS.
O.	MAXIMUM BENDS BETWEEN POWER PULL POINTS IS 270°. PROVIDE NO MORE THAN THREE (3) 90° EQUIVALENT BENDS BETWEEN PULL POINTS.
P.	MAXIMUM DISTANCE BETWEEN POWER PULL BOXES IS 150 FEET.


3.2	BOX INSTALLATION
-----	------------------

A.	INSTALL OUTLETS AT LOCATIONS ON THE DRAWINGS. HOWEVER, THE OWNER SHALL HAVE THE RIGHT TO MAKE SLIGHT CHANGES IN LOCATIONS TO REFLECT ROOM FURNITURE AND EQUIPMENT LAYOUTS.
B.	ATTACH EMT WITH NON-CORRODIBLE MATERIALS AS TO PROVIDE 1/4" AIR SPACE BETWEEN WALL AND EQUIPMENT OR RACEWAY.
C.	OUTLET BOXES SHALL BE SIZED IN ACCORD WITH THE NEC SECTION 370. DEVICE BOXES SHALL BE SECTIONAL, TYPE OR 4 SQUARE EQUIPPED WITH PLASTER RINGS AS REQUIRED TO MOUNT THE DEVICE. SET GROUT FLUSH WITH FINISHED SURFACE. BOXES MAY BE INSTALLED AT TOP OR BOTTOM OF A MASONRY COURSE, RACO MASONRY BOXES IN SAWED BLOCK, 1-1/4" AND DEEPER PLASTER RINGS MAY BE OF DIE-CAST ALUMINUM OF STEEL CITY MAKE.
D.	WHERE INSTALLED IN METAL STUD PARTITIONS, WALL BOXES SHALL BE SUPPORTED FROM TWO ADJACENT STUDS USING A SYSTEM SUCH AS CADDY BAR HANGER ASSEMBLY, OR EQUIVALENT, SUPPORT ON A SINGLE STUD IS NOT ACCEPTABLE.
E.	WHERE NOT SHOWN DIFFERENTLY ON THE DRAWINGS, MOUNT:
F.	WHERE NOT SHOWN DIFFERENTLY ON THE DRAWINGS, MOUNT BOXES FOR RECEPTABLES TO RECEIVE DEVICE IN A VERTICAL POSITION AND BE:
	1. CENTERED 18" ABOVE FINISHED FLOOR.
	2. CENTERED 6" ABOVE COUNTERS, SHELVES, OR CABINETS WHERE APPARENTLY INTENDED TO BE SO PLACED.
	3. CENTERED 4" ABOVE HIGH EDGE OF BACKSPLASH.
	4. WHERE DEVICES ARE TO BE GANGED, PROVIDE BOXES TO RECEIVE DEVICES TRIMMED WITH A GANG PLATE.

3.3	FASTENINGS AND SUPPORTS INSTALLATION
A.	INSERTS IN MASONRY SHALL BE LEAD, FIBER, OR PLASTIC TYPES INSTALLED IN DRILLED HOLES. WOODEN PLUGS SHALL NOT BE USED. LEAD ONLY SHALL BE USED ON ALL EXTERIOR MASONRY OR INTERIOR MASONRY SUBJECT TO PERMANENT MOISTURE. HUNG RACEWAYS SHALL BE SUPPORTED FROM THE STRUCTURE WITH ROD SUPPORTS AT LEAST 5/16" IN DIAMETER.
B.	ALL EQUIPMENT AND PLAT RACEWAYS ATTACHED TO OUTSIDE WALL OR INTERIOR WALLS SUBJECT TO PERMANENT MOISTURE SHALL BE SHIMMED OUT WITH NON-CORRODIBLE MATERIALS AS TO PROVIDE 1/4" AIR SPACE BETWEEN WALL AND EQUIPMENT OR RACEWAY. ALL MATERIALS, WHETHER EXPOSED OR CONCEALED, SHALL BE FIRMLY AND ADEQUATELY HELD IN PLACE. FASTENING AND SUPPORT SHALL BE THE SAME SAFETY FACTOR AS THE FASTENING AND SUPPORTS FOR THE WALL.
C.	ALL RACEWAY AND EQUIPMENT SHALL BE SUPPORTED FROM THE STRUCTURE. NOTHING MAY BE SUPPORTED ON SUSPENDED CEILINGS, INCLUDING THE HANGER WIRES, UNLESS DEFINITELY NOTED SO ON THE DRAWINGS OR SPECIFICALLY PERMITTED BY THE ENGINEER.
D.	ALL DEVICES USING SUSPENDED CEILING SQUARE CEILING BOXES, INCLUDING THE HANGER WIRES, SHALL BE SUPPORTED ON SUSPENDED CEILINGS SHALL BE SUPPORTED FROM THE CEILING SYSTEM USING CADDY, OR OTHER, HANGERS SPECIFICALLY DESIGNED FOR SUCH SUPPORT. IN ADDITION, EACH OF THE FOUR CORNERS OF THE GRID BOX ENDOING THE BOX SHALL BE SUPPORTED FROM THE STRUCTURE USING 1/8" DIAMETER CONDUCTOR LUGS.
E.	RECESSED FLOURESCENT, HIGH INTENSITY, OR DOWNLIGHT FIXTURES SHALL BE SUPPORTED AT THE TWO (2) OPPOSITE ENDS TO THE STEEL FRAME OF THE BUILDING. SUPPORTS SHALL BE PROVIDED WITH THE SAME TYPE WIRE USED TO SUPPORT LAY-IN CEILING TRACK. FROM ONE END OF THE TRACK, THE FIRST FIXTURE AND THE SECOND TRACK TO THE NEXT, STRUCTURAL LUGS TO SUPPORT LAY-IN FIXTURES SHALL BE SCREWED TO THE MAIN RUNNERS OF THE LAY-IN CEILING TRACK AT ALL FOUR CORNERS USING SHEET METAL SCREWS.
F.	EXPLOSIVE SENS FASTENINGS USING THE LOW-VELOCITY TYPE TOOL MAY BE USED. EXTREME CAUTION SHALL BE EXERCISED IN THEIR USE.
G.	RESULTING FROM THE FASTENING AND SUPPORTS SHALL BE EXERCISED IN THEIR USE.

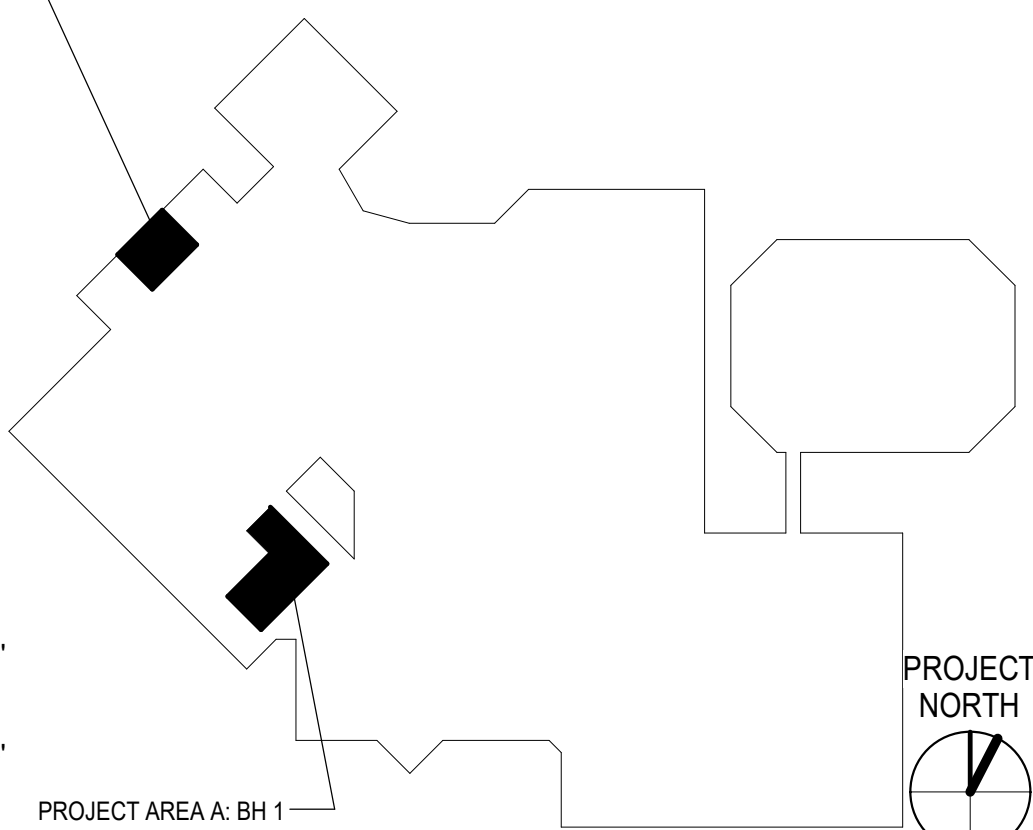

ALL DRAWINGS, SPECIFICATIONS AND NOTES HEREOF FURNISHED BY MC MILLAN PARDAN SMITH ARCHITECTURE ARE AND SHALL REMAIN THE PROPERTY OF MC MILLAN PARDAN SMITH ARCHITECTURE. THESE MATERIALS ARE TO BE USED ONLY WITH RESPECT TO THE PROJECT AND NOT TO BE REPRODUCED OR USED FOR OTHER PROJECTS WITHOUT THE WRITTEN CONSENT OF MC MILLAN PARDAN SMITH ARCHITECTURE. ANY REPRODUCTION OR USE FOR OTHER PROJECTS WITHOUT THE WRITTEN CONSENT OF MC MILLAN PARDAN SMITH ARCHITECTURE IS STRICTLY PROHIBITED. THE DRAWING AND INFORMATION THEREON IS THE PROPERTY OF MC MILLAN PARDAN SMITH ARCHITECTURE. ANY REPRODUCTION OR USE FOR OTHER PROJECTS WITHOUT THE WRITTEN CONSENT OF MC MILLAN PARDAN SMITH ARCHITECTURE IS STRICTLY PROHIBITED. THE DRAWING AND INFORMATION THEREON IS THE PROPERTY OF MC MILLAN PARDAN SMITH ARCHITECTURE. ANY REPRODUCTION OR USE FOR OTHER PROJECTS WITHOUT THE WRITTEN CONSENT OF MC MILLAN PARDAN SMITH ARCHITECTURE IS STRICTLY PROHIBITED.

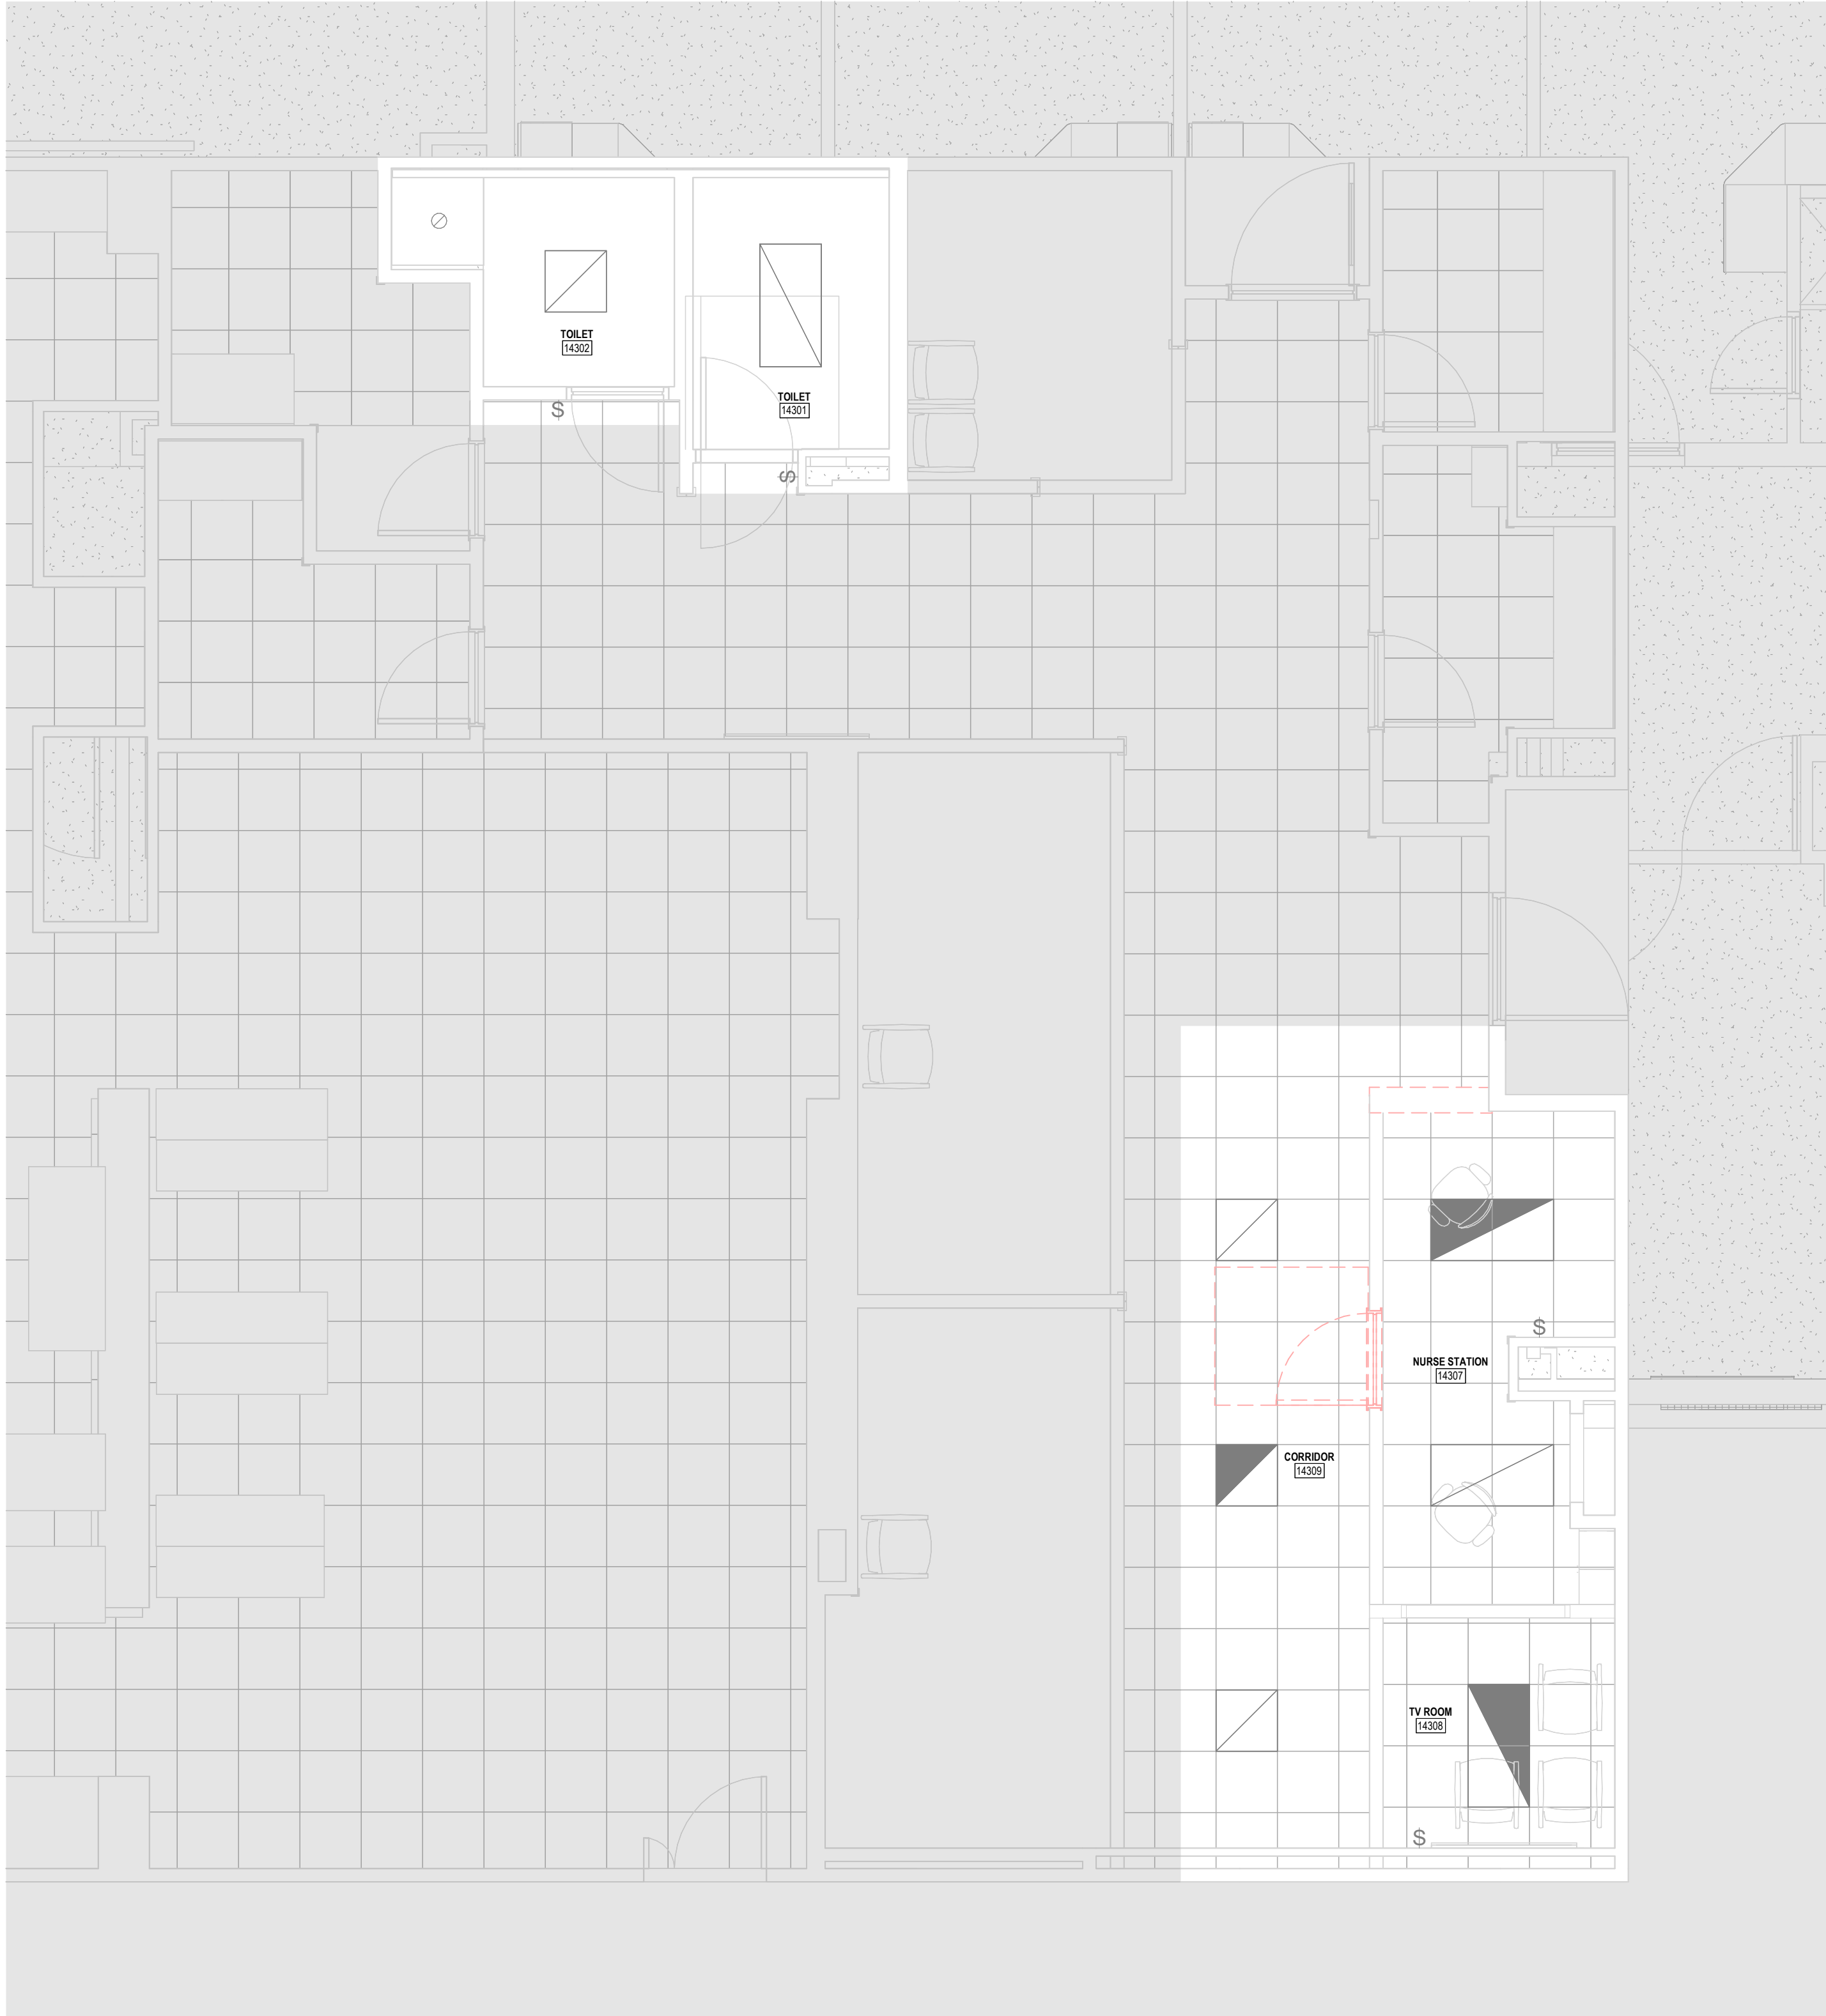


1 ELECTRICAL - LEVEL 01 - AREA A - BH 1 - LIGHTING - DEMOLITION
SCALE: 1/4" = 1'-0"

LINETYPE LEGEND	
—	EXISTING TO REMAIN
- - - - -	DEMOLITION



KEY PLAN

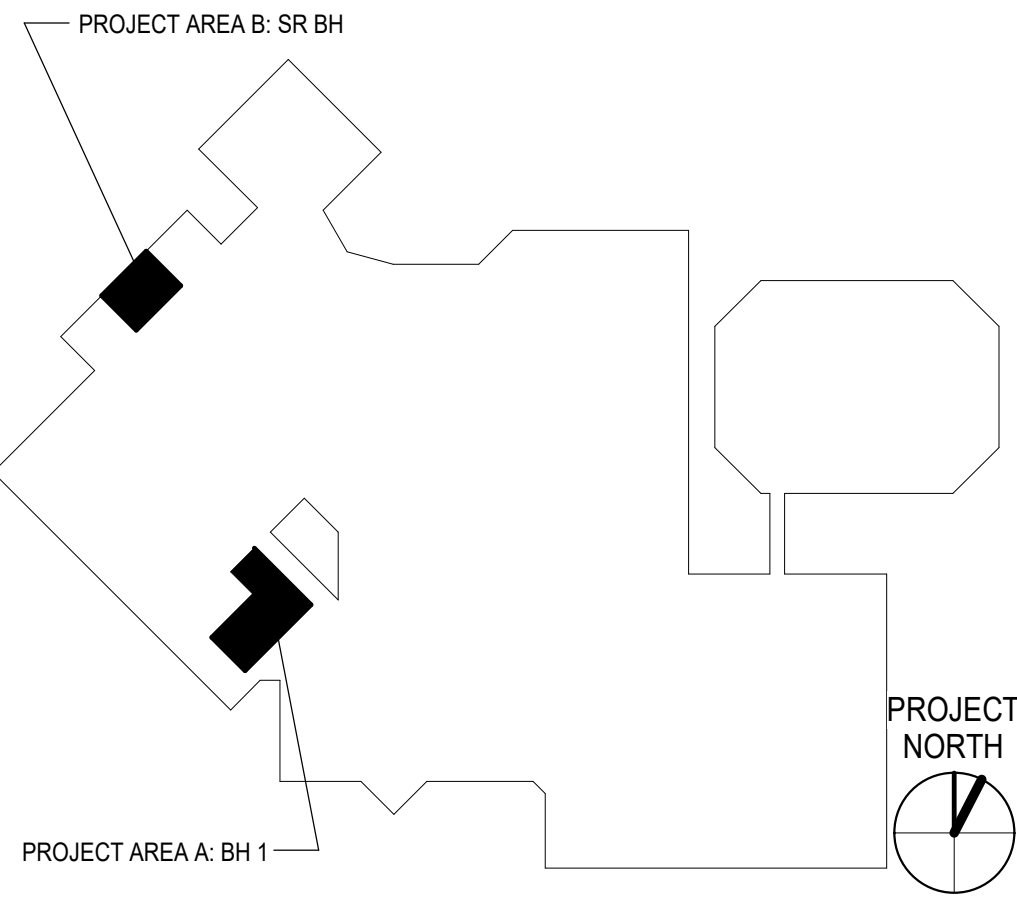

PRINCIPAL IN CHARGE: MS
PROJECT ARCHITECT: TAS
DRAWN BY: JGR

SHEET TITLE:
**ELECTRICAL - LEVEL 01 -
LIGHTING - DEMOLITION**

SHEET NO. PROJ. NO.
JAZZED_14452
MPS PROJ. NO.
02600404.00

E200

8020 Tower Point Drive Charlotte,
NC 28227
704.841.2588 (Voice)
704.841.2567 (Fax)
NC License # F-1222

Designed JGR Drawn JGR
Checked TPB Date TBD
Project No. 06681-0043

THIS DRAWING IS AN INSTRUMENT OF SERVICE. THE DRAWING AND
INFORMATION THEREON IS THE PROPERTY OF MCKIM & CREED, INC.
ANY REPRODUCTION, ALTERATION OR USE FOR OTHER THAN THE
INTENDED PROJECT WITHOUT WRITTEN CONSENT OF MCKIM &
CREED, INC. IS EXPRESSLY PROHIBITED. COPYRIGHT 2004, MCKIM &
CREED, INC.

Atrium Health
PROJECT & CONSTRUCTION MANAGEMENT
1400 East Morehead St.
Charlotte, NC 28204

CONSULTANT LOGO

SEALS



ATRIUM HEALTH
AH CABARRUS BH RENOVATION
AH Cabarrus Memorial Building
1232
920 Church Street North, Concord, NC 28025



ISSUE DATE: 07/15/2026
PHASE: Construction Documents
SHEET ISSUE:
NO. DATE DESCRIPTION

ALL DRAWINGS, SPECIFICATIONS AND NOTES HEREBY FURNISHED BY MC MILLAN PARDAN SMITH ARCHITECTURE ARE AND SHALL REMAIN THE PROPERTY OF MC MILLAN PARDAN SMITH ARCHITECTURE. THESE MATERIALS ARE TO BE USED ONLY WITH RESPECT TO THE PROJECT AND NOT TO BE REPRODUCED, COPIED, REPRODUCED, OR OTHERWISE USED FOR ANY OTHER PROJECT WITHOUT THE WRITTEN CONSENT OF MC MILLAN PARDAN SMITH ARCHITECTURE. ANY REUSE OF THESE MATERIALS FOR ANY OTHER PROJECT WITHOUT THE WRITTEN CONSENT OF MC MILLAN PARDAN SMITH ARCHITECTURE IS EXPRESSLY FORBIDDEN. COPYRIGHT 2024 MC MILLAN PARDAN SMITH ARCHITECTURE. ALL RIGHTS RESERVED.



1 ELECTRICAL - LEVEL 01 - AREA A - BH 1 - POWER AND SPECIAL SYSTEMS - DEMOLITION
SCALE: 1/4" = 1'-0"

LINETYPE LEGEND	
—	EXISTING TO REMAIN
- - - - -	DEMOLITION

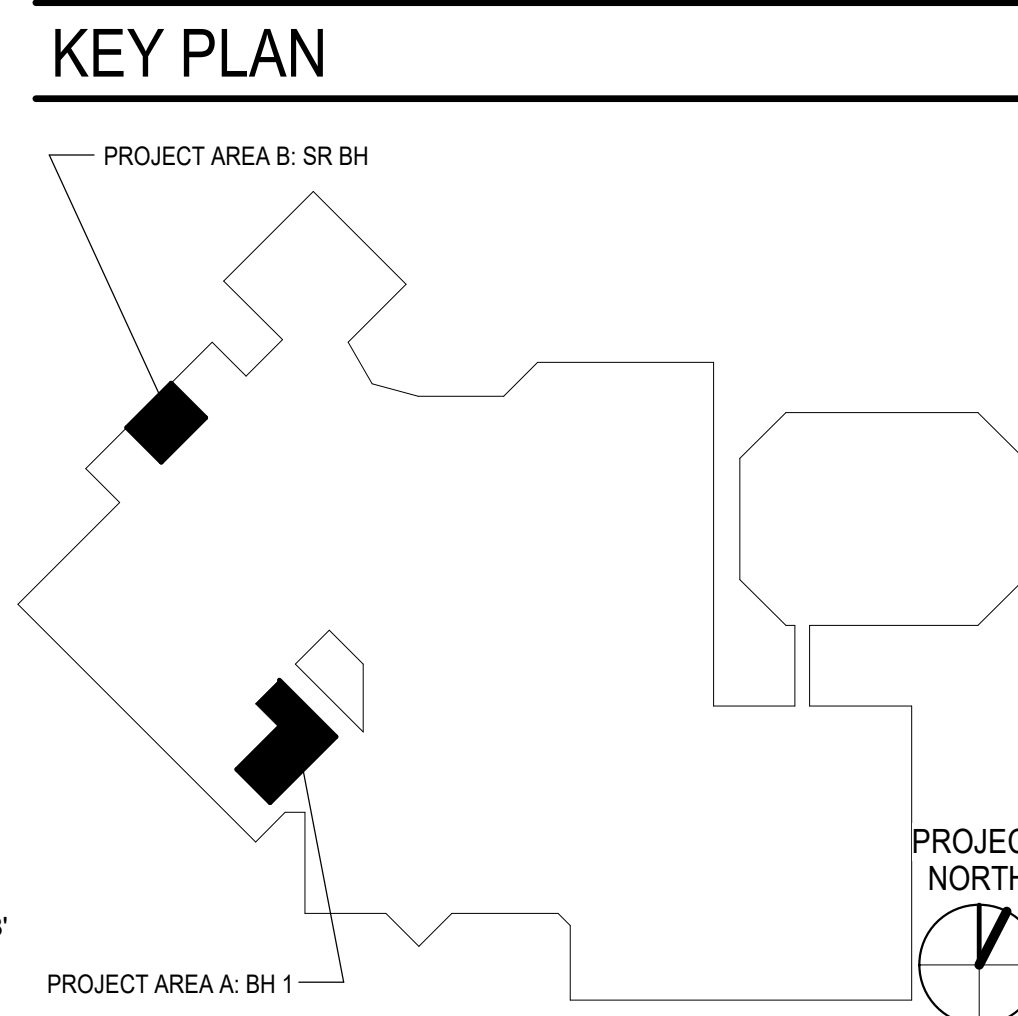 

PRINCIPAL IN CHARGE: MS
PROJECT ARCHITECT: TAS
DRAWN BY: JGR

SHEET NAME:
ELECTRICAL - LEVEL 01 - POWER AND SPECIAL SYSTEMS - DEMOLITION

SHEET NO. PROJECT NUMBER:
JAZZ10_14452


A/E PROJECT #: 02600404.00

E201

ALL DRAWINGS, SPECIFICATIONS AND NOTES HEREBY FURNISHED BY MC MILLAN PADDEN SMITH ARCHITECTURE ARE AND SHALL REMAIN THE PROPERTY OF MC MILLAN PADDEN SMITH ARCHITECTURE. THESE MATERIALS ARE TO BE USED ONLY WITH RESPECT TO THE PROJECT AND NOT TO BE REPRODUCED OR USED FOR ANY OTHER PROJECT WITHOUT THE WRITTEN CONSENT OF MC MILLAN PADDEN SMITH ARCHITECTURE. ANY REUSE OR MODIFICATION OF THESE MATERIALS WITHOUT THE WRITTEN CONSENT OF MC MILLAN PADDEN SMITH ARCHITECTURE IS EXPRESSLY FORBIDDEN. COPYRIGHT 2024 MC MILLAN PADDEN SMITH ARCHITECTURE.


1 ELECTRICAL - LEVEL 04 - AREA B - SR BH - LIGHTING - DEMOLITION

SCALE: 1/4" = 1'-0"

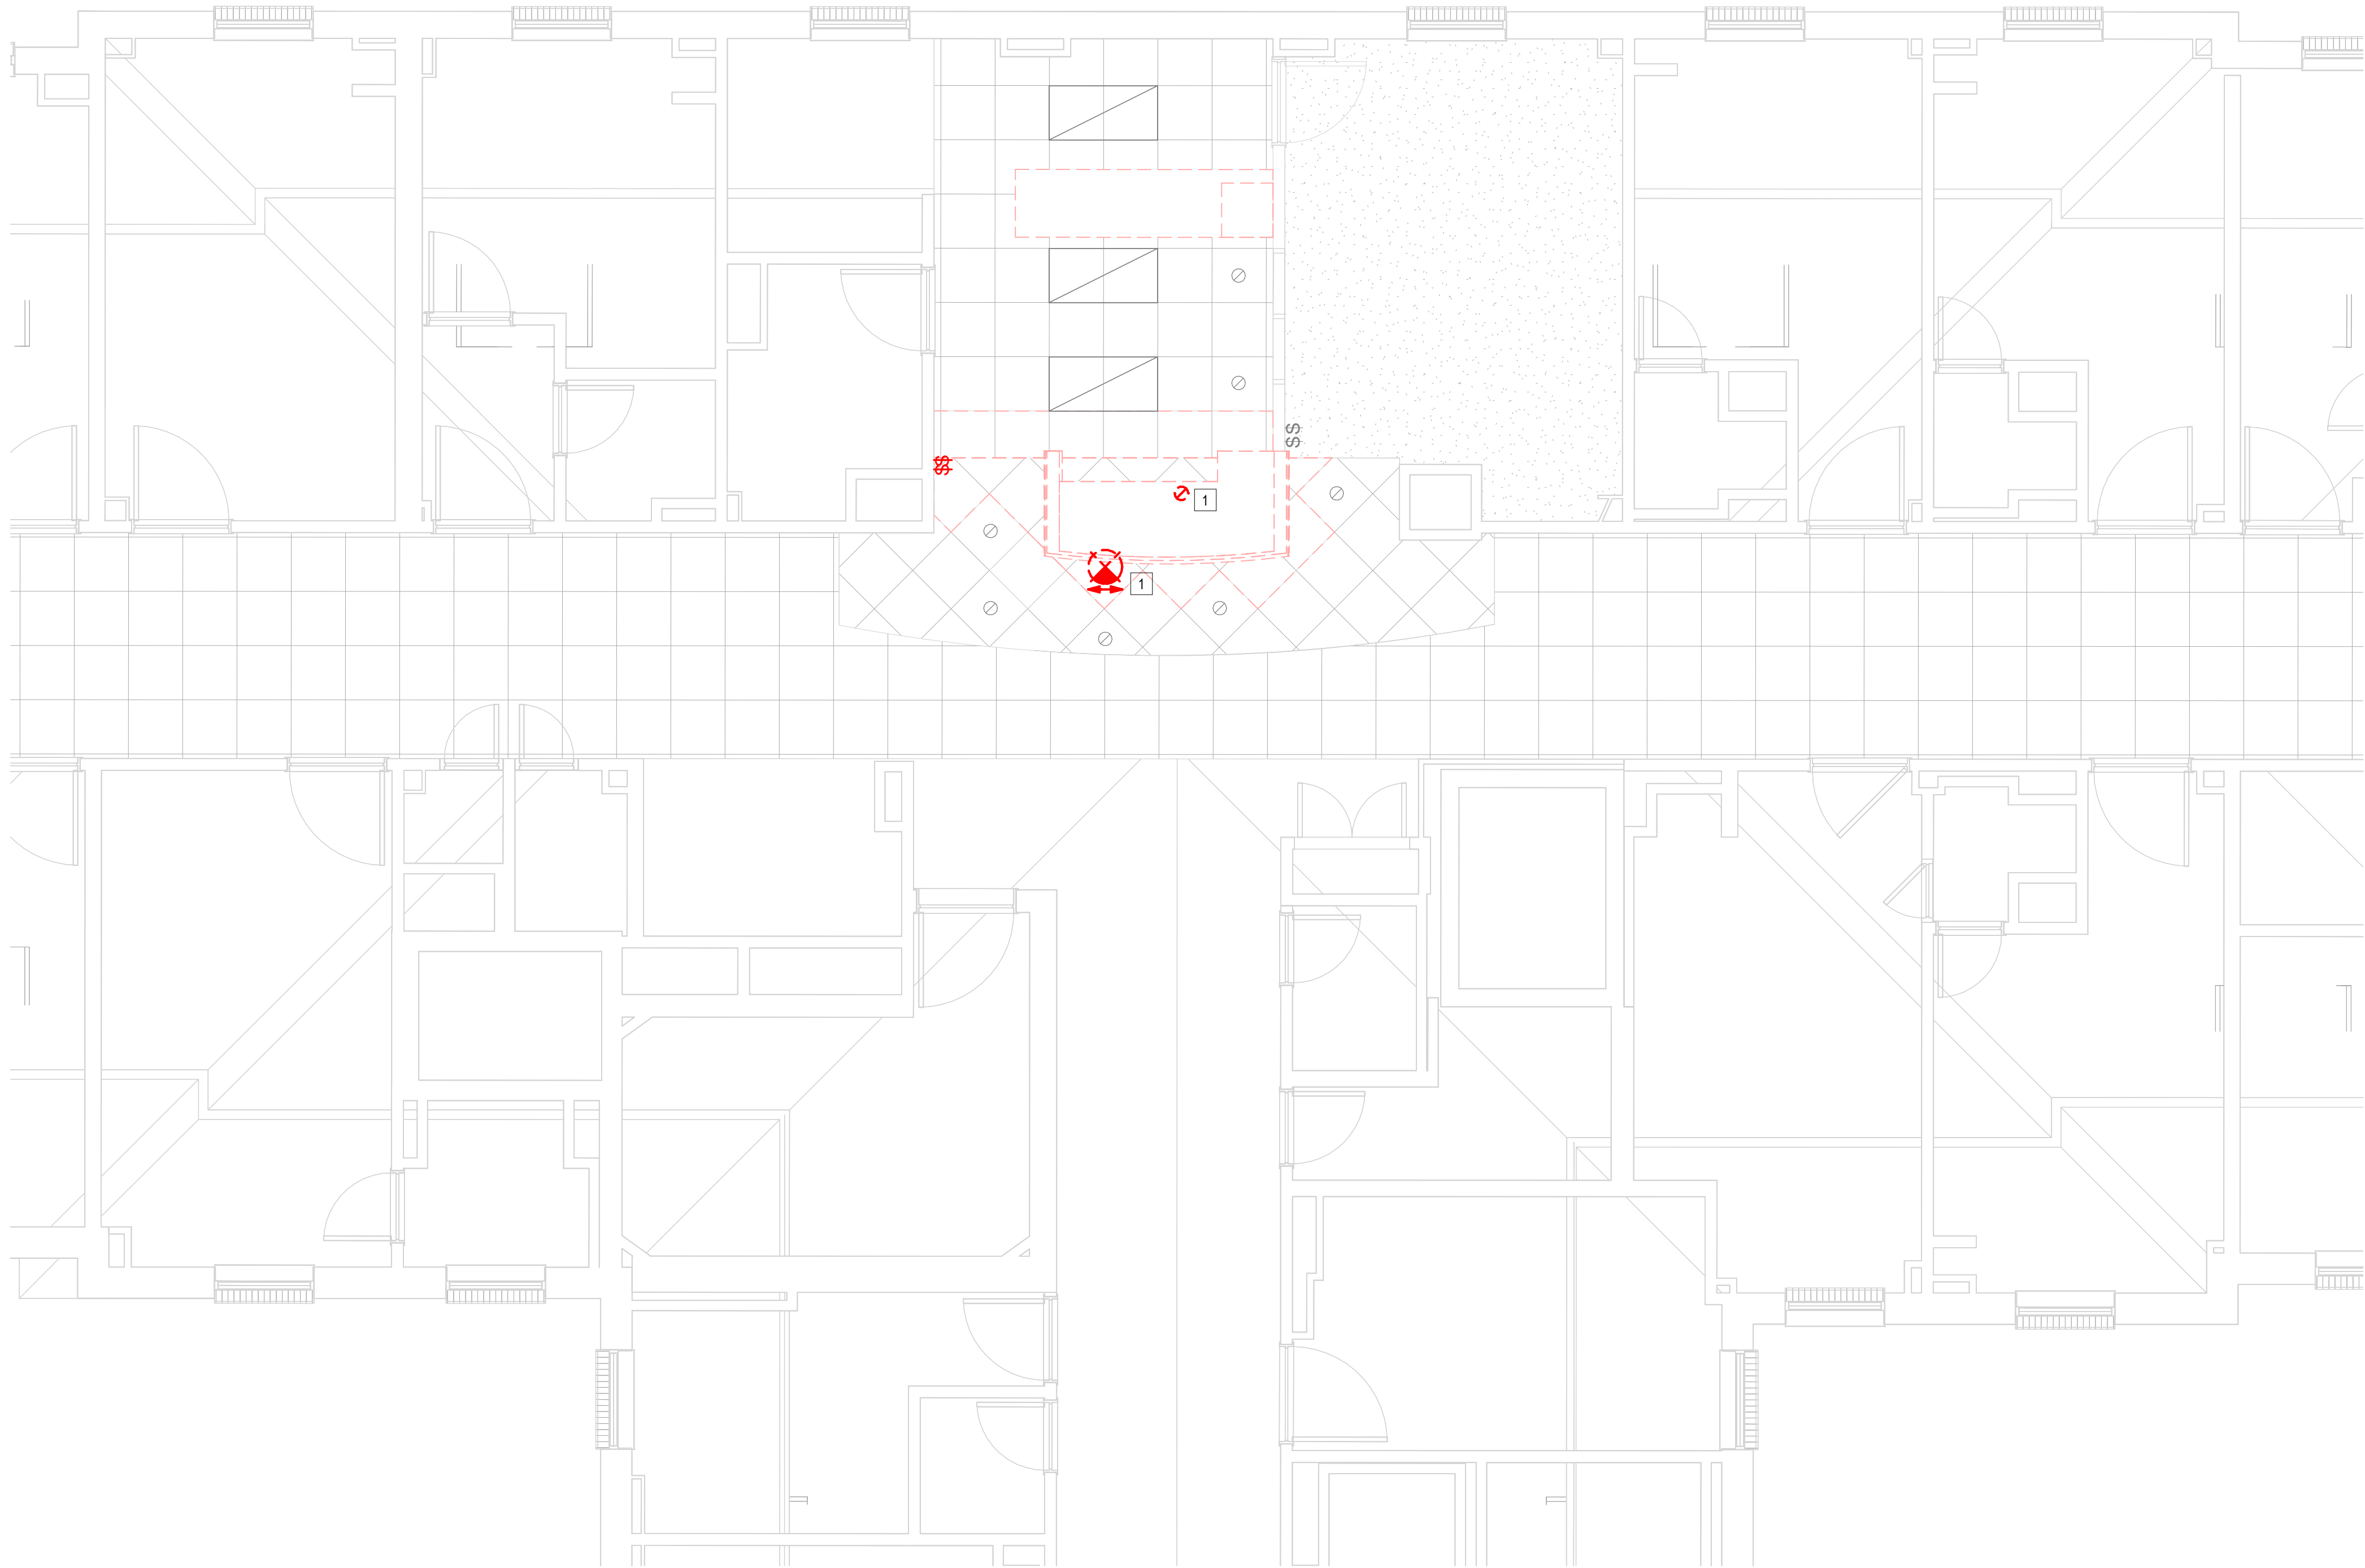


- # KEY NOTES:
1. REMOVE DOWNLIGHT AND EXIT SIGN. SAVE FOR REINSTALLATION IN NEW CEILING.

LINETYPE LEGEND	
	EXISTING TO REMAIN
	DEMOLITION

 

KEY PLAN

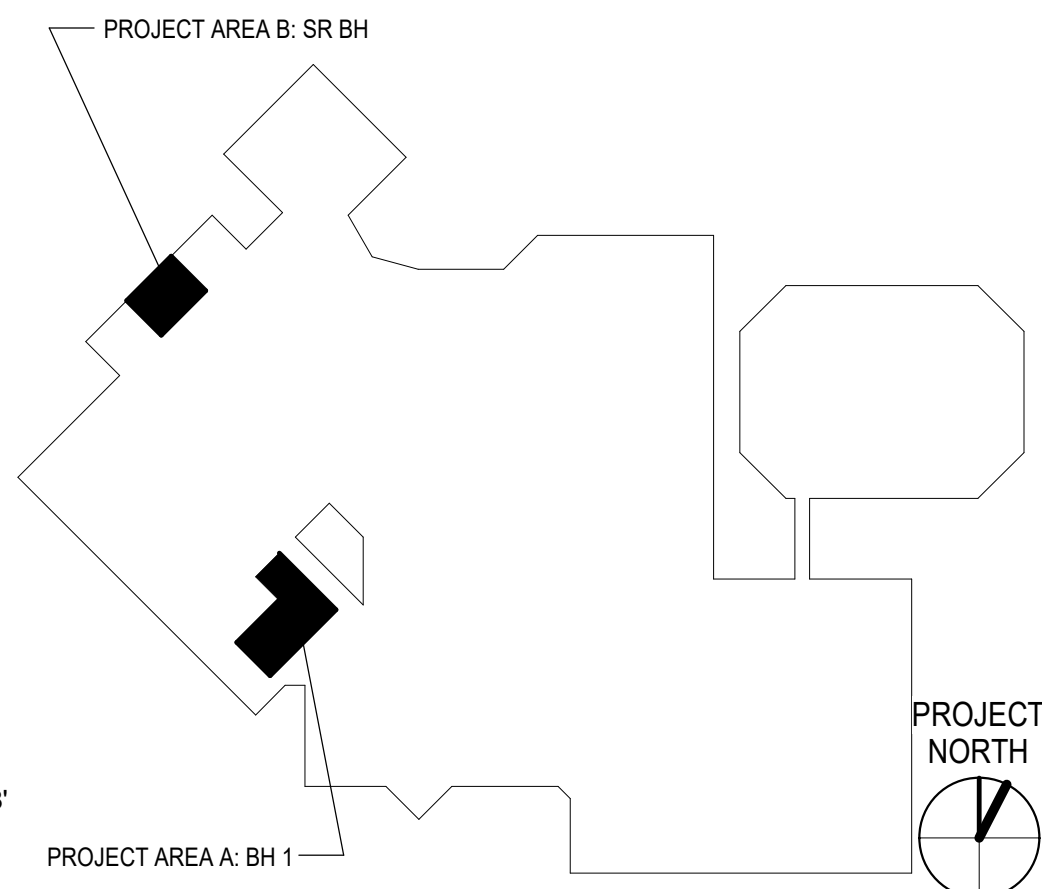

PRINCIPAL IN CHARGE: MS
PROJECT ARCHITECT: TAS
DRAWN BY: JGR

SHEET NAME:
**ELECTRICAL - LEVEL
04 - LIGHTING -
DEMOLITION**

SHEET NO. PROJECT NUMBER:
JAZZID_14452

A/E PROJECT #:
02600404.00

E202

D

C

B

A

ALL DRAWINGS, SPECIFICATIONS AND NOTES HEREBY FURNISHED BY MC MILLAN PAZDAN SMITH ARCHITECTURE ARE AND SHALL REMAIN THE PROPERTY OF MC MILLAN PAZDAN SMITH ARCHITECTURE. THESE MATERIALS ARE TO BE USED ONLY WITHIN THE PROJECT AND NOT TO BE REPRODUCED OR TRANSMITTED IN ANY FORM OR BY ANY MEANS, ELECTRONIC OR MECHANICAL, INCLUDING PHOTOCOPYING, RECORDING, OR BY ANY INFORMATION STORAGE AND RETRIEVAL SYSTEM, WITHOUT THE WRITTEN PERMISSION OF MC MILLAN PAZDAN SMITH ARCHITECTURE. ANY UNAUTHORIZED REPRODUCTION OR TRANSMISSION OF THESE MATERIALS IS PROHIBITED AND WILL BE PROSECUTED TO THE FULL EXTENT OF THE LAW. THE DESIGN AND CONSTRUCTION OF THIS PROJECT IS THE SOLE RESPONSIBILITY OF MC MILLAN PAZDAN SMITH ARCHITECTURE. ANY CHANGES TO THIS PROJECT MUST BE APPROVED BY MC MILLAN PAZDAN SMITH ARCHITECTURE IN WRITING. ANY UNAUTHORIZED CHANGES TO THIS PROJECT WILL BE AT THE USER'S SOLE RISK AND WITHOUT LIABILITY TO MC MILLAN PAZDAN SMITH ARCHITECTURE.




1 ELECTRICAL - LEVEL 04 - AREA B - SR BH - POWER AND SPECIAL SYSTEMS - DEMOLITION
SCALE: 1/4" = 1'-0"

LINETYPE LEGEND	
—	EXISTING TO REMAIN
- - - - -	DEMOLITION



KEY PLAN

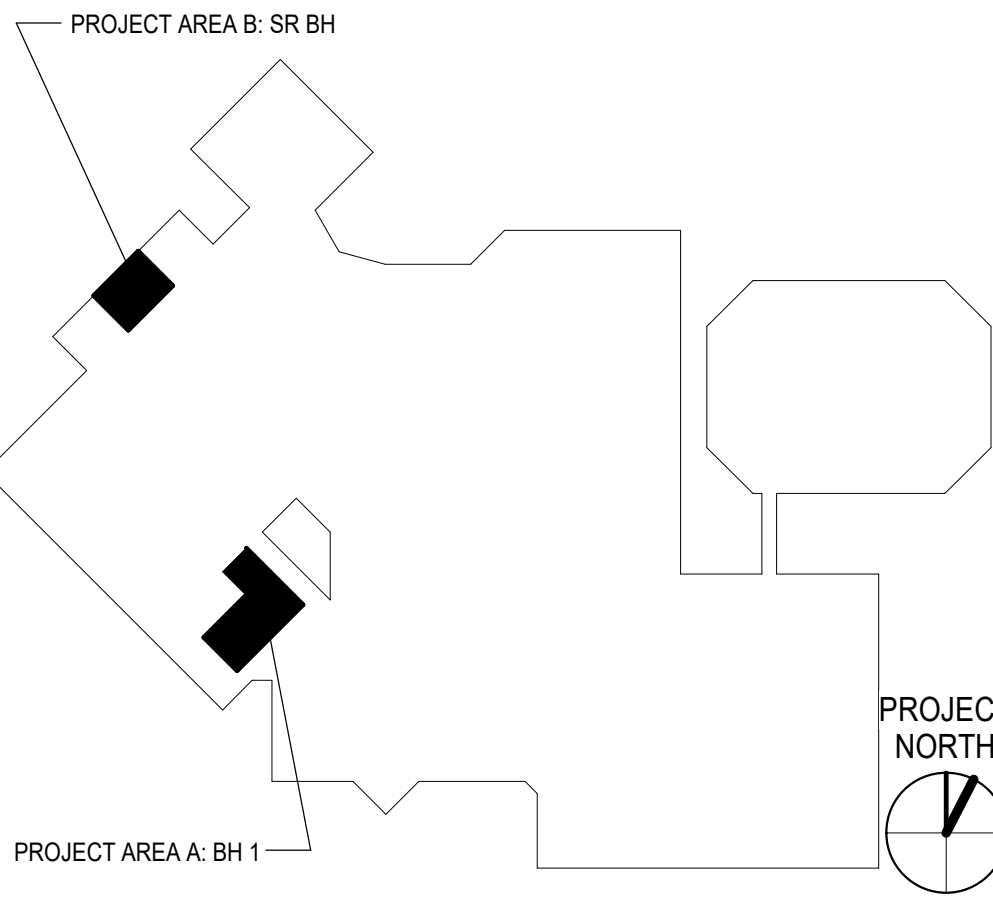

PRINCIPAL IN CHARGE: MS
PROJECT ARCHITECT: TAS
DRAWN BY: JGR

SHEET NAME:
ELECTRICAL - LEVEL 04 - POWER AND SPECIAL SYSTEMS - DEMOLITION

SHEET NO. PROJECT NUMBER:
JAZZID_14452

A/E PROJECT #: 02600404.00

E203

8020 Tower Point Drive
Charlotte, NC 28227
704.841.2588 (Voice)
704.841.2587 (Fax)
NC License # F-1222

Designed JGR
Checked TPB

Drawn JGR
Date 07/15/2026

Project No. 06681-0043

THIS DRAWING IS AN INSTRUMENT OF SERVICE. THE DRAWING AND INFORMATION THEREON IS THE PROPERTY OF MCKIM & CREED, INC. AND IS NOT TO BE REPRODUCED OR TRANSMITTED IN ANY FORM OR BY ANY MEANS, ELECTRONIC OR MECHANICAL, INCLUDING PHOTOCOPYING, RECORDING, OR BY ANY INFORMATION STORAGE AND RETRIEVAL SYSTEM, WITHOUT THE WRITTEN PERMISSION OF MCKIM & CREED, INC. IT IS EXPRESSLY FORBIDDEN. COPYRIGHT 2026 MCKIM & CREED, INC.



Atrium Health
PROJECT & CONSTRUCTION MANAGEMENT
1400 East Morehead St.
Charlotte, NC 28204




ATRIUM HEALTH

AH CABARRUS BH RENOVATION

AH Cabarrus Memorial Building
Atrium Health Facility #: 1232
920 Church Street North, Concord, NC 28025


ISSUE DATE:	07/15/2026	
PHASE:	Construction Documents	
SHEET ISSUE:		
NO.	DATE	DESCRIPTION

ALL DRAWINGS, SPECIFICATIONS AND NOTES HEREBY REMAIN THE PROPERTY OF MCMILLAN PAZDAN SMITH ARCHITECTURE. THESE MATERIALS ARE TO BE USED ONLY WITH RESPECT TO THE PROJECT AND NOT TO BE REPRODUCED OR USED FOR ANY OTHER PROJECT WITHOUT THE WRITTEN PERMISSION OF MCMILLAN PAZDAN SMITH ARCHITECTURE. ANY REUSE OR MODIFICATION OF THESE MATERIALS WITHOUT THE WRITTEN PERMISSION OF MCMILLAN PAZDAN SMITH ARCHITECTURE IS EXPRESSLY FORBIDDEN. COPYRIGHT 2024 MCMILLAN & CREED, INC.

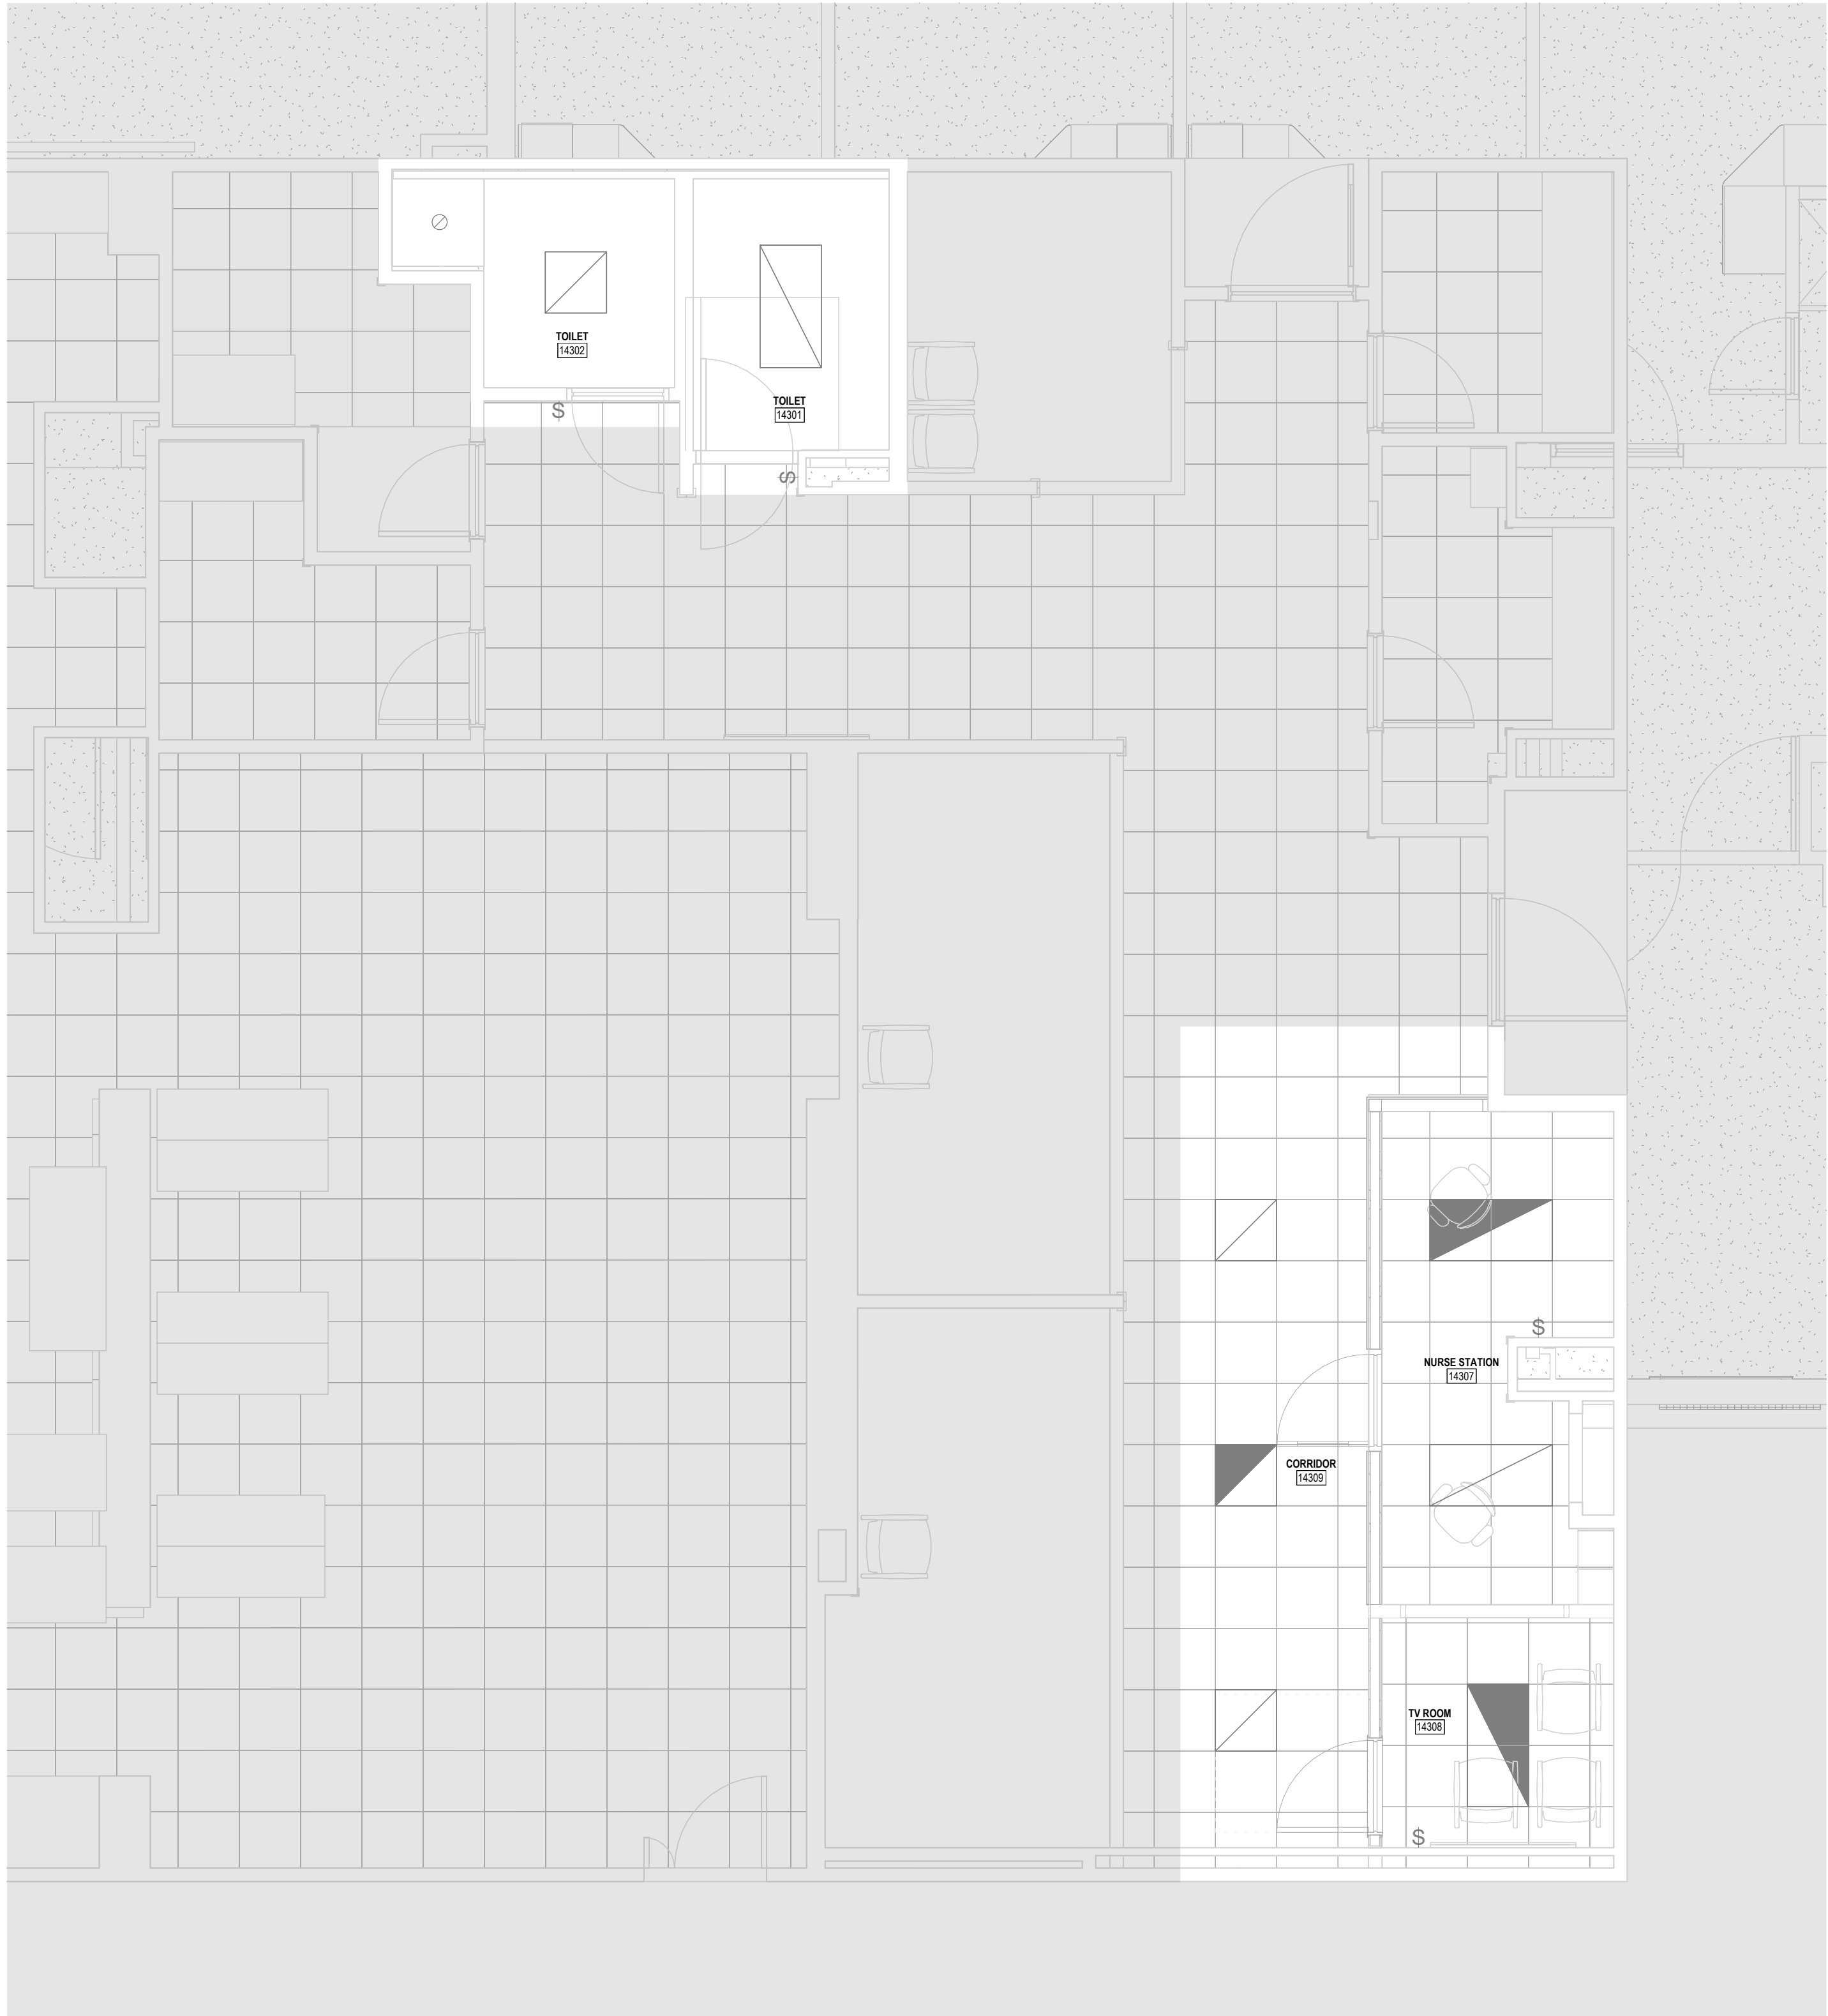


1 ELECTRICAL - LEVEL 01 - AREA A - BH 1 - LIGHTING - NEW WORK
SCALE: 1/4" = 1'-0"

LINETYPE LEGEND	
	EXISTING TO REMAIN
	DEMOLITION

 

KEY PLAN

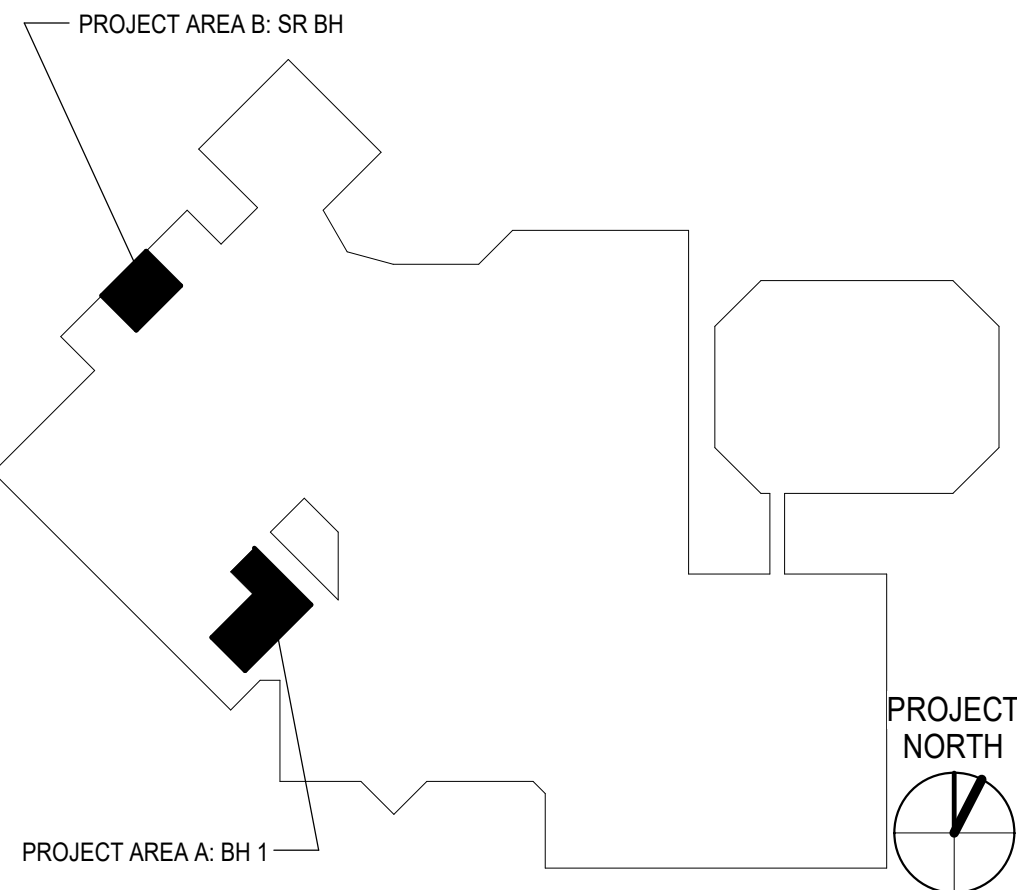

PRINCIPAL IN CHARGE: MS
PROJECT ARCHITECT: TAS
DRAWN BY: JGR

SHEET NAME:
**ELECTRICAL - LEVEL
01 - LIGHTING - NEW
WORK**

SHEET NO. PROJECT NUMBER:
JAZZ01_14452
A/E PROJECT #: 02600404.00

E300

8020 Tower Point Drive
Charlotte, NC 28227
704.841.2588 (Voice)
704.841.2587 (Fax)
NC License # F-1222

Designed JGR
Checked TPB
Date 07/15/2026

Drawn JGR
Project No. 06681-0043

THIS DRAWING IS AN INSTRUMENT OF SERVICE. THE DRAWING AND INFORMATION THEREON IS THE PROPERTY OF MCKIM & CREED, INC. AND IS NOT TO BE REPRODUCED OR USED FOR ANY OTHER PROJECT WITHOUT THE WRITTEN PERMISSION OF MCKIM & CREED, INC. IT IS EXPRESSLY FORBIDDEN. COPYRIGHT 2024 MCKIM & CREED, INC.

Atrium Health
PROJECT & CONSTRUCTION MANAGEMENT
1400 East Morehead St.
Charlotte, NC 28204

ATRIUM HEALTH
AH CABARRUS BH RENOVATION
AH Cabarrus Memorial Building
Atrium Health Facility #: 1232
920 Church Street North, Concord, NC 28025

ISSUE DATE:	07/15/2026
PHASE:	Construction Documents
SHEET ISSUE:	
NO. DATE DESCRIPTION	

PROJECT AREA B: SR BH

PROJECT AREA A: BH 1

PROJECT NORTH



**mcmillan
pazdan
smith**
ARCHITECTURE

AH Cabarrus Memorial Building
Atrium Health Facility #: 1232
920 Church Street North, Concord, NC 28025

PRINCIPAL IN CHARGE:	MS
PROJECT ARCHITECT:	TAS
DRAWN BY:	JGR

SHEET NO. PROJECT NUMBER:
JAZZID_14452
A/E PROJECT #:
02600404.00

E302

LINETYPE LEGEND

————— EXISTING TO REMAIN

————— DEMOLITION

1/4"=1'-0"

PROJECT AREA B: SR BH

PROJECT AREA A: BH 1


PROJECT NORTH

SCALE: 1/4" = 1'-0"


ALL DRAWINGS, SPECIFICATIONS AND NOTES HEREBY FURNISHED BY MC MILLAN PADDAN SMITH ARCHITECTURE ARE AND SHALL REMAIN THE PROPERTY OF MC MILLAN PADDAN SMITH ARCHITECTURE. THESE MATERIALS ARE TO BE USED ONLY WITH RESPECT TO THE PROJECT AND NOT TO BE REPRODUCED, COPIED, REPRODUCED, OR OTHERWISE USED FOR ANY OTHER PROJECT WITHOUT THE WRITTEN CONSENT OF MC MILLAN PADDAN SMITH ARCHITECTURE. ANY REUSE OF THESE MATERIALS FOR ANY OTHER PROJECT WITHOUT THE WRITTEN CONSENT OF MC MILLAN PADDAN SMITH ARCHITECTURE IS EXPRESSLY FORBIDDEN. COPYRIGHT 2024 MC MILLAN PADDAN SMITH ARCHITECTURE.

1 ELECTRICAL - LEVEL 04 - AREA B - SR BH - POWER AND SPECIAL SYSTEMS - NEW WORK


SCALE: 1/4" = 1'-0"

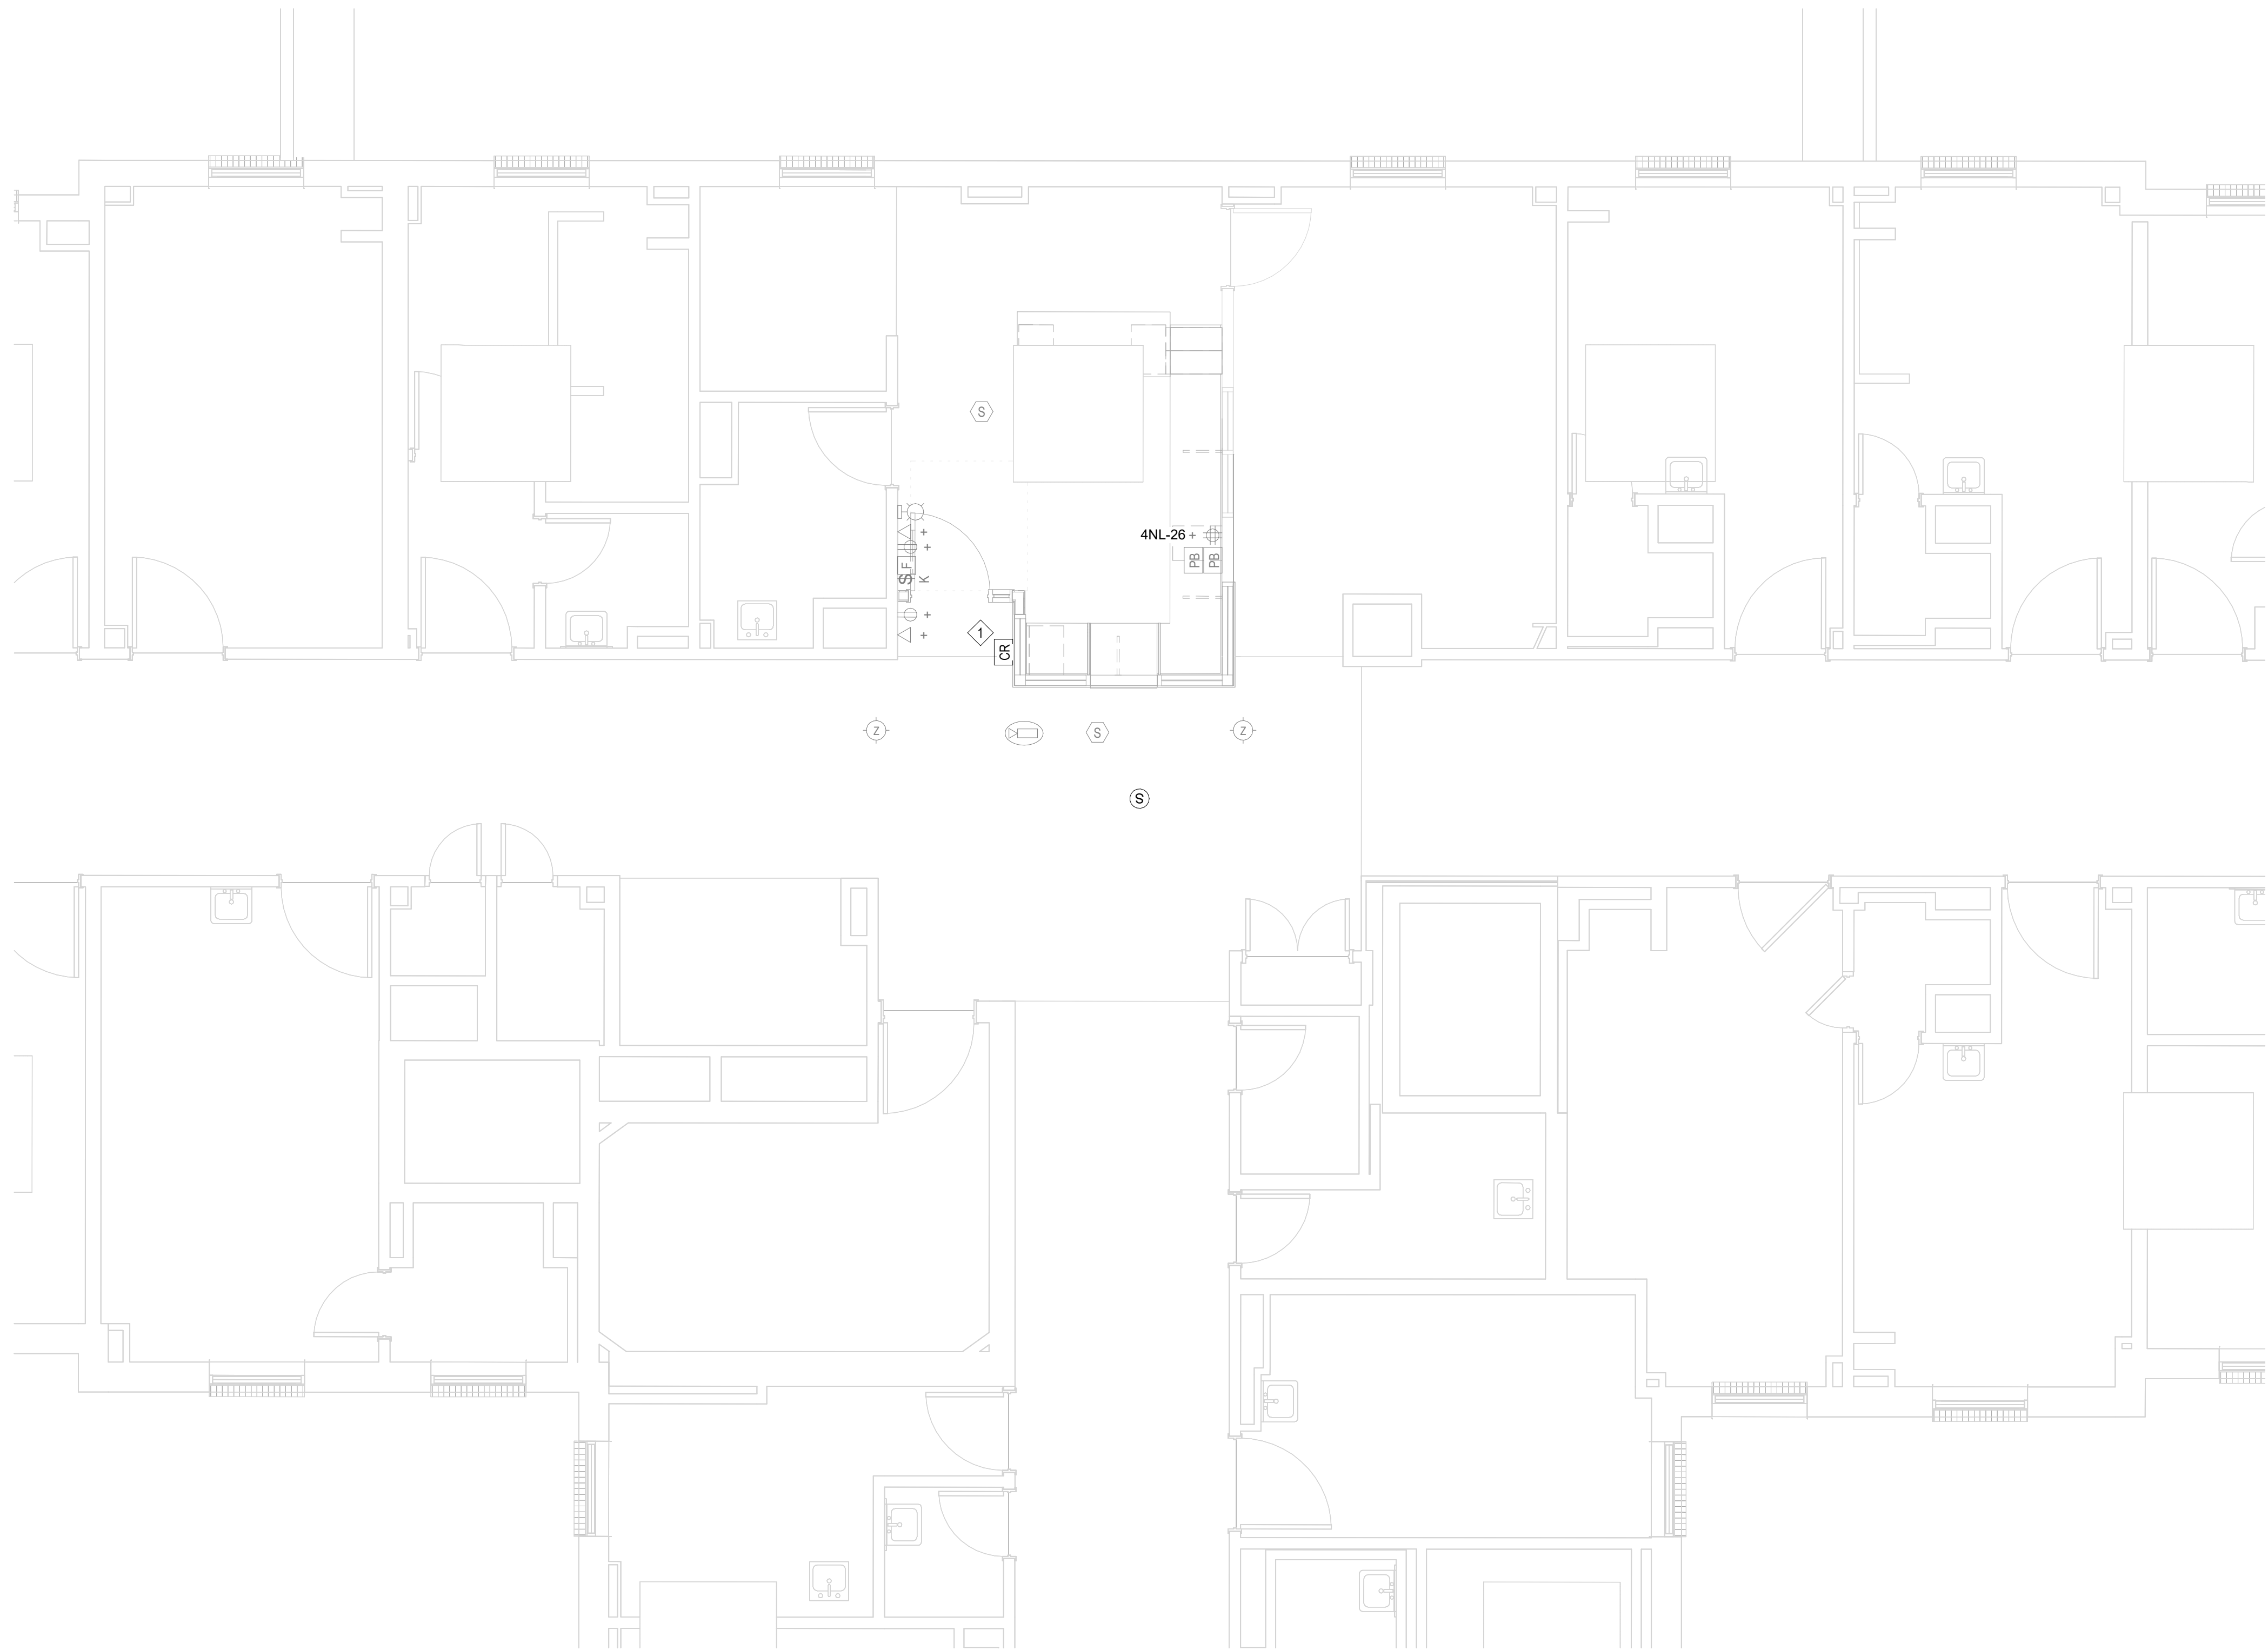

LINETYPE LEGEND	
	EXISTING TO REMAIN
	DEMOLITION

 

KEY PLAN

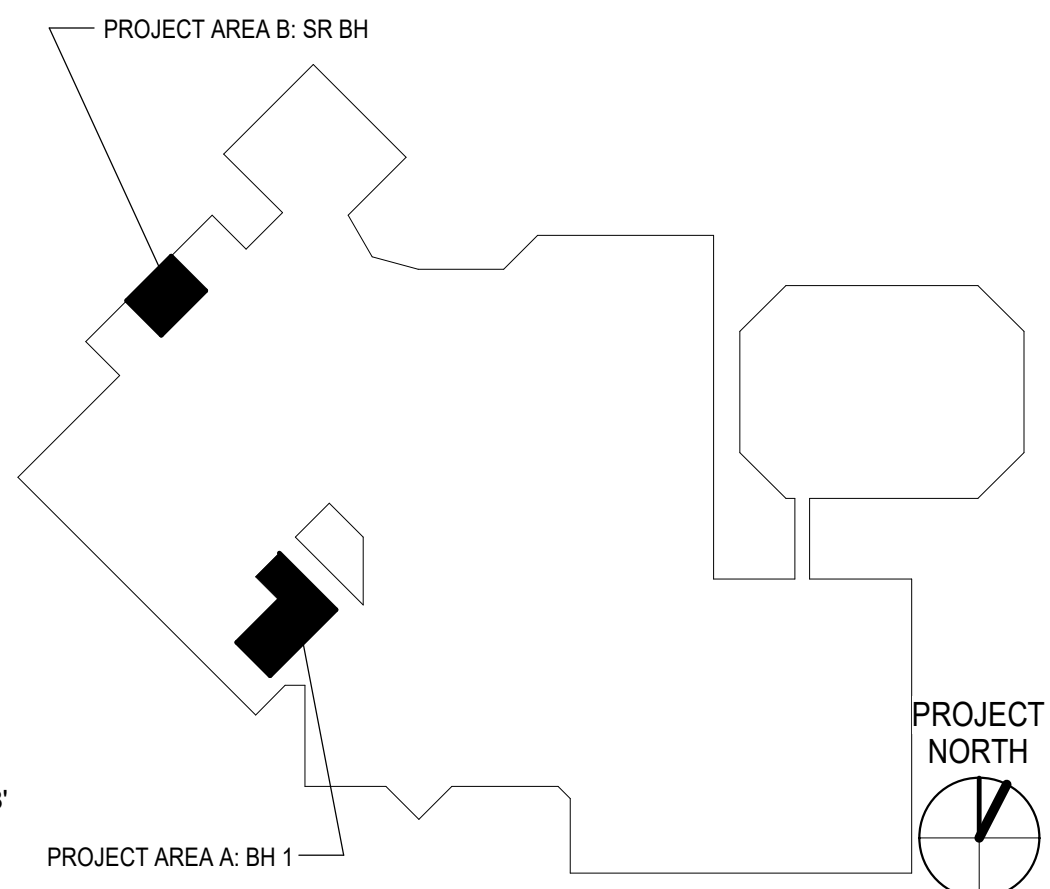

- KEY NOTES:
1. LOW CARD READER TO BE HOSTED BENEATH WINDOW SPACE.

8020 Tower Point Drive
Charlotte, NC 28227
704.841.2588 (Voice)
704.841.2587 (Fax)
NC License # F-1222

Designed JGR
Checked TPB
Project No. 06601-0043

Drawn JGR
Date 07/15/2026

Atrium Health

PROJECT & CONSTRUCTION MANAGEMENT
1400 East Morehead St.
Charlotte, NC 28204

mcmillan
pazdan
smith

ARCHITECTURE

McKIM & CREED

ENGINEERS SURVEYORS PLANNERS

ATRIUM HEALTH

AH CABARRUS BH RENOVATION

AH Cabarrus Memorial Building
Atrium Health Facility #: 1232
920 Church Street North, Concord, NC 28025

ISSUE DATE:	07/15/2026	
PHASE:	Construction Documents	
SHEET ISSUE:		
NO.	DATE	DESCRIPTION

PRINCIPAL IN CHARGE: MS
PROJECT ARCHITECT: TAS
DRAWN BY: JGR

SHEET NAME:
ELECTRICAL - LEVEL
04 - POWER AND
SPECIAL SYSTEMS -
NEW WORK

SHEET NO. PROJECT NUMBER:
JAZZID_14452

A/E PROJECT #: 02600404.00

E303

